

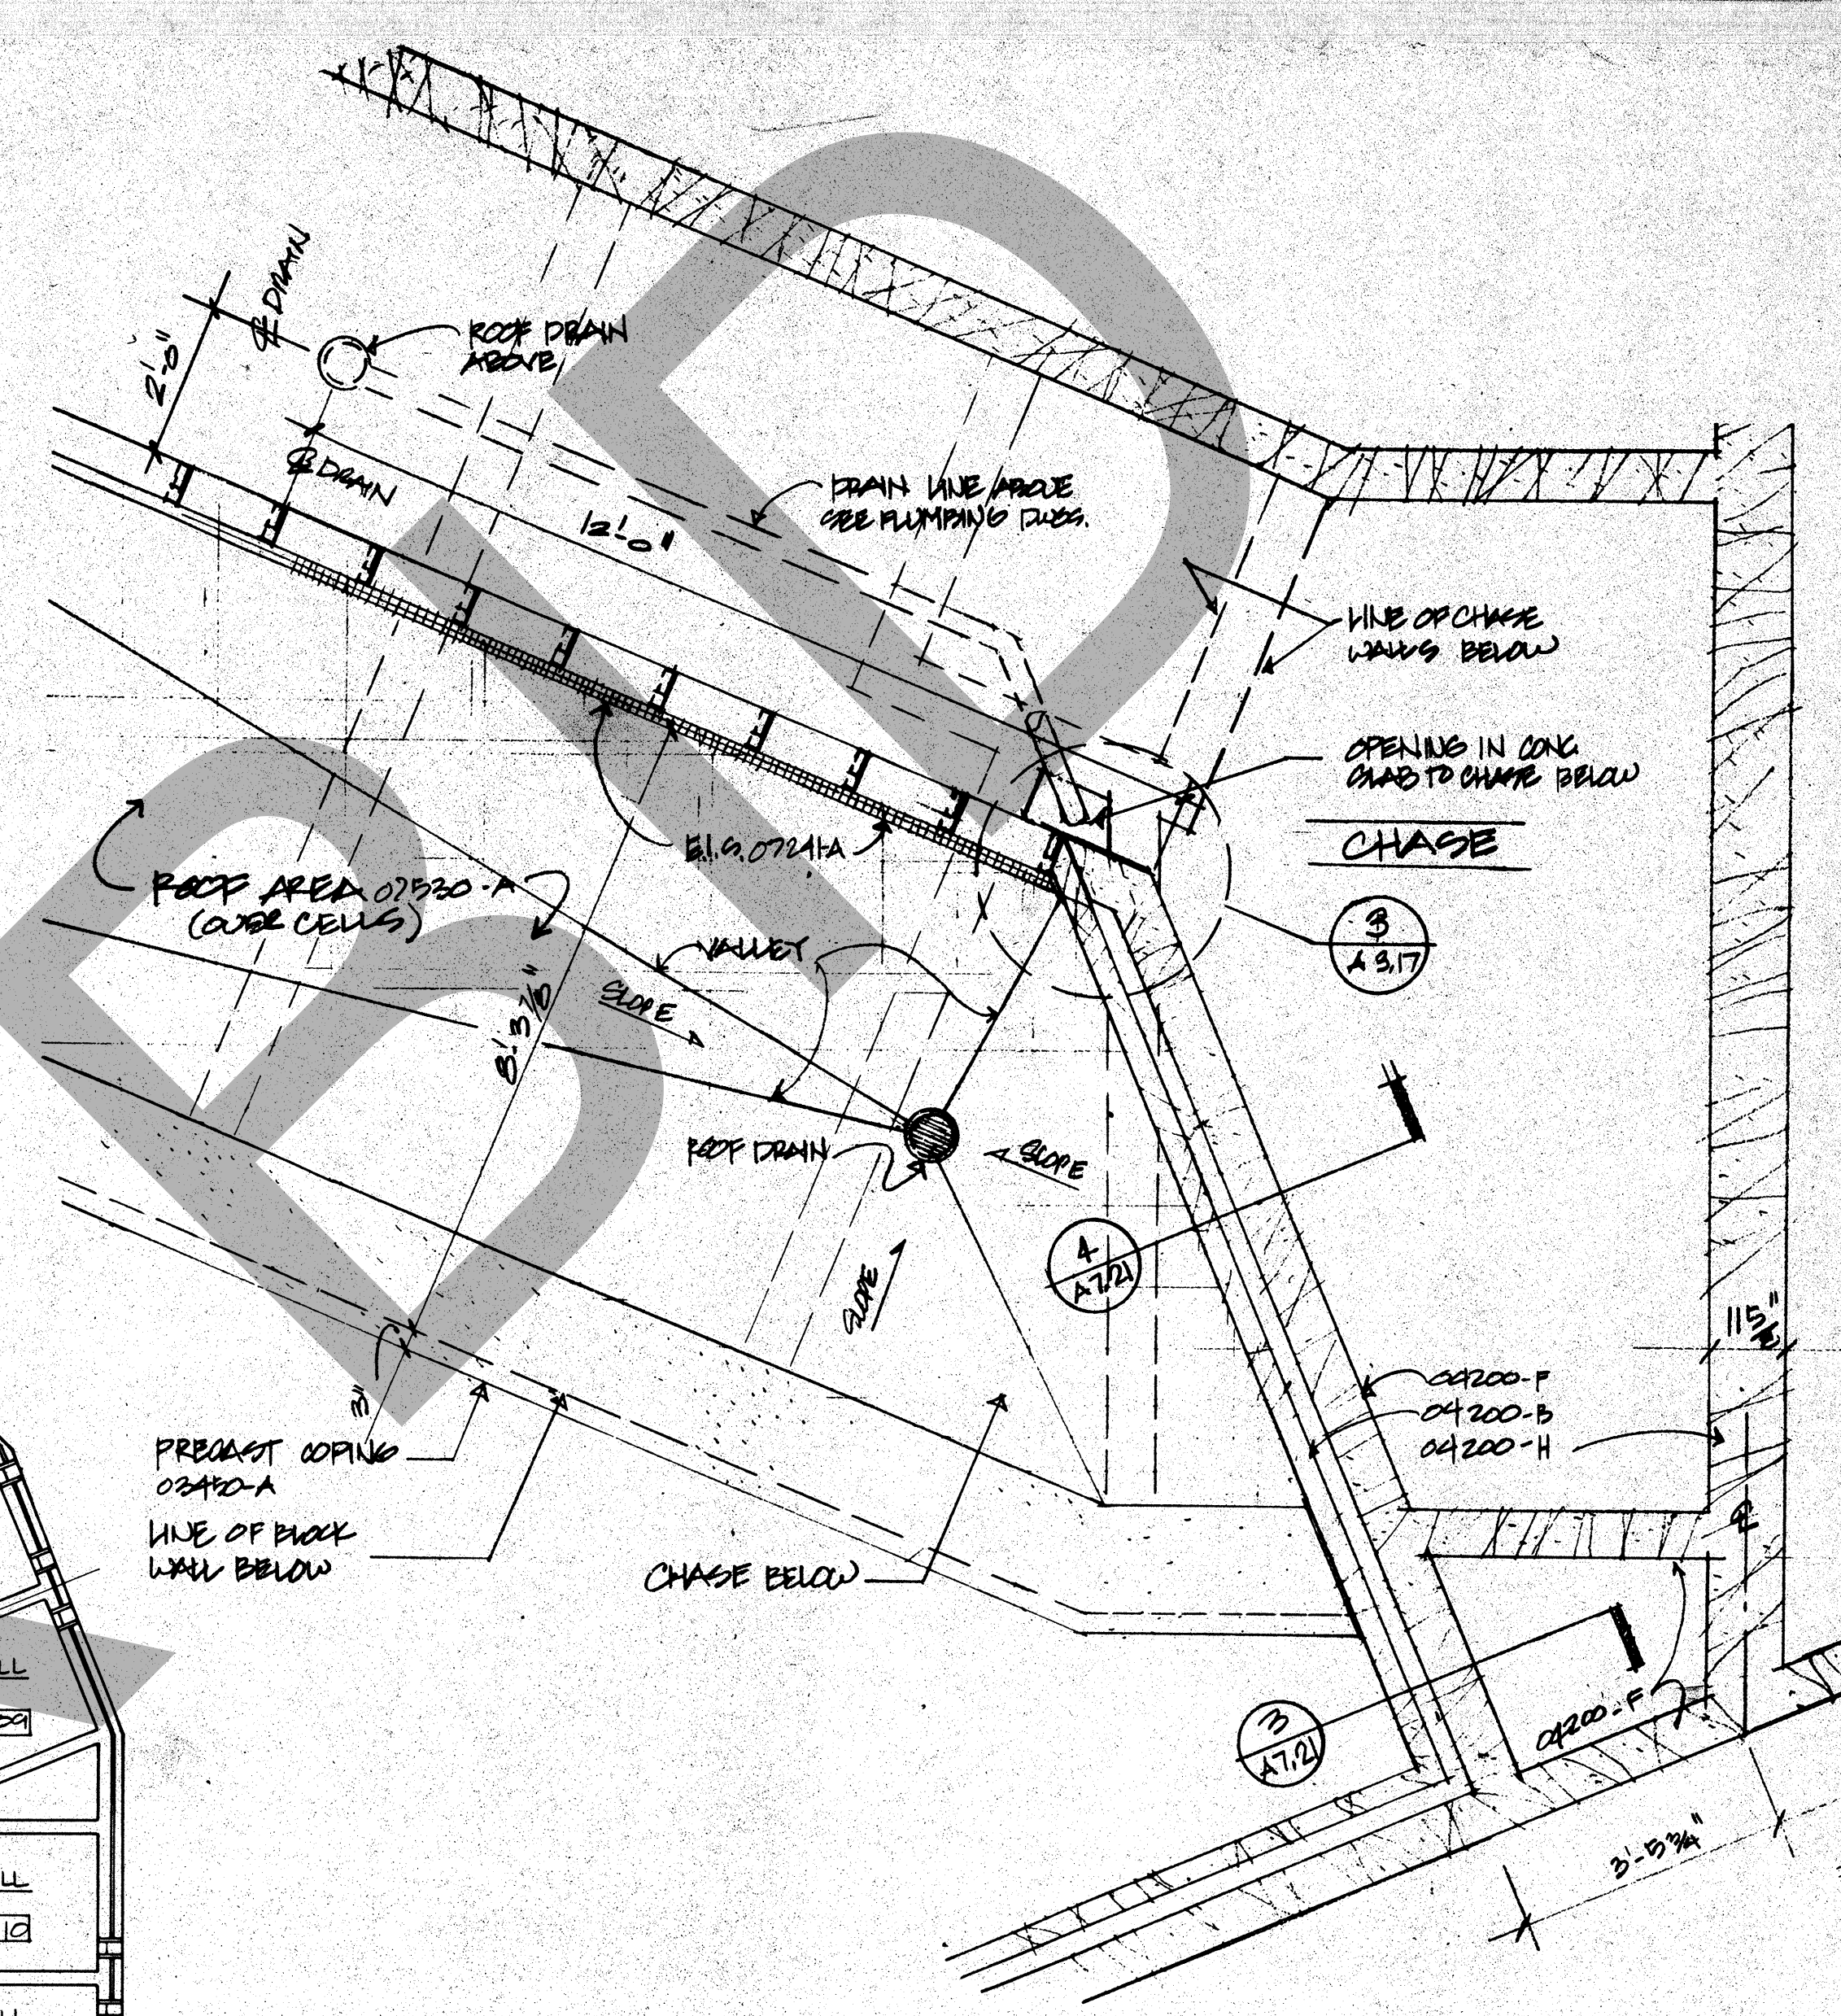


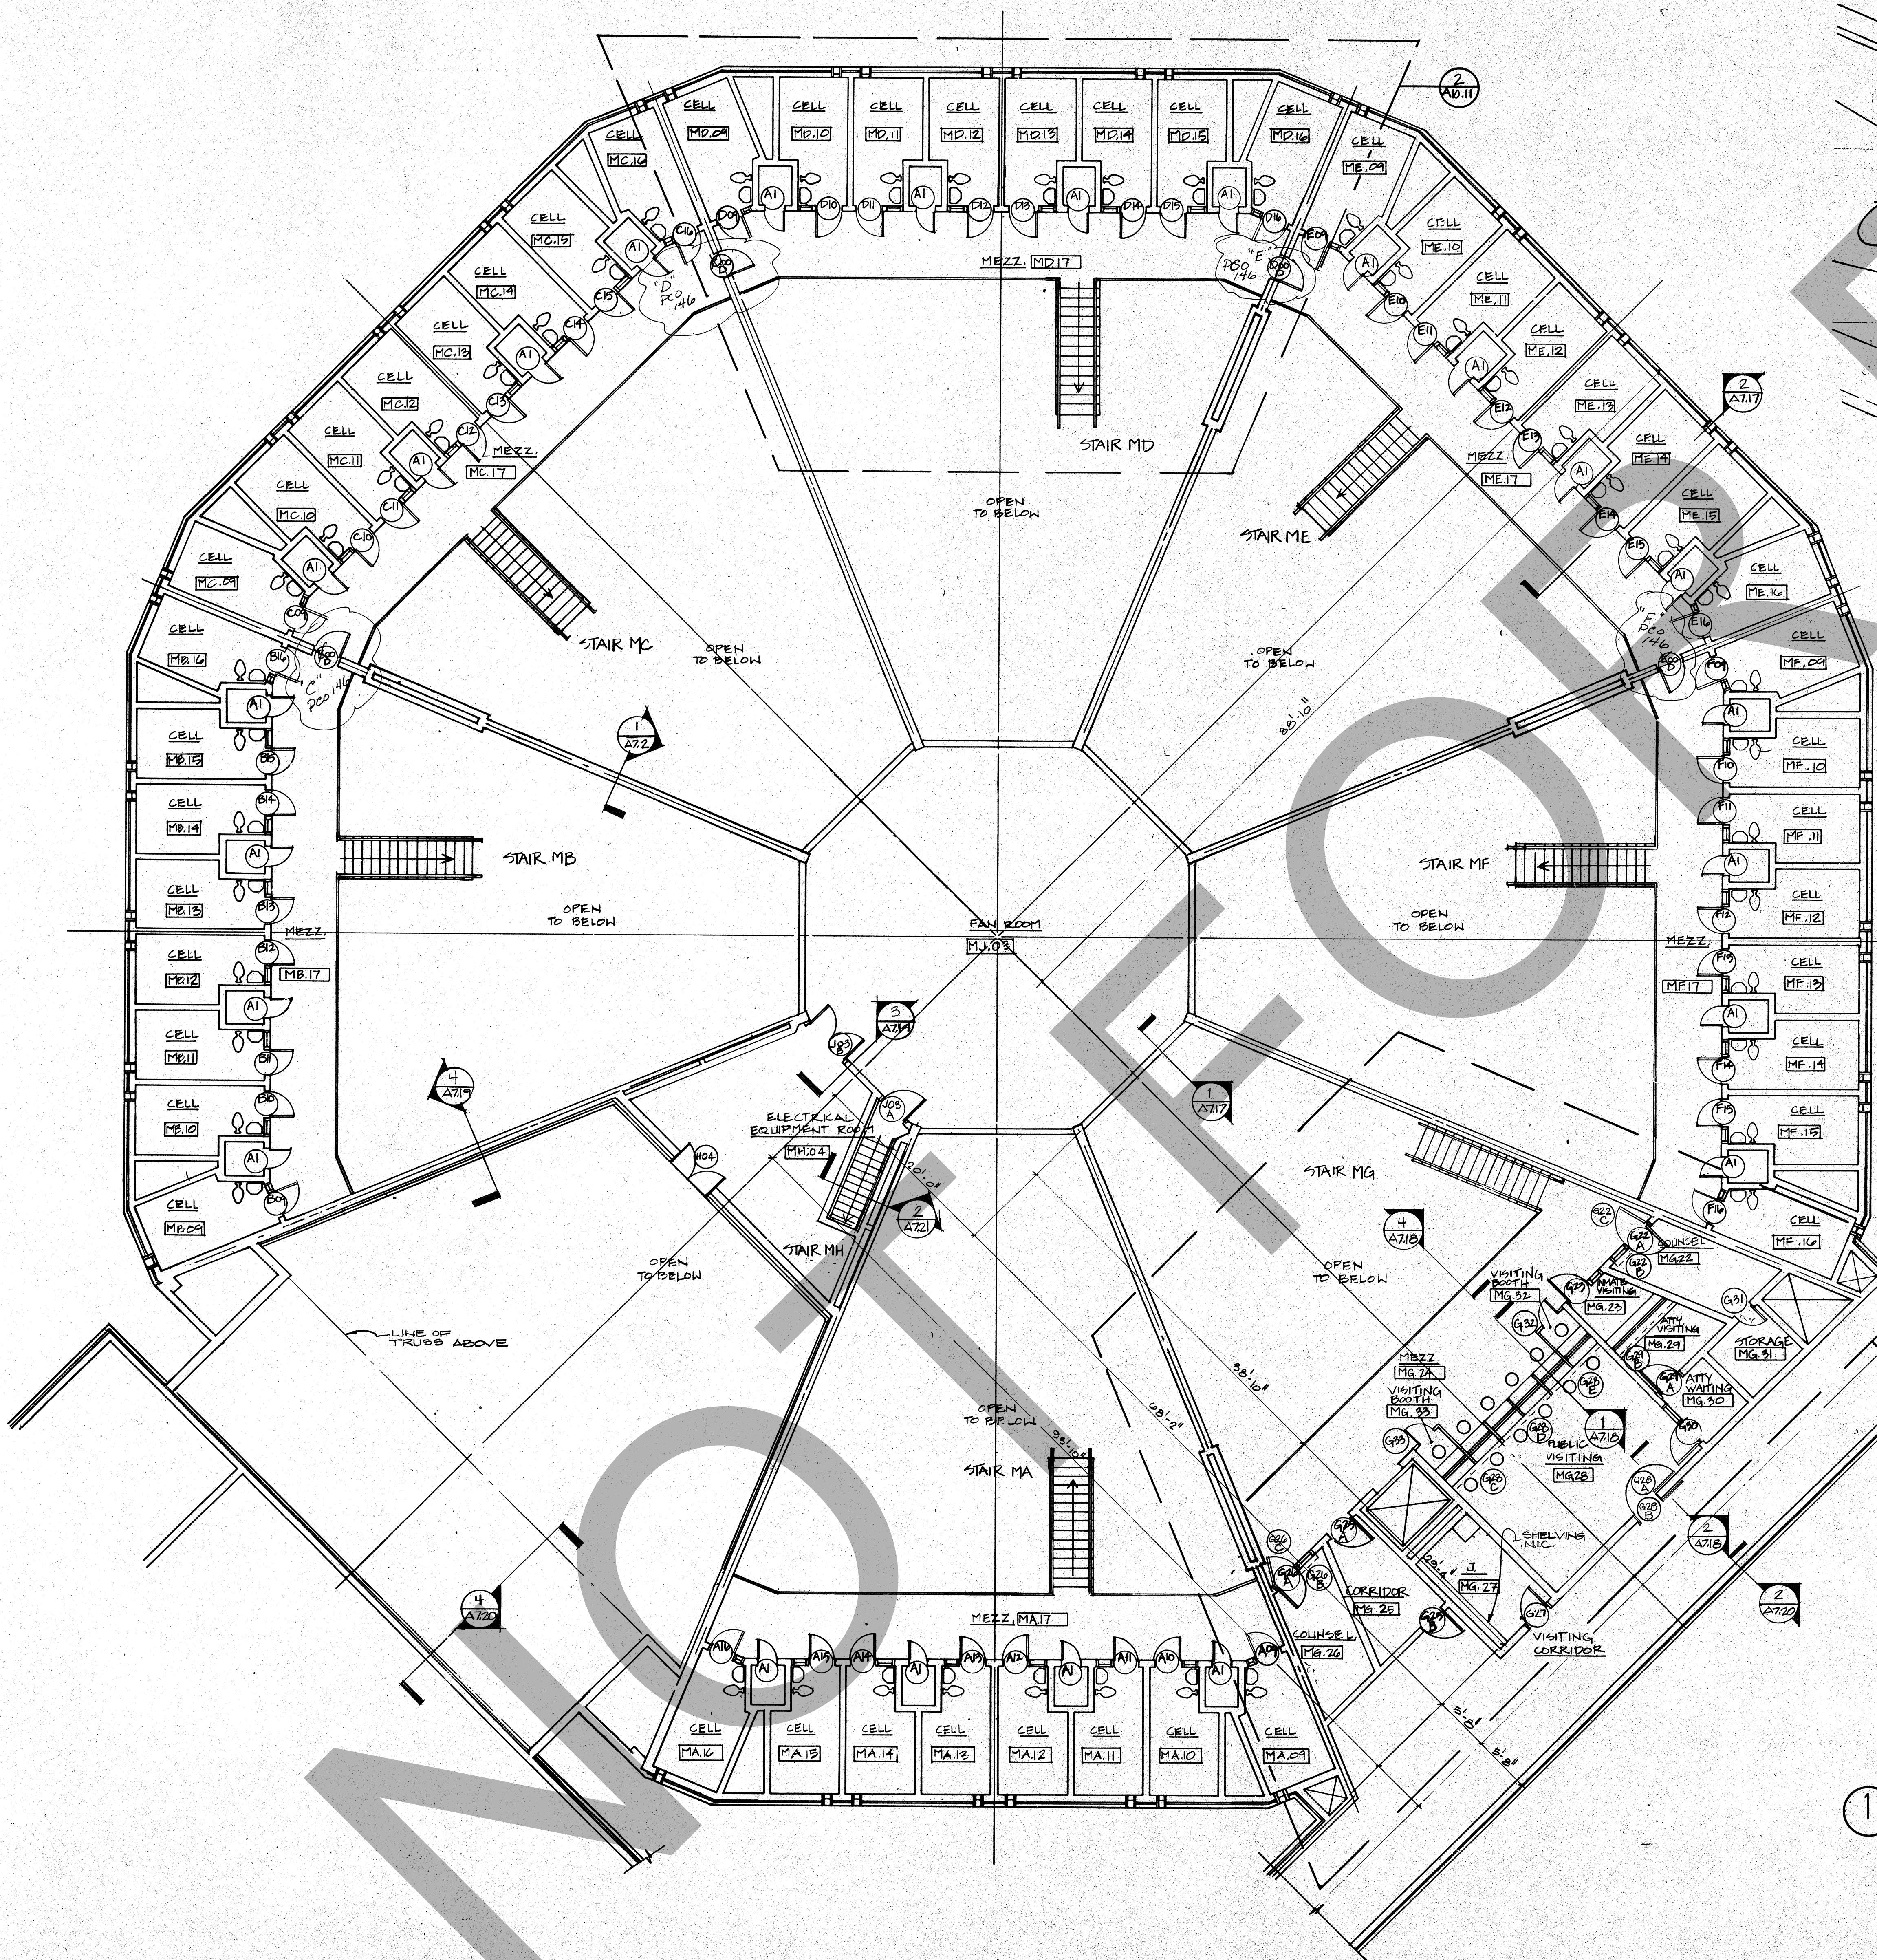

2 PLAN OF HOUSING CORRIDOR JUNCTION
1/2" = 1'-0"


2"x6" METAL STUDS ATTACHED
INSIDE OF METAL STUDS @
10' O.C. - LAP 24" AND WELD
AT TOP & BOTTOM.
SEE 2/A7.17

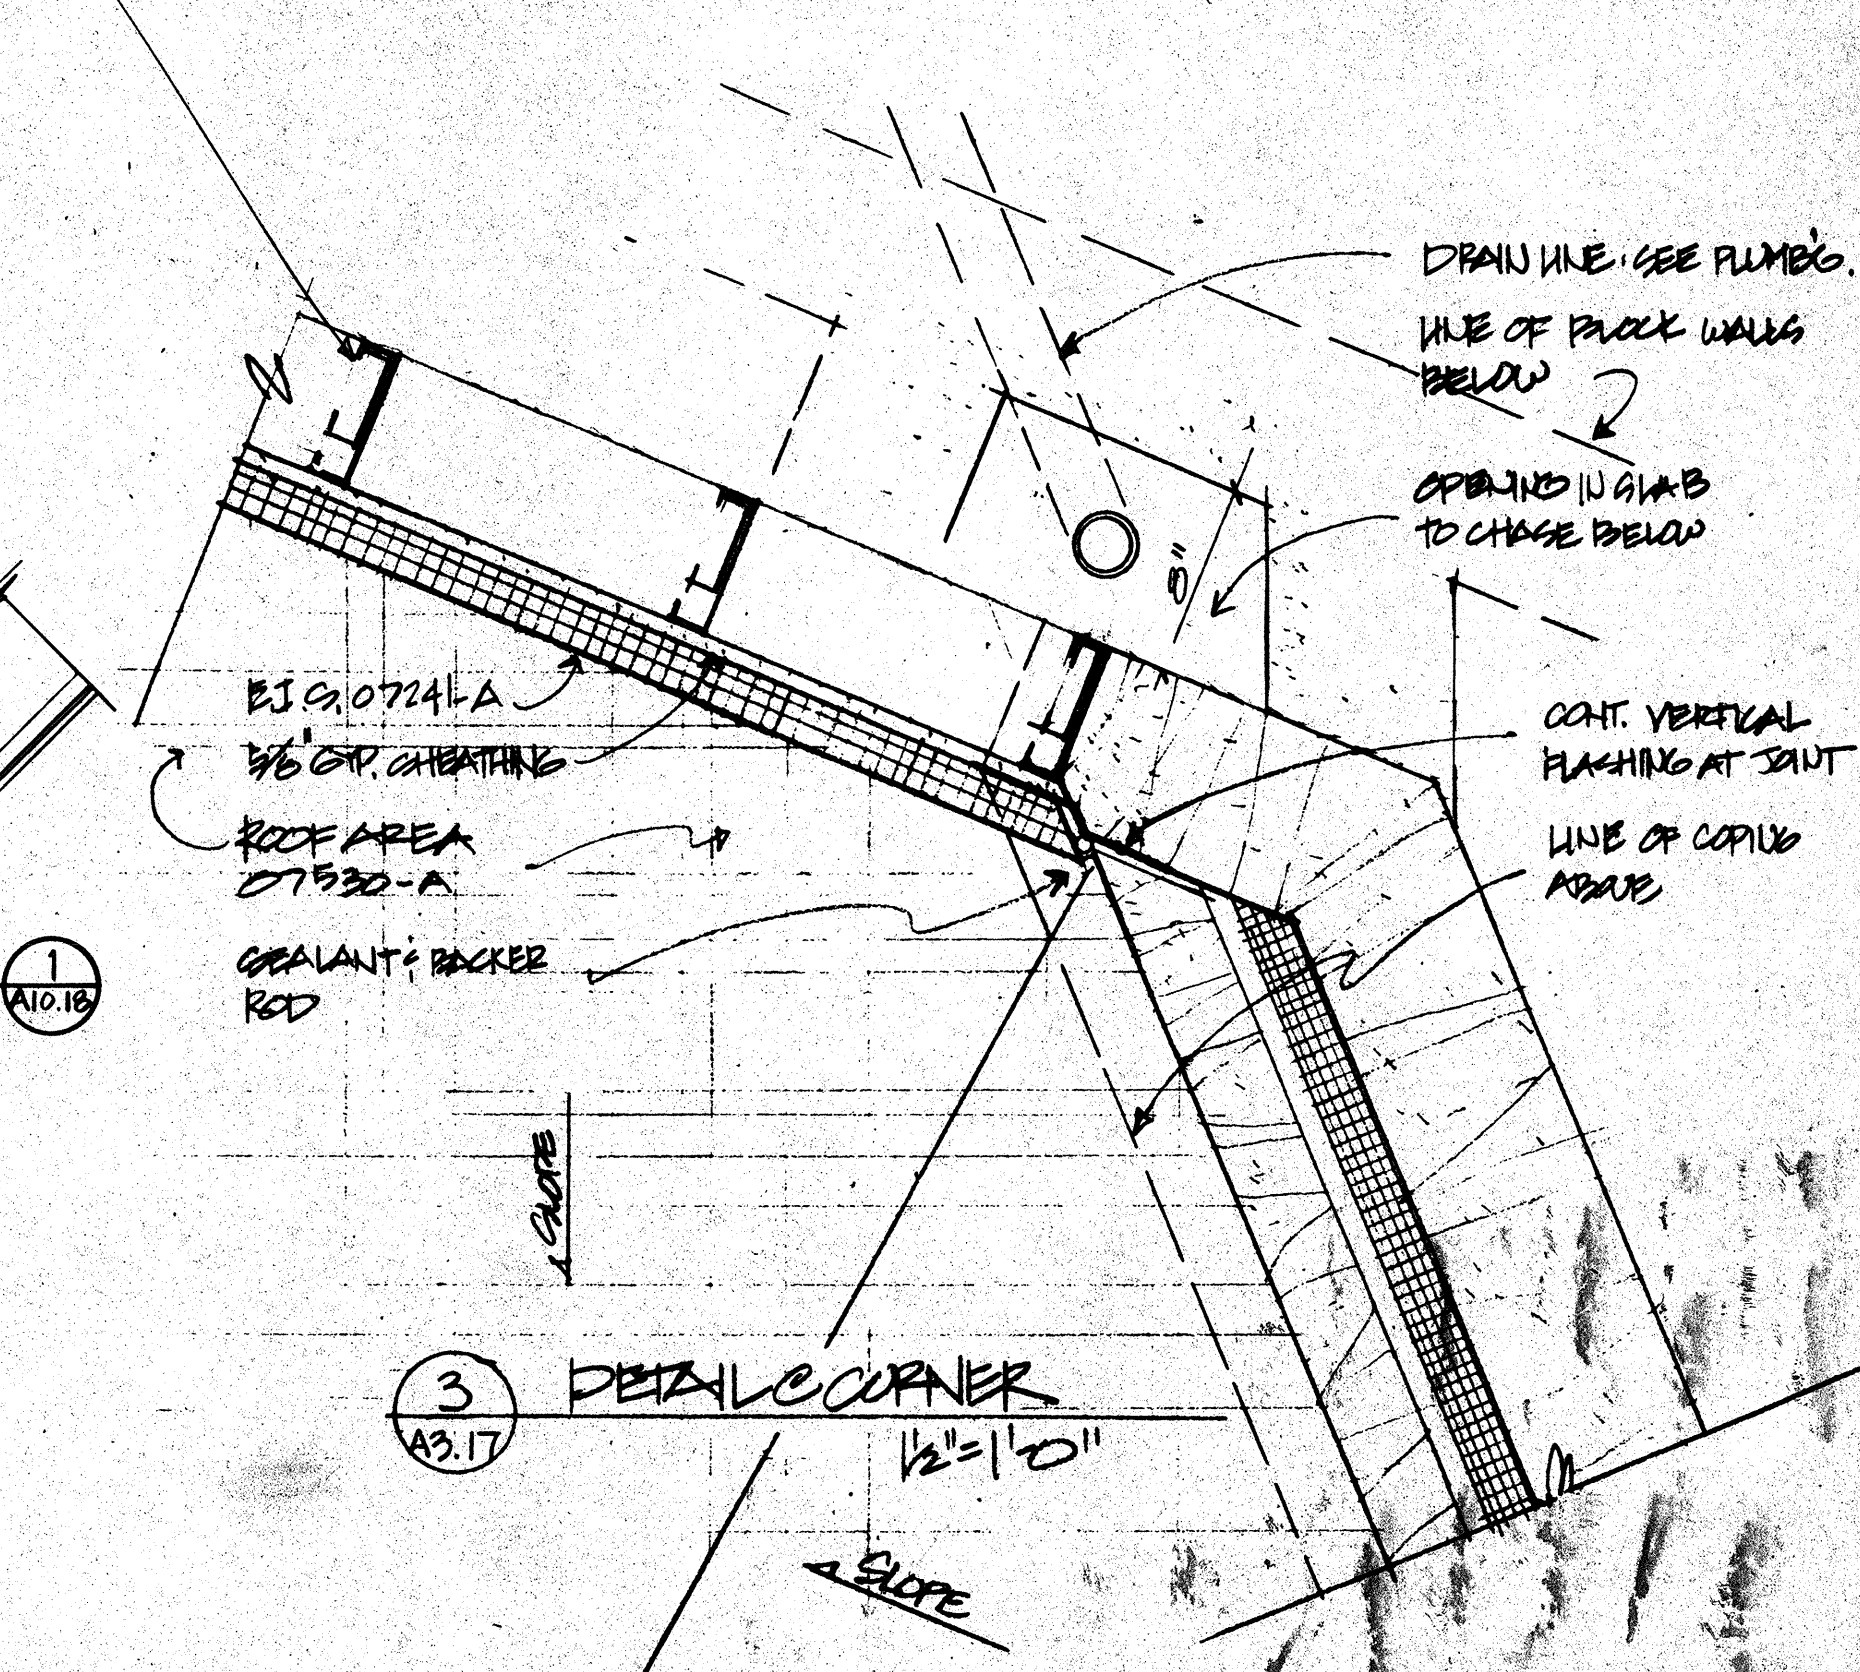

3 DETAIL CORNER
1/2" = 1'-0"

PROJECT RECAP

1 MEDICAL HOUSING UNIT - CELL TIER FLOOR PLAN
SCALE: 1/8" = 1'-0"

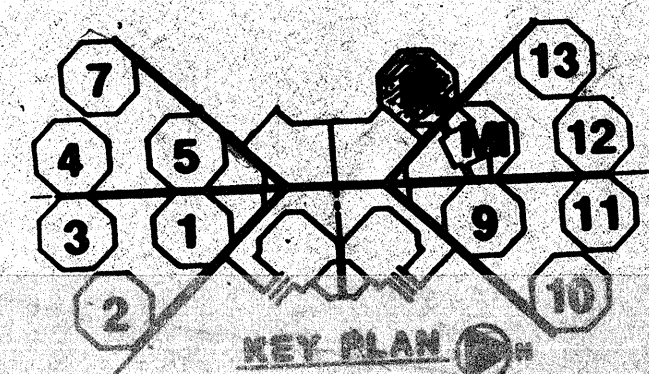

ROSSER FABRAP INTERNATIONAL

ROSSER FABRAP INTERNATIONAL, Inc.
Civil Justice Architecture, Technology, Planning, Interiors,
Mechanical, Electrical, Plumbing, Security, & Civil Engineering

Atlanta Savannah Tampa

ROSSER FABRAP INTERNATIONAL

ROSSER FABRAP INTERNATIONAL, Inc.
Civil Justice Architecture, Technology, Planning, Interiors,
Mechanical, Electrical, Plumbing, Security, & Civil Engineering

Atlanta Savannah Tampa

WEST - VALLEY - DETENTION - CENTER

FOR THE COUNTY OF SAN BERNARDINO, CALIFORNIA

HARRY MAYS, COUNTY ADMINISTRATION OFFICER

FLOYD TIDWELL, SHERIFF

BOARD OF SUPERVISORS

John J. Jaramila, Chairman, First District

Richard C. Jaramila, Second District

Robert J. Jaramila, Third District

Robert J. Jaramila, Fourth District

JUSTICE SYSTEMS INCORPORATED

Criminal Justice Operations, Programming

JOHNSON & NIELSEN

Structural Engineering


Job No. 00053.04

Date 10/7/00


A3.17

10/7/00


A3.17

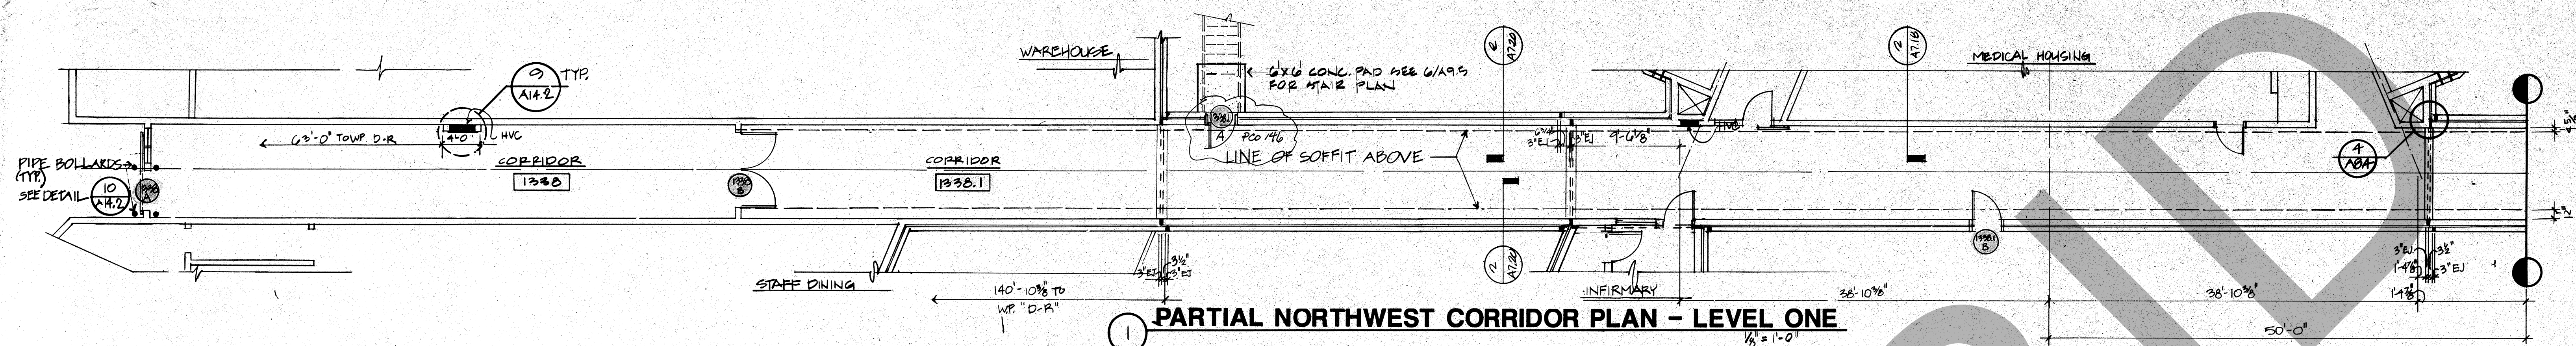

1 PARTIAL NORTHWEST CORRIDOR PLAN - LEVEL ONE
1/8" = 1'-0"

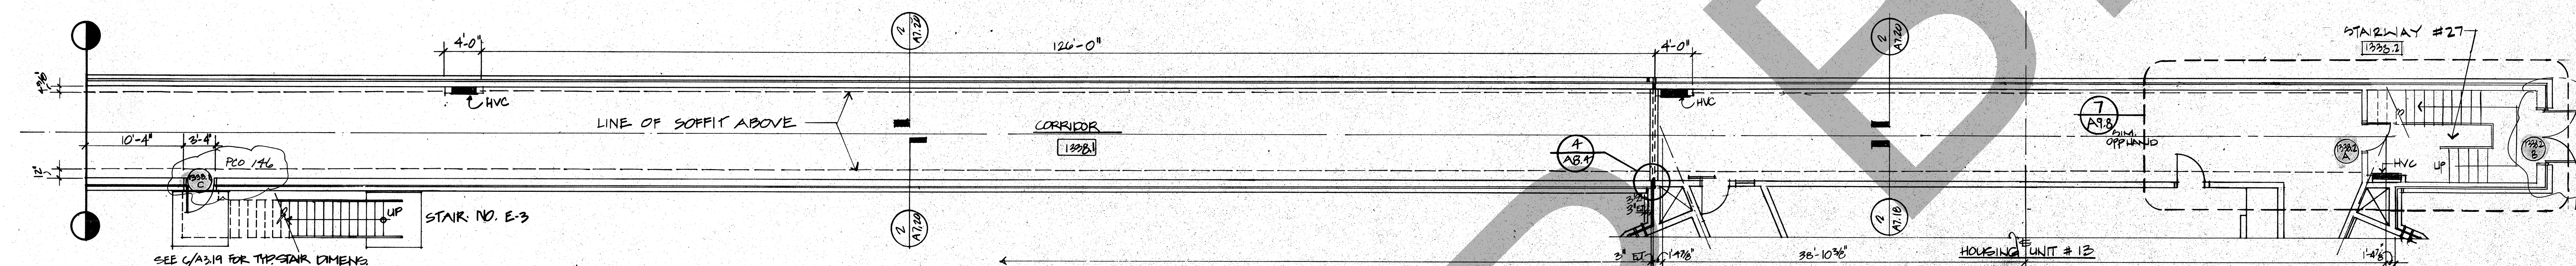


2 PARTIAL NORTHWEST CORRIDOR PLAN - LEVEL ONE
1/8" = 1'-0"

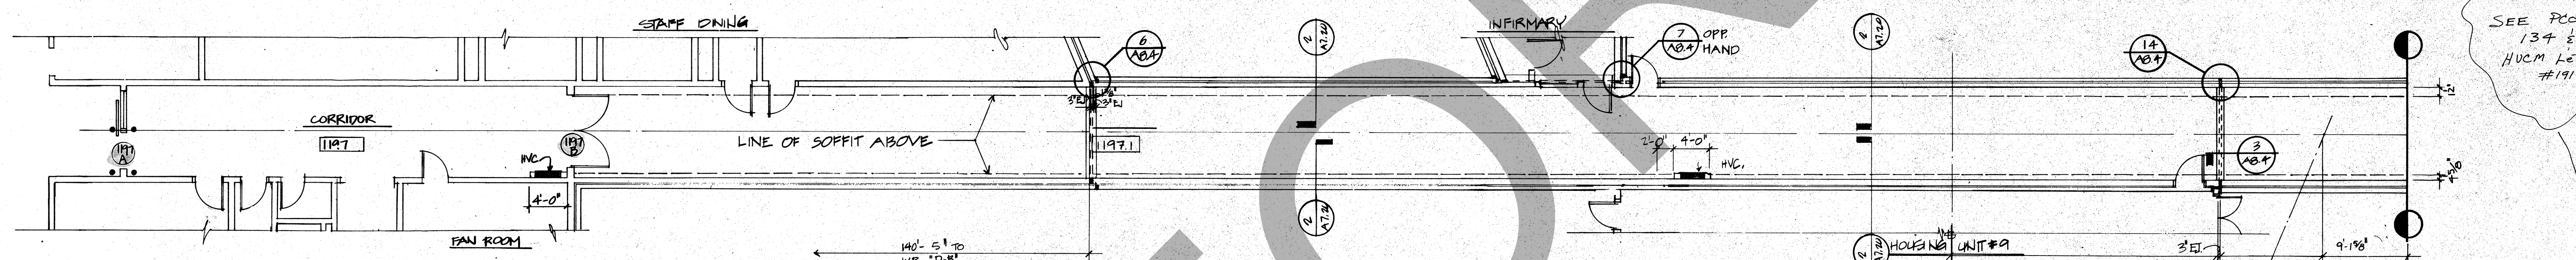


3 PARTIAL NORTH CENTRAL CORRIDOR PLAN - LEVEL ONE
1/8" = 1'-0"



4 PARTIAL NORTH CENTRAL CORRIDOR PLAN - LEVEL ONE
1/8" = 1'-0"

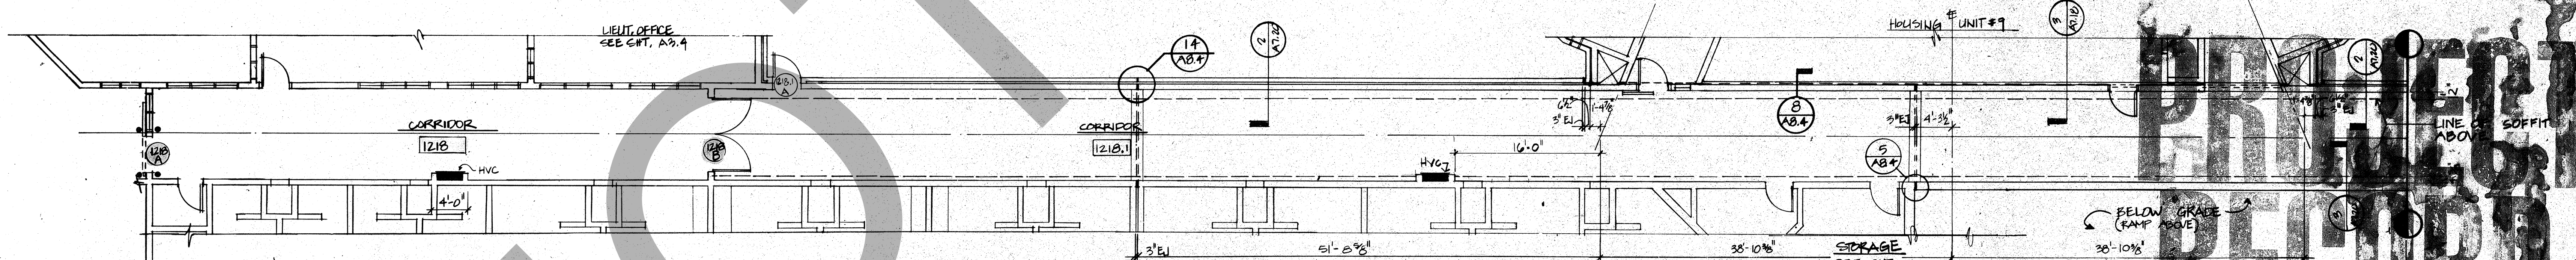

5 PARTIAL NORTHEAST CORRIDOR PLAN - LEVEL ONE
1/8" = 1'-0"

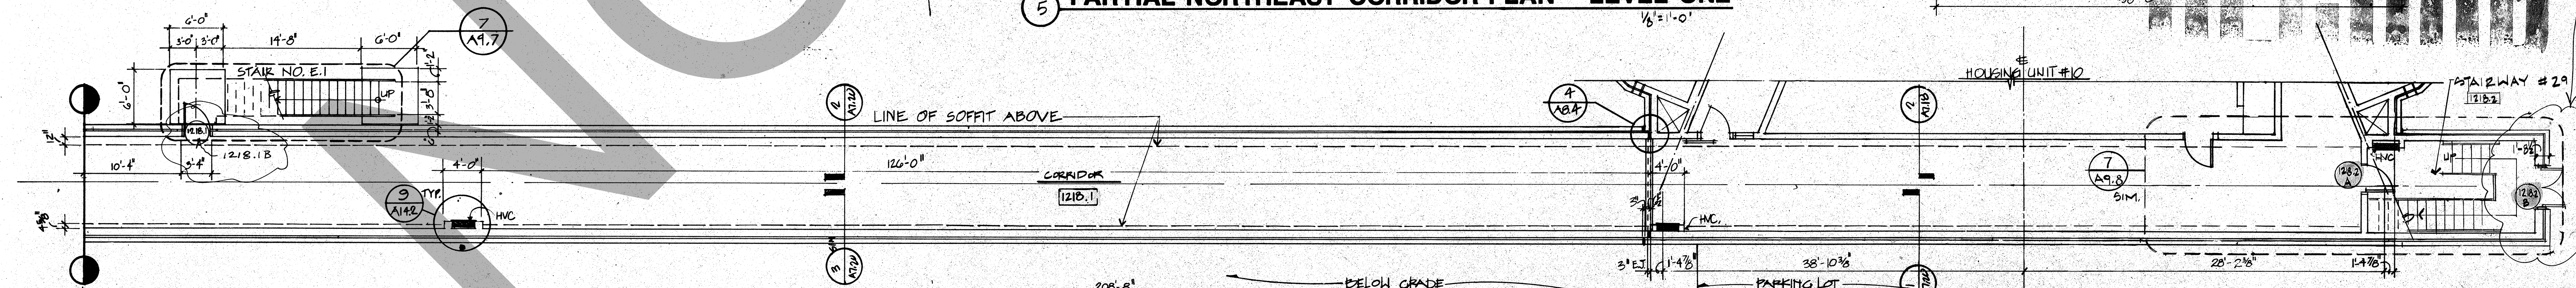

6 PARTIAL NORTHEAST CORRIDOR PLAN - LEVEL ONE
1/8" = 1'-0"

ROSSER FABRAP INTERNATIONAL

ROSSER FABRAP INTERNATIONAL, Inc.
Comprehensive Services for Building
Design and Technology
Atlanta Savannah Tampa

ROSSER FABRAP INTERNATIONAL

Criminal Justice Architecture, Technology, Planning, Interiors,
Mechanical, Electrical, Plumbing, Security, & Civil Engineering.

JUSTICE SYSTEMS INCORPORATED

Criminal Justice Operations, Programming
Johnson & Nielsen
Spectrum Engineering

WEST - VALLEY - DETENTION - CENTER

FOR THE COUNTY OF SAN BERNARDINO - CALIFORNIA

HARRY MAYS, COUNTY ADMINISTRATION OFFICER

FLOYD TIDWELL, SHERIFF

BOARD OF SUPERVISORS
John J. Jones, Chairman, First District
Barbara L. Green, Second District
Richard A. Hernandez, Third District
Robert J. Hernandez, Fourth District

CORRIDORS

NORTH FLOOR PLAN

LEVEL 1

JOHN NO. 020528.04
DATE 10/17/02
A3.19

FOR CONSTRUCTION

PLAN NORTH