



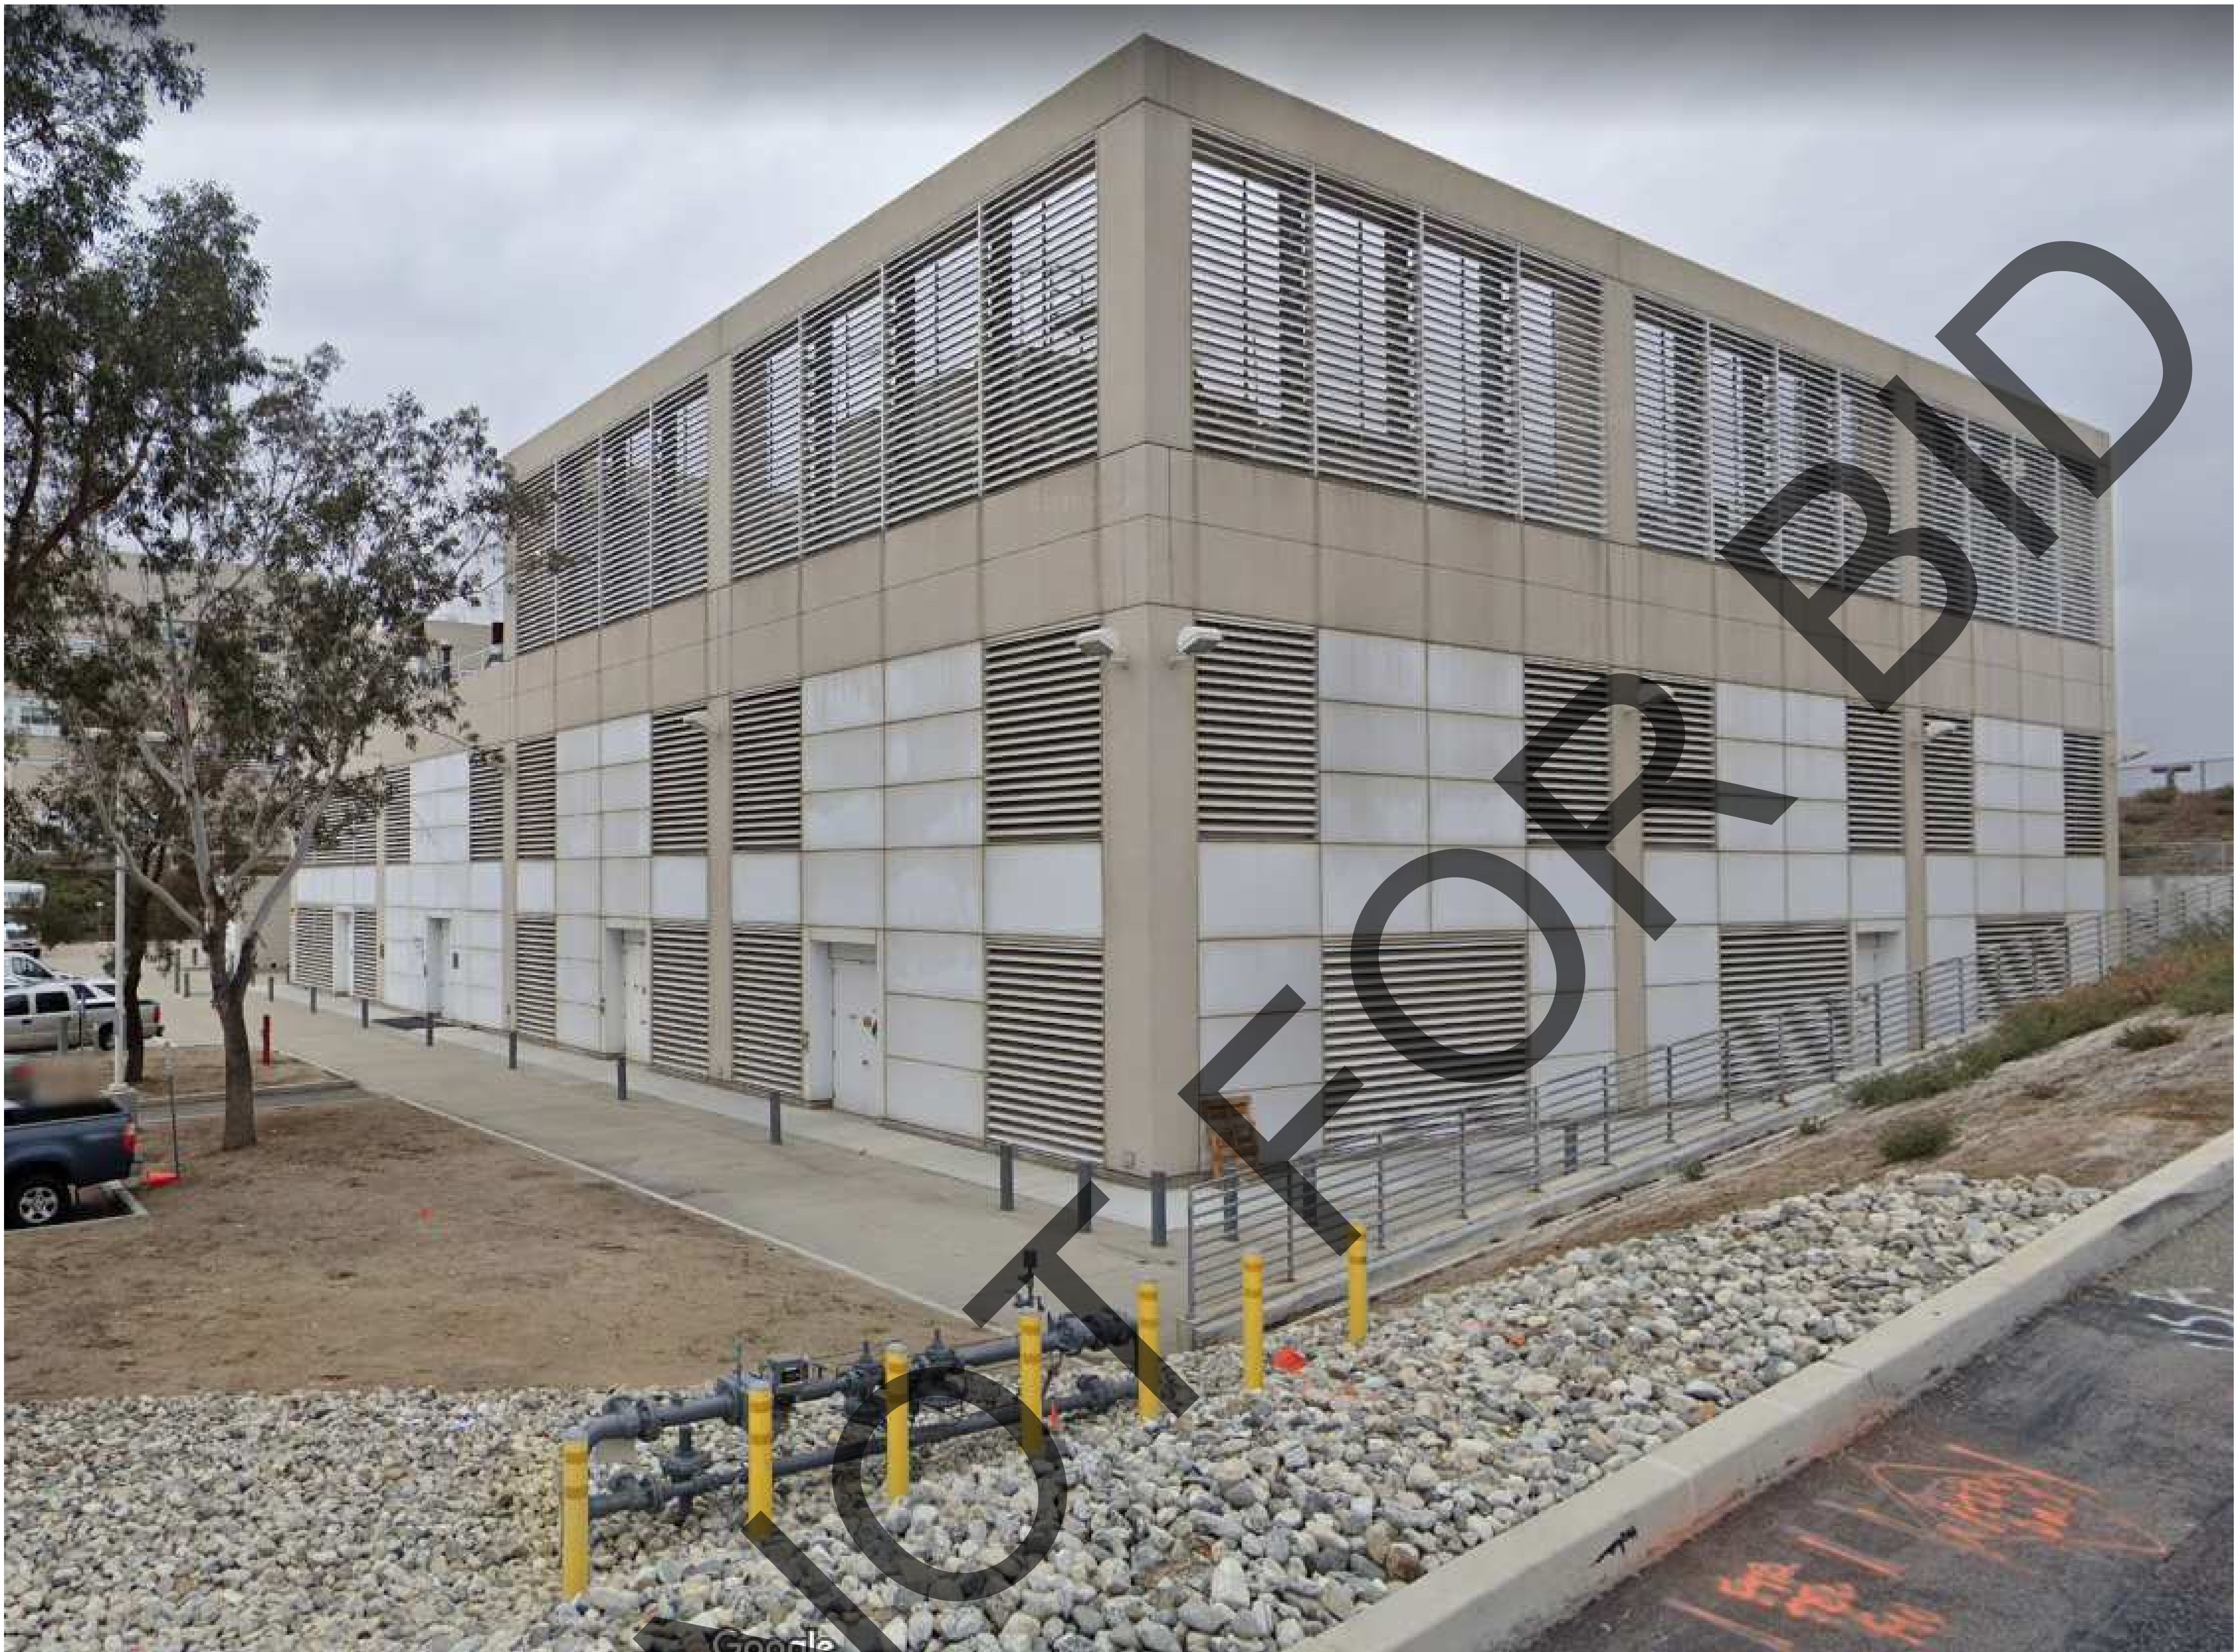

SAN BERNARDINO COUNTY
PROJECT AND FACILITIES
MANAGEMENT DEPARTMENT

385 NORTH ARROWHEAD AVENUE, 3RD FLOOR
SAN BERNARDINO, CA 92415-0184

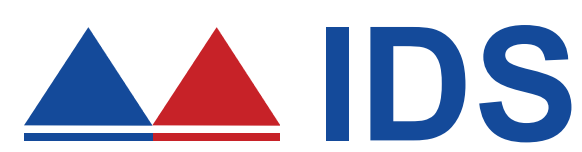

IDS GROUP

1 PETERS CANYON ROAD, SUITE 130
IRVINE, CA 92606
TEL: 949-387-8500, FAX: 949-387-0800

REPLACEMENT DEAERATOR

400 N PEPPER AVE, COLTON, CA 92324

A PROJECT FOR: ARROWHEAD REGIONAL MEDICAL CENTER | PROJECT NUMBER: WBSE# 10.10.0847, CIP# 20-011, IDS# 22X066.02

S230562-36-00 HCAI BC 2 SUBMITTAL | JUNE 28, 2023

SAN BERNARDINO COUNTY


ARROWHEAD REGIONAL MEDICAL CENTER

REPLACEMENT DEAEERATOR 1

ABBREVIATIONS

AFF	ABOVE FINISHED FLOOR	(E)	EXISTING	IN	INCH / INCHES	QTY	QUANTITY
ACST	ACOUSTIC	EXIST	EXISTING	INFO	INFORMATION	QT	QUARRY TILE
ACT	ACOUSTIC CEILING TILE	ETR	EXISTING TO REMAIN	ID	INSIDE DIAMETER		
APC	ACOUSTIC PANEL CEILING	EA	EACH	INS	INSULATED	RAD	RADIUS
AWP	ACOUSTIC WALL PANEL	E	EAST	INSUL	INSULATION	RDWD	REDWOOD
AWT	ACOUSTIC WALL TREATMENT	EQ	EQUAL	IR	INTEGRAL RESILIENT BASE	REF	REFRIGERATOR
ADJ	ADJUSTABLE	EQPT	EQUIPMENT	INT	INTERIOR	REINF	REINFORCED
A/C	AIR CONDITIONING	EWC	ELECTRIC WATER COOLER	ILSM	INTERIM LIFE SAFETY MEASURE	REBAR	REINFORCING BAR
AHU	AIR HANDLING UNIT	ELEC	ELECTRICAL			REV	REVISION
ALT.	ALTERNATE	ELEV	ELEVATOR	JAN	JANITOR	RO	ROUGH OPENING
AL	ALUMINUM	EMERG	EMERGENCY	JT	JOINT	RM	ROOM
AB	ANCHOR BOLT	EG	END GUARD	JST	JOIST	RA	RETURN AIR
APPROX.	APPROXIMATE	ENGR	ENGINEER			RD	ROOF DRAIN
ARCH	ARCHITECT	EQUIP	EQUIPMENT	KG	KILOGRAM	RS	RESILIENT SHEET FLOORING
ASPH	ASPHALT	EQPT	EQUIPMENT	KD	KNOCK-DOWN FRAME	REQ	REQUIRED
ASSY	ASSEMBLY	EXP	EXPANSION				
AUTO	AUTOMATIC	EB	EXPANSION BOLT	LL	LIVE LOAD	SS	STAINLESS STEEL
AWN	AWNING	EJ	EXPANSION JOINT	LAB	LABORATORY	SMS	SHEET METAL SCREW
A/V	AUDIO-VISUAL	EXPC	EXPOSED CONSTRUCTION	LAV	LAVATORY	SC	SOLID CORE
		EXT	EXTERIOR	LAM	LAMINATE	SCH	SCHEDULE
		EIFS	EXTERIOR INSULATION AND FINISH SYSTEM	LT	LAUNDRY CHUTE	SECT	SECTION
				LT	LIGHT	SHTHG	SHEATHING
				LTWT	LIGHT WEIGHT	SHT	SHEET
				LB	POUNDS	SLV	SHORT LEG VERTICAL
				LIN. DIFF.	LINEAR DIFFUSER	SPR	SINGLE PLY ROOFING
				LP	LOW POINT	SL GL DR	SLIDING GLASS DOOR
				LLV	LONG LEG VERTICAL	SP	SOLID POLYMER
				LVT	LUXURY VINYL TILE	SAP	SOUND ABSORPTIVE PANEL
						SPECS	SPECIFICATIONS
				M	METER	SQ	SQUARE
				MM	MILLIMETER	SQ FT	SQUARE FEET
				MACH	MACHINE	SAV	STAIN AND VARNISH
				MAT	MATERIAL	STD	STANDARD
				MH	MANHOLE	STL	STEEL
				MFD	MANUFACTURED	STLC	STEEL CHANNEL
				MFR	MANUFACTURER	SEJ	SEISMIC JOINT
				MT	MARBLE TILE	SJ	STEEL JOIST
				MK	MARK	STOR	STORAGE
				MB	MARKER BOARD	STRUCT	STRUCTURAL
				MO	MASONRY OPENING	SUSP	SUSPENDED
				MAX	MAXIMUM	SW	SWITCH
				FS	FLOOR SINK	S	SWITCH
				MECH	MECHANICAL	S	SOUTH
				MC	MEDICINE CHEST	SYM	SYMMETRICAL
				MEMB	MEMBRANE	SIM	SIMILAR
				MTL	METAL		
				MFTSM	MINERAL-FILLED THERMOPLASTIC	TBD	TO BE DETERMINED
						TB	TACKBOARD
						TELE	TELEPHONE
						TG	TEMPERED GLASS
						TEMP	TEMPORARY
						TLT	TOILET
						TOS	TOP OF SLAB
						TO	TOP OF
						TYP	TYPICAL
				(N)	NEW	U/S	UNDERSIDE
				N	NORTH	UC	UNDER CABINET
				N/A	NOT APPLICABLE	UNFIN	UNFINISHED
				NF	NATURAL FINISH	U.N.O.	UNLESS NOTED OTHERWISE
				NOM	NOMINAL		
				NIC	NOT IN CONTRACT		
				NTS	NOT TO SCALE		
				NO.	NUMBER		
				OF/OI	OWNER FURNISHED / OWNER INSTALLED	VF/M	VENDOR FURNISHED / VENDOR INSTALLED
				OF/CI	OWNER FURNISHED / CONTRACTOR INSTALLED	VF/CI	VENDOR FURNISHED / CONTRACTOR INSTALLED
				OFF	OFFICE	VAC	VACUUM
				OC	ON CENTER	VB	VAPOR BARRIER
				OC	ON CENTER	VERT	VERTICAL
				OPP	OPPOSITE	VFI	VERIFY IN FIELD
				OH	OPPOSITE HAND	VEST	VESTIBULE
				ORCH	ORCHESTRA	VCT	VINYL COMPOSITION TILE
				OP	ORNAMENTAL PAINT	VWC	VINYL WALL COVERING
				OPL	ORNAMENTAL PLASTER		
				OD	OUTSIDE DIAMETER	W/	WITH
						W/O	WITHOUT
						WC	WASH CLOSET
						WD	WOOD
						WT	WEIGHT
						WP	WATER PROOF
						WRB	WATER RESISTANT CEMENT BOARD
						WWF	WELDED WIRE FRAME
						WWM	WELDED WIRE MESH
						WF	WIDE FLANGE
						W	WEST
						WD	WOOD
						YD	YARD

VICINITY MAP

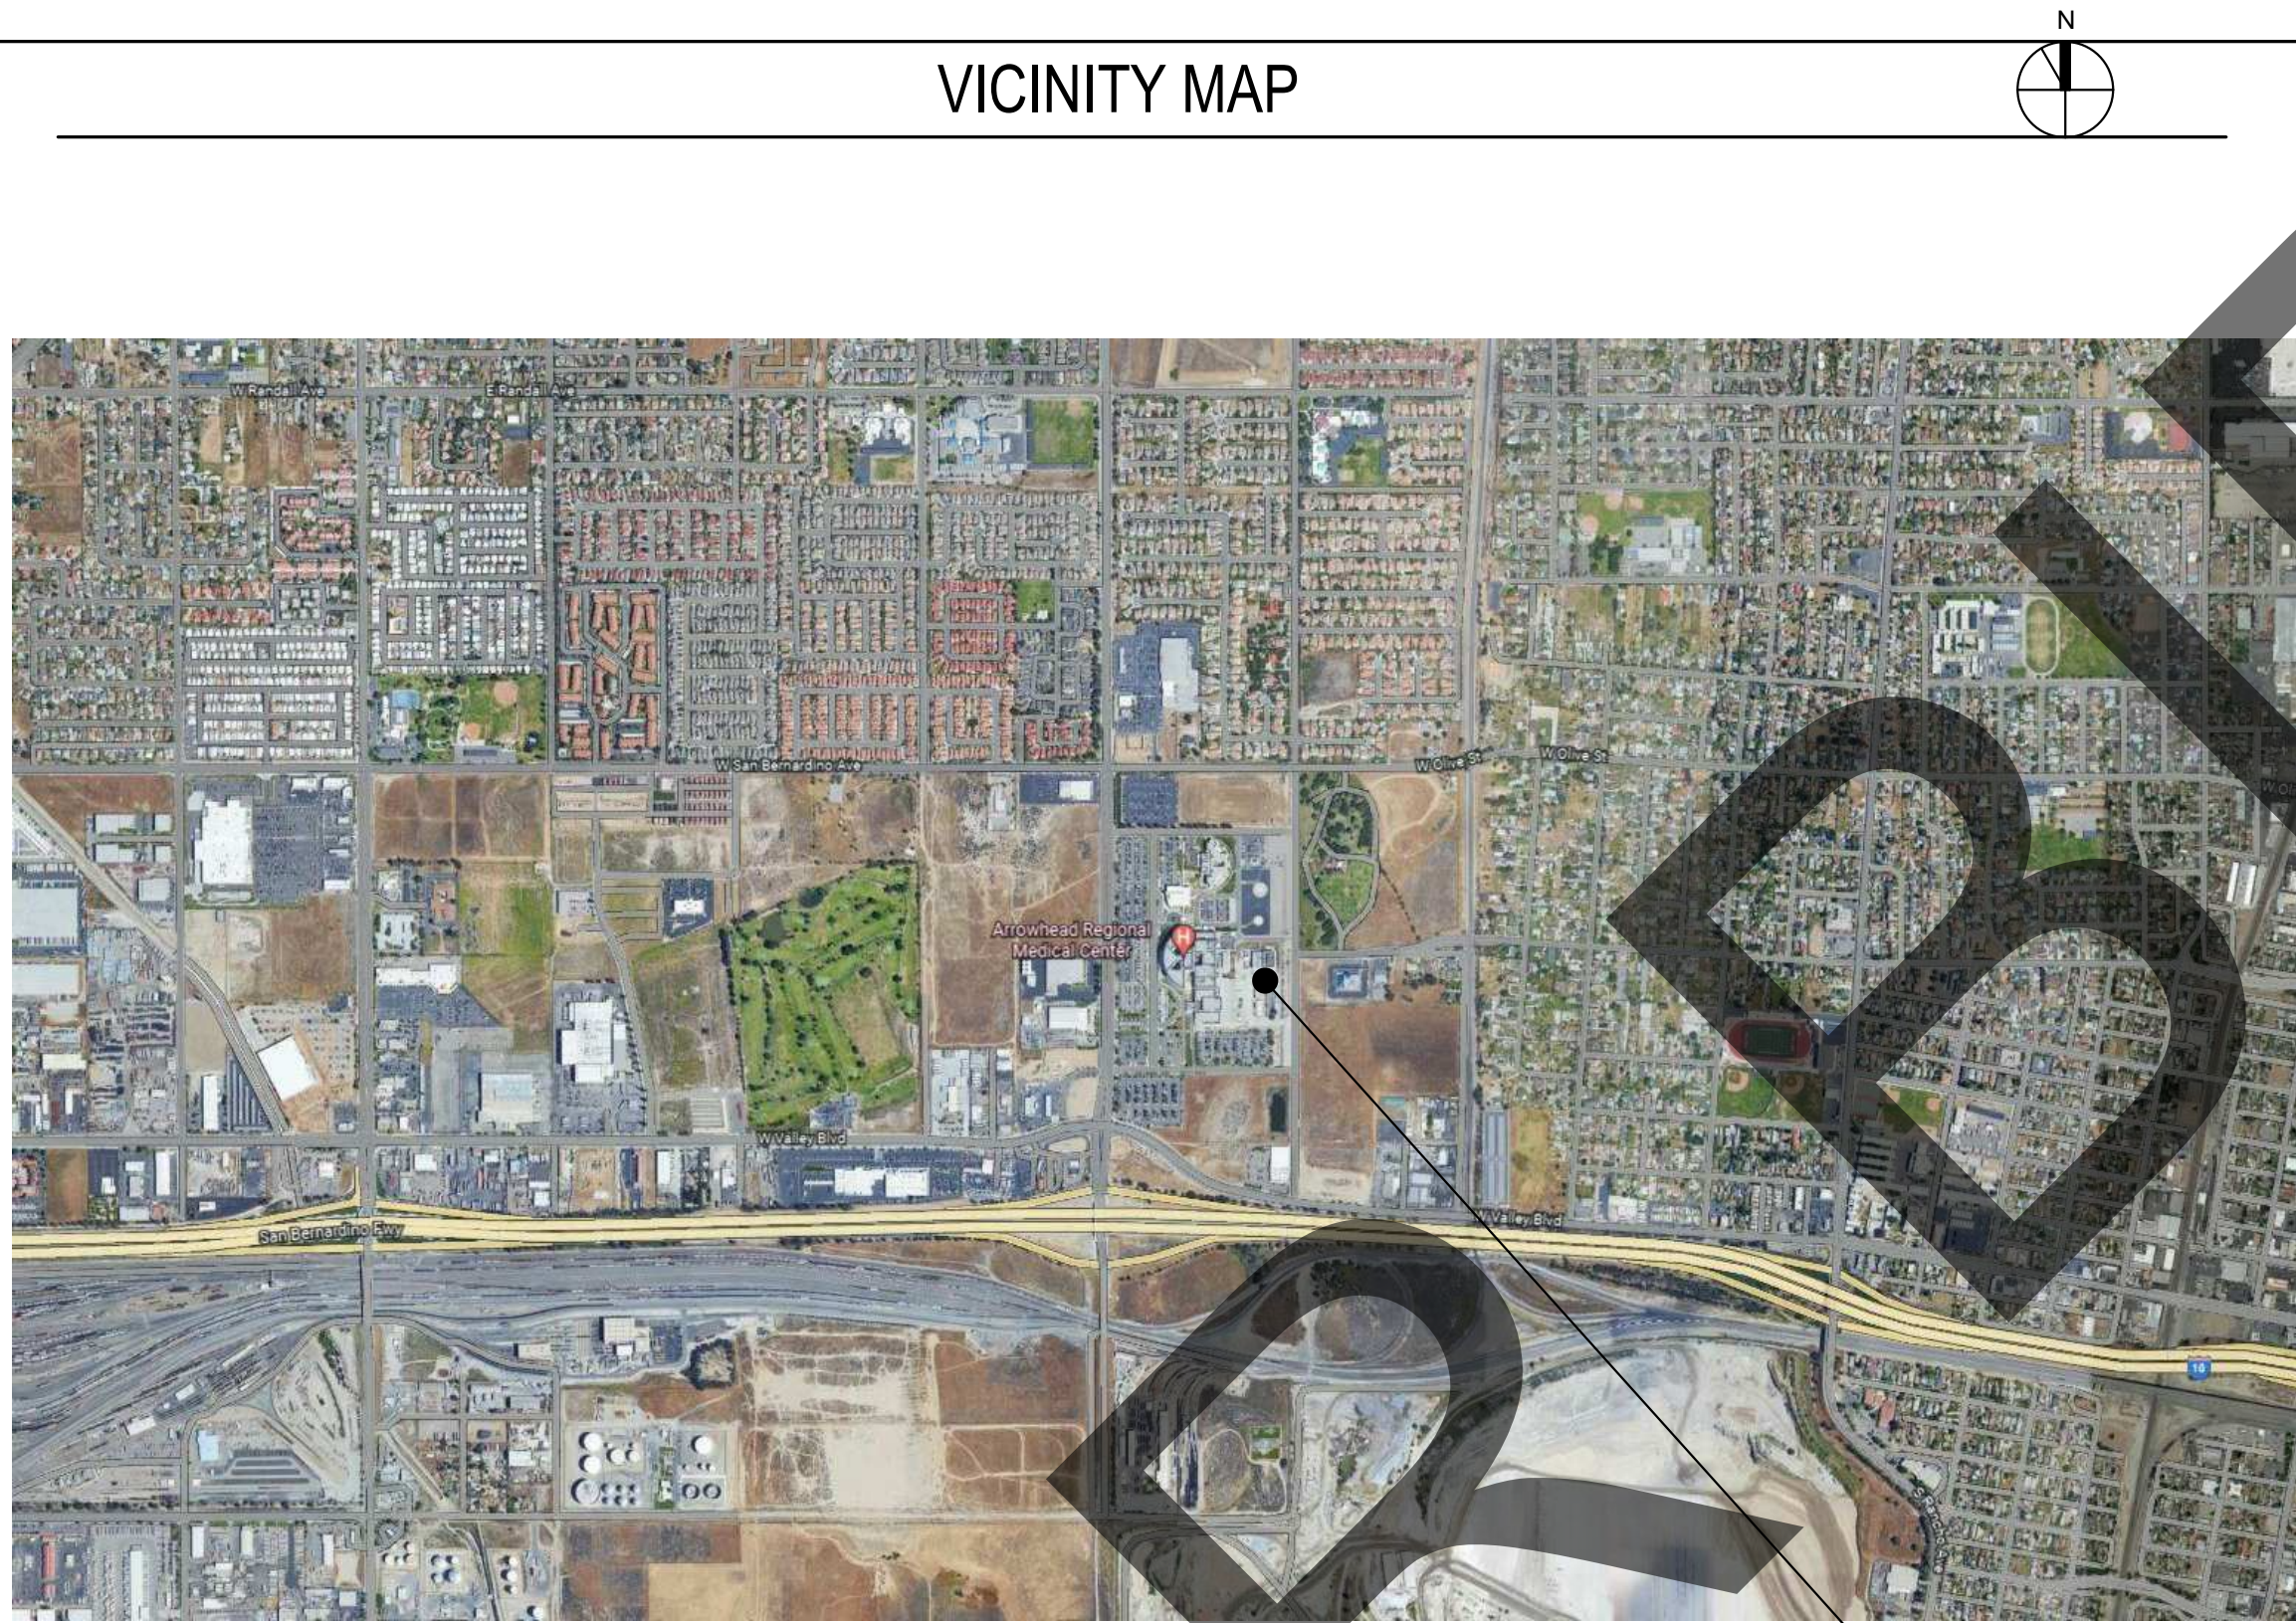

OWNER

SAN BERNARDINO PROJECT AND FACILITY MANAGEMENT
388 NORTH ARROWHEAD AVENUE,
3RD FLOOR SAN BERNARDINO,
CA 92415-0184

NICHOLAS HO, PROJECT MANAGER
PHONE: 949-387-8500
EMAIL: Nicholas.Ho@res.sbcounty.gov

DESIGN TEAM


AOR
JOSEPH MACDONALD
IDS GROUP INC.
1 PETERS CANYON ROAD, SUITE 130
IRVINE, CALIFORNIA 92606
PHONE: 949-387-8500 EXT 157

SEOR
RAMI ELHASSAN
IDS GROUP INC.
1 PETERS CANYON ROAD, SUITE 130
IRVINE, CALIFORNIA 92606
PHONE: 949-387-8500 EXT 113

MEOR
DARREN SMITH
IDS GROUP INC.
1 PETERS CANYON ROAD, SUITE 130
IRVINE, CALIFORNIA 92606
PHONE: 949-387-8500 EXT 434

EOOR
MANNY OCAMPO
IDS GROUP INC.
1 PETERS CANYON ROAD, SUITE 130
IRVINE, CALIFORNIA 92606
PHONE: 949-387-8500 EXT 313

FACILITY MAP

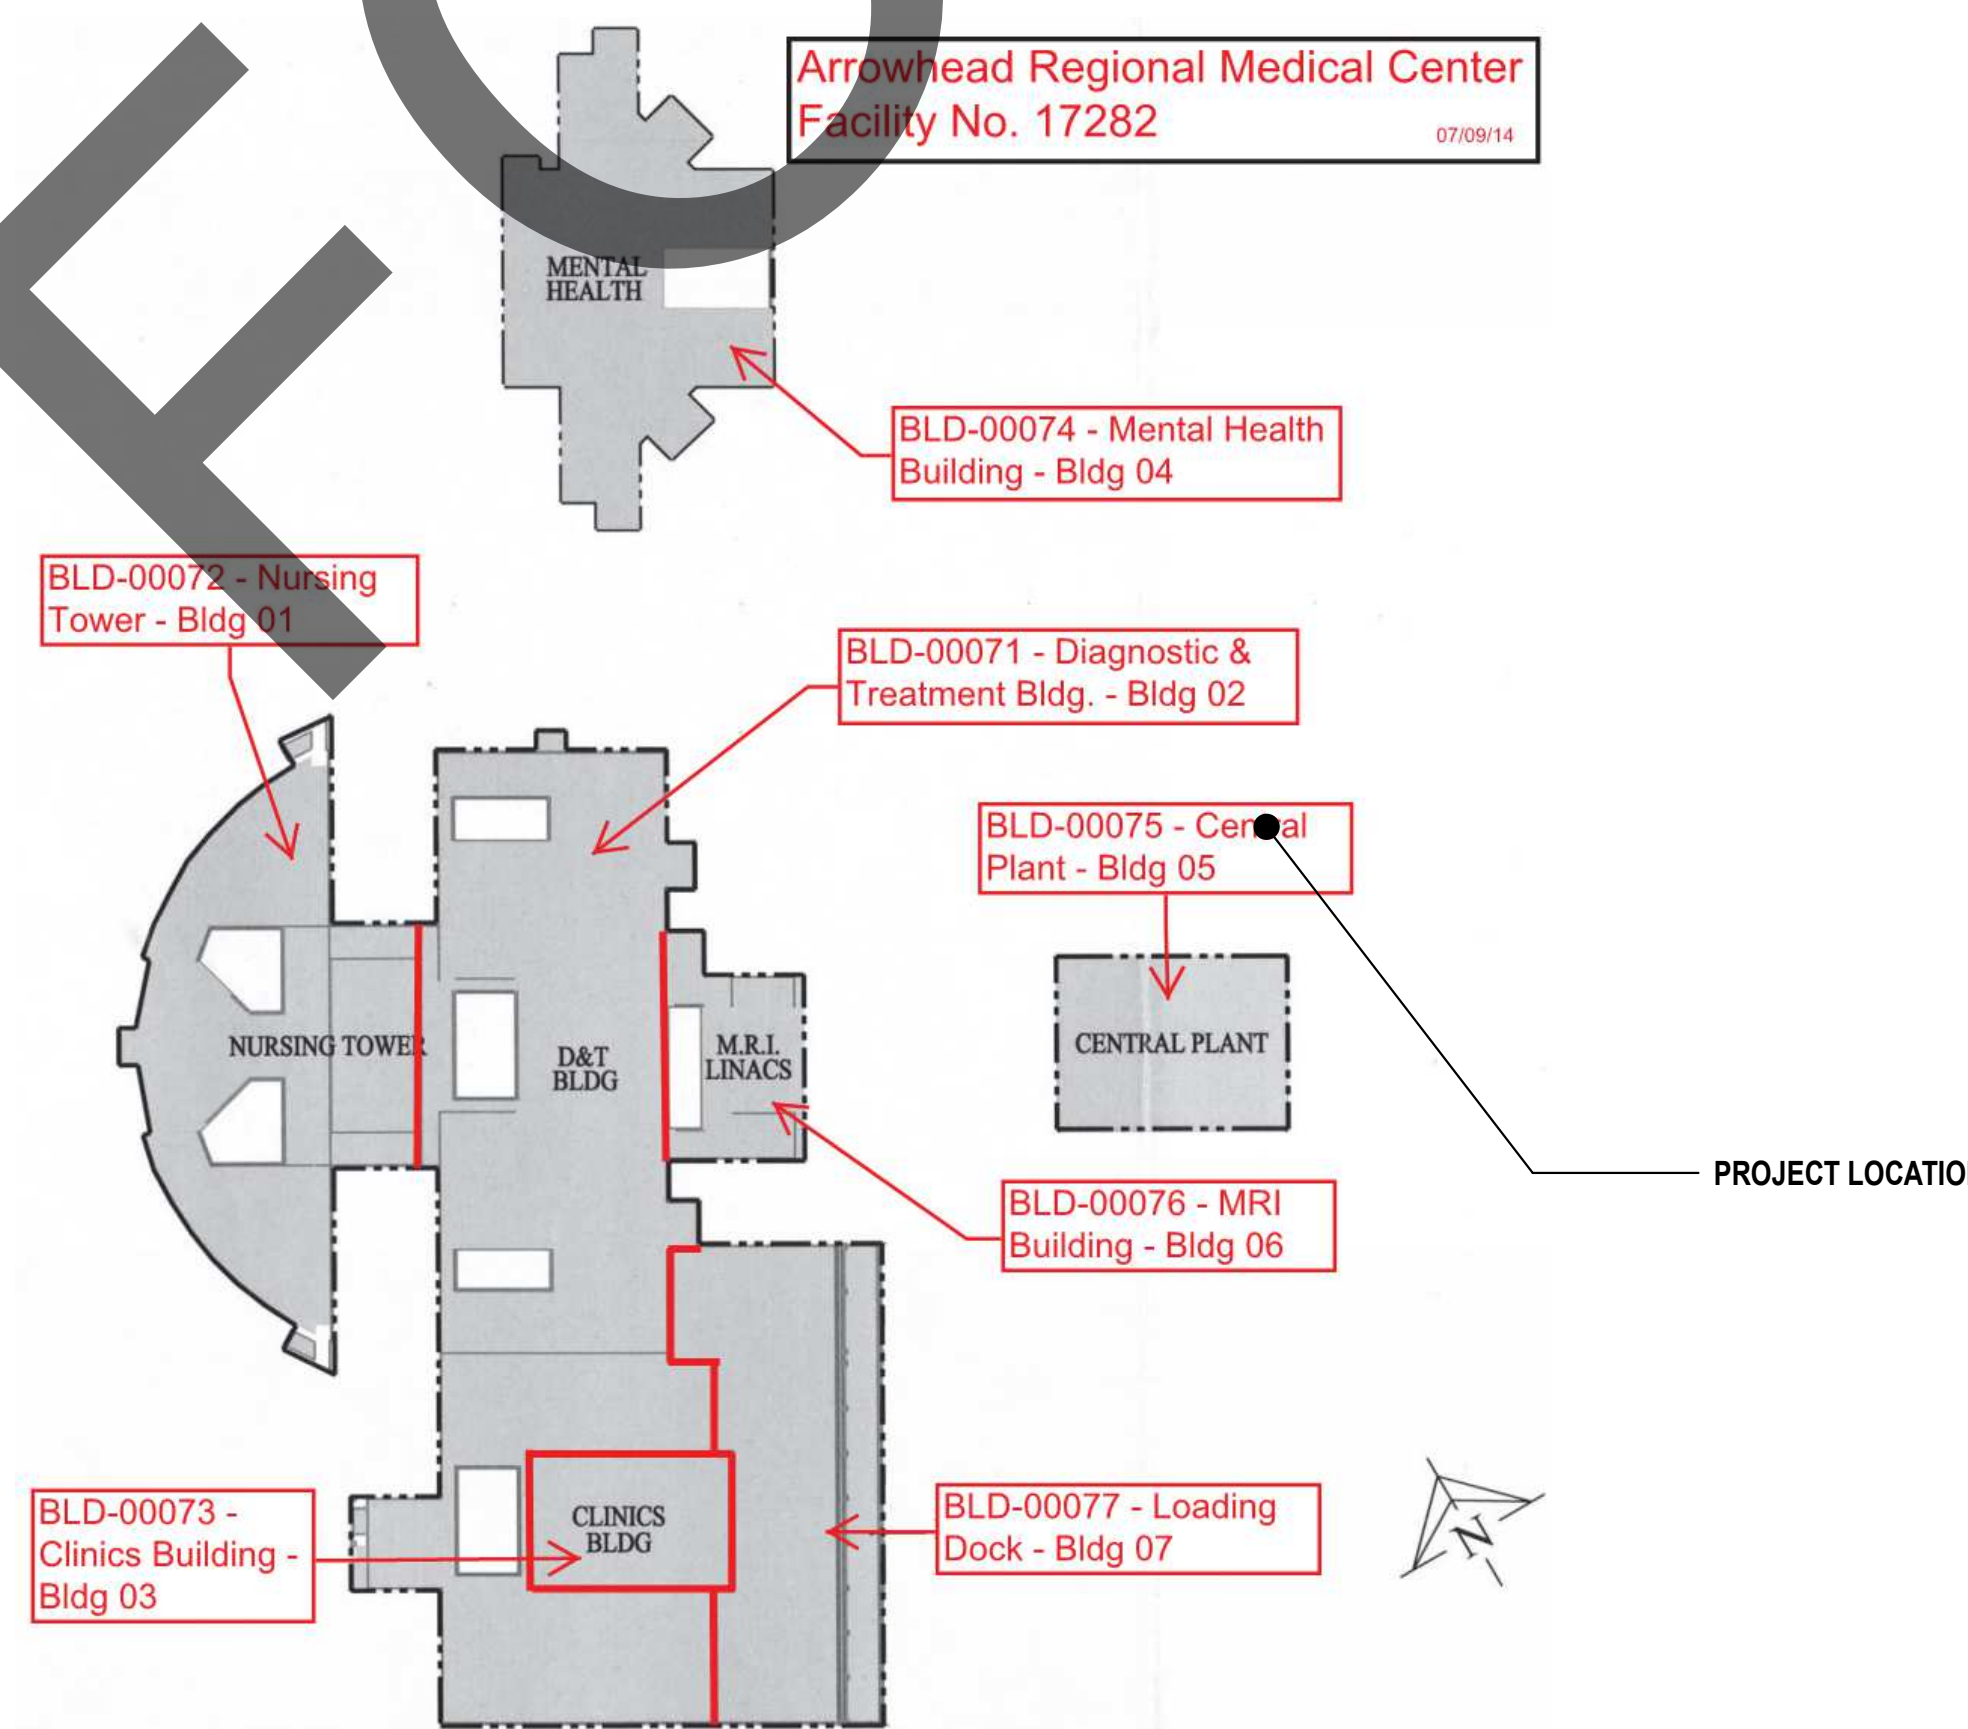

ENFORCEABLE CODES

ALL WORK PERTAINING TO AND ALL MATERIALS SUPPLIED FOR EXECUTING AND COMPLETING THIS CONTRACT SHALL COMPLY WITH PROVISIONS SPECIFIED IN THE CONTRACT DOCUMENTS AND WITH ALL APPLICABLE LAWS, REGULATIONS AND ORDINANCES GOVERNING WORK INCLUDING, BUT NOT NECESSARILY LIMITED TO, THOSE OF:

TITLE 24, CALIFORNIA CODE OF REGULATIONS

2022	CALIFORNIA ADMINISTRATIVE CODE (CAC), INCLUDING SECTIONS 7-113 & 7-115
2022	CALIFORNIA BUILDING CODE (CBC), INCLUDING SECTION 107
2022	CALIFORNIA ELECTRICAL CODE (CEC)
2022	CALIFORNIA MECHANICAL CODE (CMC)
2022	CALIFORNIA PLUMBING CODE (CPC)
2022	CALIFORNIA ENERGY CODE
2022	CALIFORNIA FIRE CODE (CFC)

TITLE 19, CALIFORNIA CODE OF REGULATIONS
DIV. 1 - PUBLIC SAFETY - STATE FIRE MARSHALL REGULATIONS.

APPLICABLE NATIONAL FIRE PROTECTION ASSOCIATION STANDARD
NFPA 13, 72, 99.
NFPA 101 LSC

ACCESSIBILITY

THE EXISTING HOSPITAL IS CONSIDERED ACCESSIBLE. THE PROJECT HAS NO IMPACT ON EXTERIOR PATHS OF TRAVEL OR CAMPUS ELEMENTS SUCH AS PARKING. SEE SHEET G-100 FOR ACCESSIBLE PATH OF TRAVEL ROUTING FROM FROM THE PUBLIC WAY, TO THE EXTERIOR PRIMARY ENTRANCE OF THE BUILDING TO THE PROJECT SCOPE OF WORK AREA.

DEFERRED SUBMITTALS

NOT APPLICABLE

SYMBOL LEGEND

	EXISTING PARTITION / WALL		DOOR TAG		DETAIL CUT
	DEMO PARTITION / WALL		WINDOW TAG		WALL SECTION CUT
	NEW PARTITION / WALL		KEYNOTE		WALL TYPE TAG
	EXISTING DOOR		EQUIPMENT TYPE TAG		CEILING HEIGHT TAG
	NEW DOOR		FINISH MATERIAL TAG		REVISION TAG
	ROOM NAME		GRID COLUMN CENTER LINE		SPOT ELEVATION
	ROOM NAME / NUMBER / AREA		NORTH ARROW		VIEW NAME
	OFFICE		ALIGN ARROW SYMBOL		REFERENCE SHEET
	ROOM NUMBER		INTERIOR ELEVATION VIEW		
	CEILING HEIGHT				
	ROOM FINISHES CODE				
	ROOM AREA				

APPROVAL



CLIENT



SAN BERNARDINO COUNTY
PROJECT AND FACILITIES
MANAGEMENT DEPARTMENT

385 NORTH ARROWHEAD AVENUE, 3RD FLOOR SAN
BERNARDINO, CA 92415-0184

PROJECT NAME

**ARMC
DEAEERATOR #1
REPLACEMENT**

PROJECT NO.
WSE # 10.10.0847
CIP # 20-011
HCAI # 9230662-36-00

FACILITY NO.
17282
BUILDING NO.
BLD-00075 CENTRAL PLANT

400 N. PEPPER AVENUE
COLTON, CA 92324-1801

ENGINEER/ARCHITECT



IDS GROUP

1 PETERS CANYON ROAD, SUITE 130
IRVINE, CA 92606
TEL: 949-387-8500, FAX: 949-387-0800

STAMP



STAMP



ISSUE

REV.	DESCRIPTION	DATE
	HCAI SUBMITTAL	03/01/23
A	HCAI BC 1	06/13/23
B	HCAI BC 2	07/28/23

PROJECT IDENTIFICATION

THE ORIGINAL SIZE OF THIS SHEET IS 30" X 42"
THESE DRAWINGS AND SPECIFICATIONS ARE THE PROPERTY AND
COPYRIGHT OF IDS GROUP AND SHALL NOT BE USED ON ANY
OTHER PROJECT OR LOCATIONS EXCEPT AS DESCRIBED ON THE
DRAWINGS, WITHOUT THE WRITTEN AGREEMENT WITH IDS GROUP.

IDS PROJECT NO.	22X66.02
DRAWN BY	CKC
CHECKED BY	CKC
APPROVED BY	JHM

SHEET TITLE

**PROJECT
INFORMATION**

SHEET NUMBER

G-001

SHEET NO. OF

GENERAL NOTES

CONTRACTOR OBLIGATIONS FOR MITIGATION MONITORING AND REPORTING PROGRAM

1. THE CONTRACTOR SHALL INSTALL A VISUAL BARRIER (E.G., GREEN MESH FABRIC) ALONG THE PERIMETER OF CONSTRUCTION SITES FOR VERTICAL CONSTRUCTION PROJECTS. THIS REQUIREMENT SHALL BE SUBMITTED TO ARCHITECT AS A CONTRACTOR SUBMITTAL AND VERIFIED BY THE COMMUNITY DEVELOPMENT DEPARTMENT PRIOR TO SITE WORK.

2. DUST CONTROL: THE CONTRACTOR SHALL BE REQUIRED TO COMPLY WITH SCAQMD RULES 402 AND 403, WHICH SHALL ASSIST IN REDUCING SHORT-TERM AIR POLLUTANT EMISSIONS. SCAQMD RULE 402 REQUIRES THAT AIR POLLUTANT EMISSIONS NOT BE A NUISANCE OFF SITE. SCAQMD RULE 403 (TABLES 1, 2, AND 3 OF RULE 403) REQUIRES THAT FUGITIVE DUST BE CONTROLLED WITH THE BEST AVAILABLE CONTROL MEASURES SO THAT THE PRESENCE OF SUCH DUST DOES NOT REMAIN VISIBLE IN THE ATMOSPHERE BEYOND THE PROPERTY LINE OF THE EMISSION SOURCE. THIS REQUIREMENT SHALL BE SUBMITTED TO ARCHITECT AS A CONTRACTOR SUBMITTAL AND VERIFIED BY THE COMMUNITY DEVELOPMENT DEPARTMENT PRIOR TO SITE WORK.

3. ARCHITECTURAL COATINGS SHALL BE SELECTED SO THAT THE VOC CONTENT OF THE COATINGS IS COMPLIANT WITH SCAQMD RULE 1113. THIS REQUIREMENT SHALL BE SUBMITTED TO ARCHITECT AS A CONTRACTOR SUBMITTAL AND VERIFIED BY THE COMMUNITY DEVELOPMENT DEPARTMENT PRIOR TO COATING WORK.

4. CONTRACTOR TO REDUCE PROJECT CONSTRUCTION AIR QUALITY IMPACTS DURING CONSTRUCTION. THE FOLLOWING SHALL BE IMPLEMENTED BY CONTRACTOR DURING CONSTRUCTION:

a. WATER ACTIVE SITES AT LEAST TWICE DAILY • APPLY WATER THREE TIMES DAILY, OR NON-TOXIC SOIL STABILIZERS ACCORDING TO MANUFACTURERS' SPECIFICATIONS, TO ALL UNPAVED PARKING OR STAGING AREAS OR UNPAVED ROAD SURFACES.

b. ALL TRUCKS HAULING DIRT, SAND, SOIL, OR OTHER LOOSE MATERIALS ARE TO BE COVERED • PAVE ROAD AND ROAD SHOULDERS • INSTALL WHEEL WASHERS WHERE VEHICLES ENTER AND EXIT THE CONSTRUCTION SITE ONTO PAVED ROADS OR WASH OFF TRUCKS AND ANY EQUIPMENT LEAVING THE SITE EACH TRIP • APPLY NON-TOXIC SOIL STABILIZERS ACCORDING TO MANUFACTURERS' SPECIFICATIONS TO ALL INACTIVE CONSTRUCTION AREAS (PREVIOUSLY GRADED AREAS INACTIVE FOR TEN DAYS OR MORE) • SUSPEND ALL EXCAVATING AND GRADING OPERATIONS WHEN WIND SPEEDS (AS INSTANTANEOUS GUSTS) EXCEED 25 MILES PER HOUR.

d. SWEEP STREETS AT THE END OF THE DAY IF VISIBLE SOIL IS CARRIED ONTO ADJACENT PAVED PUBLIC ROADS.

e. APPOINT A CONSTRUCTION RELATIONS OFFICER TO ACT AS A COMMUNITY LIAISON CONCERNING ON-SITE CONSTRUCTION ACTIVITY, INCLUDING RESOLUTION OF ISSUES RELATED TO PM10 GENERATION; AND REQUIRE ALL VEHICLES AND EQUIPMENT TO BE PROPERLY TUNED AND MAINTAINED ACCORDING TO MANUFACTURERS' SPECIFICATIONS.

5. NOISE GENERATING: PROJECT CONSTRUCTION ACTIVITIES SHALL TAKE PLACE BETWEEN THE HOURS OF 7:00 AM AND 7:00 PM ON ANY DAY, AND ARE NOT PERMITTED ON SUNDAYS OR A CITY-RECOGNIZED HOLIDAY. THE CONTRACTOR SHALL COMPLY WITH CITY OF COLTON NOISE ORDINANCE AS OUTLINED IN THE MUNICIPAL CODE.

6. CONTRACTOR TO INSTALL WINDOW ASSEMBLIES THAT ARE TESTED AND CERTIFIED TO PREVENT THE INTRUSION OF EXTERIOR NOISE SO THAT THE INTERIOR NOISE LEVEL WITH WINDOWS CLOSED, ATTRIBUTABLE TO EXTERIOR SOURCES, SHALL NOT EXCEED 45 DBA DECIBEL IN ANY HABITABLE ROOM. THIS REQUIREMENT SHALL BE SUBMITTED TO ARCHITECT AS A CONTRACTOR SUBMITTAL.

7. CONTRACTOR TO SUBMIT EVIDENCE TO THE ARCHITECT AND OWNER THAT THE FOLLOWING NOISE REDUCTION MEASURES AS STATED ON THE CONSTRUCTION PLANS AND SPECIFICATIONS ARE BEING IMPLEMENTED:

a. CONSTRUCTION TRAFFIC SHALL BE LIMITED TO HAUL ROUTES ESTABLISHED BY THE CITY OF COLTON.

b. STATIONARY EQUIPMENT (SUCH AS GENERATORS AND AIR COMPRESSORS) SHALL BE LOCATED AS FAR FROM RESIDENCES, INCLUDING HOTEL ROOMS, AS FEASIBLE.

c. EQUIPMENT MAINTENANCE AND STAGING AREAS SHALL BE LOCATED AS FAR AWAY FROM RESIDENCES AS FEASIBLE.

d. CONSTRUCTION EQUIPMENT SHALL BE FITTED WITH MANUFACTURER'S STANDARD, OR BETTER, NOISE-SHIELDING AND MUFFLING DEVICES TO REDUCE NOISE LEVELS TO THE MAXIMUM EXTENT FEASIBLE.

e. THE PROJECT OWNER/DEVELOPER SHALL DESIGNATE A CONSTRUCTION COMPLAINT MANAGER FOR THE PROJECT. A TELEPHONE CONTACT NUMBER SHALL BE CLEARLY POSTED AT ALL ACTIVE ACCESS POINTS.

CUTTING AND PATCHING

1. THE CONTRACTOR SHALL IN THE WORK OF ALL TRADES, PERFORM ALL CUTTING, PATCHING, REPAIRING, RESTORING AND THE LIKE NECESSARY TO COMPLETE THE WORK AND TO RESTORE ANY DAMAGED OR AFFECTED SURFACES RESULTING FROM THE WORK OF THIS CONTRACT TO THEIR ORIGINAL CONDITION TO THE SATISFACTION OF THE OWNERS AND THE ARCHITECT.

2. CONTRACTOR SHALL BE RESPONSIBLE FOR ALL CUTTING, FITTING, PATCHING, AND FIRE SAFING METHODS REQUIRED TO COMPLETE THE WORK INCLUDING BUT NOT LIMITED TO THE FOLLOWING:

a. UNCOVERED PORTIONS OF THE WORK USED TO PROVIDE FOR INSTALLATION OF UNSCHEDULED WORK.

b. REMOVE AND REPLACE DEFECTIVE WORK.

c. REMOVE AND REPLACE WORK NOT CONFORMING TO REQUIREMENTS OF CONTRACT DOCUMENTS.

d. PROVIDE REPAIR PENETRATIONS OF NON-STRUCTURAL SURFACES FOR INSTALLATION OF PIPING AND ELECTRICAL CONDUIT.

e. REMOVE EXISTING WORK INDICATED IN THE DOCUMENTS AND AS MAY BE REQUIRED TO PERMIT THE PROPER INSTALLATION OF NEW WORK THAT FORMS PART OF HIS CONTRACT. ALL CUTTING, REPAIRING AND/OR PATCHING NECESSARY IN CONNECTION WITH SUCH REMOVALS SHALL BE DONE WITHOUT EXTRA CHARGE, WHETHER OR NOT EVERY ITEM MAY BE SPECIFICALLY DESCRIBED.

3. PROCEDURES FOR NON-STRUCTURAL CUTTING AND PATCHING:

a. PROVIDE ADEQUATE TEMPORARY SUPPORT AS NECESSARY TO ASSURE THE STRUCTURAL VALUE INTEGRITY OF THE AFFECTED PORTION OF THE WORK.

b. PROVIDE DEVICES AND METHODS TO PROTECT OTHER PORTIONS OF THE PROJECT FROM DAMAGE.

c. PROVIDE PROTECTION FROM THE ELEMENTS FOR THAT PORTION OF THE PROJECT WHICH MAY BE EXPOSED BY CUTTING AND PATCHING WORK.

d. EXECUTE CUTTING BY METHODS WHICH WILL PREVENT DAMAGE TO OTHER WORK, AND WILL PROVIDE PROPER SURFACES TO RECEIVE INSTALLATION OR REPAIRS.

e. EXECUTE FITTING AND ADJUSTMENT OF PRODUCTS TO PROVIDE A FINISHED INSTALLATION TO COMPLY WITH SPECIFIED PRODUCTS, FUNCTIONS, TOLERANCES AND FINISHES, AND MANUFACTURERS' CRITERIA.

f. RESTORE WORK WHICH HAS BEEN CUT OR REMOVED. INSTALL NEW PRODUCTS TO PROVIDE COMPLETE WORK IN ACCORDANCE WITH REQUIREMENTS OF CONTRACT DOCUMENTS.

g. REFINISH ENTIRE SURFACE AS NECESSARY TO PROVIDE AN EVEN FINISH TO MATCH ADJACENT FINISHES.

DEMOLITION

1. CONTRACTOR SHALL PROVIDE A "DISCOVERY PROCESS" TO IDENTIFY POTENTIAL COMPLICATIONS WITHIN THE SCOPE OF WORK, PRIOR TO ANY DEMOLITION.

2. INTEGRITY OF EXISTING CONCRETE FLOOR (ABOVE AND BELOW) SHALL REMAIN INTACT.

3. CONTRACTOR SHALL VERIFY ALL EXISTING CONDITIONS ESPECIALLY PIPES, DUCTS, AND CONDUIT.

4. ALL DEMOLITION WORK SHALL BE IN ACCORDANCE WITH CHAPTER 33 OF THE CALIFORNIA BUILDING CODE.

5. ALL DEMOLITION WORK SHALL BE IN ACCORDANCE WITH THE CALIFORNIA FIRE CODE, SECTION 103.3.3 (INCLUDING ARTICLE 87).

6. THE CONTRACTOR SHALL FIELD SURVEY / AND VERIFY EXISTING CONDITIONS PRIOR TO STARTING ANY WORK.

7. DURING THE DEMOLITION, THE CONTRACTOR SHALL ALWAYS BE AWARE OF THE INTENDED FINAL RENOVATION CONDITIONS OF THE STRUCTURE AND THE REASON THE DEMOLITION WORK IS BEING DONE.

8. THE CONTRACTOR MUST ALLOW FOR ADDITIONAL DEMOLITION THAT MAY NOT BE SHOWN, BUT IS REQUIRED TO ACHIEVE THE FINISHED RESULT, AS SHOWN ON THE DRAWING.

9. DO NOT DISTURB OR DAMAGE IN ANY WAY EXISTING STRUCTURAL ELEMENTS. THE BUILDING HAS TO COMPLY WITH ALL SAFETY REGULATIONS AT ALL TIMES.

10. THE CONTRACTOR SHALL RESTORE TO ITS ORIGINAL CONDITION ANY EXISTING WORK DAMAGED DURING DEMOLITION BUT INDICATED TO REMAIN.

11. ALL REMOVED MATERIALS AND EQUIPMENT WHICH IN THE OPINION OF THE OWNER/ARCHITECT ARE SALVAGEABLE, SHALL REMAIN THE PROPERTY OF THE OWNER. DELIVER SUCH SALVAGED MATERIALS AND EQUIPMENT ON PREMISES AS DIRECTED, NEATLY PILE OR STORE THEM AND PROTECT FROM DAMAGE. DO NOT REUSE MATERIALS AND EQUIPMENT UNLESS SPECIFICALLY INDICATED ON PLANS OR SPECIFIED. REMOVE FROM PREMISES AND DISPOSE OF ALL MATERIALS CONSIDERED BY THE OWNER/ARCHITECT TO BE SCRAP. RECYCLE MATERIALS PER CURRENT JURISDICTIONAL CODE.

12. ALL RUBBISH AND DEBRIS RESULTING FROM DEMOLITION AND/OR NEW WORK SHALL BE RECYCLED AND/OR DISPOSED OF OFF-SITE AND SHALL NOT BE ALLOWED TO ACCUMULATE.

CONTRACTOR OBLIGATIONS

1. CONTRACTOR FOR THE PROJECT SHALL BE RESPONSIBLE FOR OBTAINING ALL REQUIRED BUILDING PERMITS PRIOR TO COMMENCING WORK.

2. THE CONTRACTOR SHALL INSURE THAT ALL WORK IS DONE IN A PROFESSIONAL WORK-MAN-LIKE MANNER BY SKILLED MECHANICS AND SHALL REPLACE ANY NEW AND/OR EXISTING MATERIALS OR ITEMS INDICATED TO REMAIN DAMAGED BY ANY CAUSE DURING CONSTRUCTION.

3. THE CONTRACTOR AND/OR SUBCONTRACTOR SHALL PRIOR TO THE SUBMISSION OF HIS BID OR PERFORMANCE OF WORK, NOTIFY THE OWNER OF ANY WORK CALLED OUT ON THE DRAWINGS THAT THE SPECIFICATIONS IN HIS TRADE THAT CANNOT BE FULLY GUARANTEED OR WARRANTED FROM DEFECTIVE WORKMANSHIP OR MATERIAL DEFECTS.

4. THE CONTRACTOR SHALL NOTIFY THE ARCHITECT IF DETAILS ARE CONSIDERED UNSOUND, UNSAFE, NOT WATERPROOF, OR NOT WITHIN CUSTOMARY TRADE PRACTICE. IF WORK IS PERFORMED, IT WILL BE ASSUMED THAT THERE IS NO OBJECTIONS TO THE DETAIL. DETAILS ARE INTENDED TO SHOW END RESULT OF DESIGN. MINOR MODIFICATIONS MAY BE REQUIRED TO SUIT JOB CONDITIONS AND CURRENT TRADE PRACTICE AND SHALL BE INCLUDED AS PART OF THIS PROJECT.

5. CONTRACTOR SHALL BE RESPONSIBLE FOR ALL FINISHES AT POINT OF CONNECTIONS FOR ALL WORK (ARCHITECTURAL, STRUCTURAL, MECHANICAL AND ELECTRICAL). FINISHES WILL MATCH THOSE SPECIFIED OR EXISTING IN LINE, TEXTURE AND FINISH. SPOT PAINTING IS NOT ACCEPTABLE. NEW FINISHES SHALL BE FROM CORNER TO CORNER, FLOOR TO CEILING, ETC.

6. UNLESS OTHERWISE NOTED, ALL MATERIALS SHALL BE NEW AND OF GOOD QUALITY. WHERE EXISTING MATERIALS ARE INDICATED TO BE SALVAGED, CONTRACTOR SHALL INVENTORY, CLEAN, BOX, PROTECT, AND STORE ITEMS FOR REUSE ON THE PROJECT. ITEMS NOT REUSED SHALL BE RETURNED TO OWNER.

7. COORDINATION: THE GENERAL AND EACH SUB CONTRACTOR SHALL BE RESPONSIBLE FOR VERIFICATION AND COORDINATION WITH OTHER SUB CONTRACTORS TO ASSURE COMPLIANCE WITH DRAWINGS AND SPECIFICATIONS, AND THE ACCURATE LOCATION OF ARCHITECTURAL, STRUCTURAL, MECHANICAL AND ELECTRICAL BUILDING ELEMENTS. THEIR REQUIRED OPENINGS CLEARANCES SUPPORT SYSTEMS ARE ALL INTERCONNECTED AND COORDINATED.

8. CONTRACTOR SHALL BE RESPONSIBLE FOR COORDINATING THE WORK OF ALL TRADES AND FOR BEING AWARE OF ALL CONDITIONS THAT AFFECT THEIR WORK. NOTIFY OWNER, IN WRITING, WITHIN 3 WORKING DAYS OF AWARD OF CONTRACT, OF THE PROPOSED DELIVERY SCHEDULE, OF ANY EQUIPMENT, FINISHES OR MATERIAL, FOR WHICH THAT SCHEDULE WILL PREVENT THE INSTALLATION FROM BEING COMPLETED AT THE TIME OF THE SCHEDULED PROJECT COMPLETION.

COORDINATION OF WORK:

- THE CONTRACTORS SHALL PROVIDE AND COORDINATE THE EXACT DIMENSIONS SIZES AND POSITIONS OF ALL SYSTEMS, EQUIPMENT, MOUNTING, AND ATTACHMENTS RELATING TO THE WORK.
- THE CONTRACTOR SHALL PROVIDE AND COORDINATE ALL DIMENSIONS SIZES AND POSITIONS OF OPENINGS IN SLABS AND WALLS NECESSARY TO THE INSTALLATION OF THE WORK.
- ALL EQUIPMENT, CONTROLS AND TERMINATIONS SHALL BE POSITIONED FOR SAFE, DIRECT AND EASY ACCESS.
- IT SHALL BE THE RESPONSIBILITY OF THE CONTRACTOR TO CHECK WITH THE ARCHITECTURAL DRAWINGS BEFORE PROCEEDING WITH INSTALLATION OF CIVIL, STRUCTURAL, MECHANICAL, PLUMBING, AND ELECTRICAL WORK. SHOULD THERE BE ANY DISCREPANCIES BETWEEN THE ARCHITECTS AND THE ENGINEERS DRAWINGS AND SPECIFICATIONS THAT WOULD AFFECT A CONTRACTUAL, MECHANICAL AND/OR THE ARCHITECT'S ATTENTION FOR CLARIFICATION PRIOR TO INSTALLATION OF SAID WORK, ANY WORK INSTALLED IN CONFLICT WITH THE ARCHITECTURAL DRAWINGS SHALL BE CORRECTED BY THE CONTRACTOR AT HIS EXPENSE AND AT NO ADDITIONAL EXPENSE TO THE OWNER OR ARCHITECT.

9. THE CONTRACTOR SHALL VERIFY ALL DIMENSIONS AND CONDITIONS OF EXISTING SITE PRIOR TO BIDDING AND START OF CONSTRUCTION. THE CONTRACTOR SHALL REPORT TO THE ARCHITECT ALL CONDITIONS WHICH PREVENT THE PROPER EXECUTION OF ITS WORK. THE DRAWINGS SHALL NOT BE SCALED.

10. ALL SYMBOLS AND ABBREVIATIONS USED ON THE DRAWINGS ARE CONSIDERED TO BE CONSTRUCTION STANDARDS. IF THE CONTRACTOR HAS QUESTIONS REGARDING ABBREVIATIONS OR THEIR EXACT MEANING, THE ARCHITECT SHALL BE NOTIFIED IN WRITING FOR CLARIFICATION.

11. CONTRACTOR SHALL PROVIDE AND INSTALL ALL STIFFENERS, BRACING, BACK-UP PLATES, AND SUPPORTING BRACKETS REQUIRED FOR THE INSTALLATION OF ALL CASEWORK, STAIR RAILINGS, TOILET ACCESSORIES, PARTITIONS, AND OF ALL WALL MOUNTED OR SUSPENDED MECHANICAL, ELECTRICAL, OR MISC. EQUIPMENT.

12. CONTRACTOR SHALL VERIFY SIZES AND LOCATIONS OF ALL MECHANICAL AND ELECTRICAL PADS AND BASES AS WELL AS POWER OR WATER AND DRAIN INSTALLATIONS WITH EQUIPMENT MANUFACTURERS BEFORE PROCEEDING WITH WORK. CHANGES TO ACCOMMODATE FIELD CONDITIONS OR SUBSTITUTIONS SHALL BE MADE WITHOUT ADDITIONAL CHARGE TO OWNER.

FIRE PROTECTION:

1. FIRE PROTECTION FOR THIS WORK SHALL BE PROVIDED WITH A COMPLETE AND APPROVED AUTOMATIC SPRINKLER SYSTEM. THE SYSTEM SHALL BE IN ACCORDANCE WITH THE CITY BUILDING CODE, NFPA, STATE CODES AND INSURANCE UNDERWRITERS REQUIREMENTS. THE SYSTEM SHALL BE IN COMPLIANCE WITH CALIFORNIA BUILDING STANDARDS CODE (CBCS) AND AUTHORITY HAVING JURISDICTION.

2. THE CONTRACTOR SHALL BE RESPONSIBLE FOR DESIGN OF THE SYSTEM AND SHALL COORDINATE ALL REQUIREMENTS FOR WET PIPE SYSTEM, FIRE RISERS, ALARM SYSTEM, FIRE SPRINKLER HEADS, PRESSURE HEADS, PRESSURE TESTS, SYSTEM AUTHORITIES, FIRE DEPARTMENT AND ALL OTHER TRADES. THE ENTIRE BUILDING SHALL BE PROVIDED WITH WET TYPE FIRE SPRINKLER SYSTEM. SYSTEM SHALL INCLUDE AUTOMATIC FIRE SPRINKLERS, DISTRIBUTION PIPING INSPECTOR TEST, FIRE PUMP AS REQUIRED, SYSTEM DRAIN RISER CONTROL ASSEMBLY, FIRE DEPARTMENT CONNECTIONS (FDC), ALARM GONG, AND PRESSURE SWITCH FOR ALARM TRANSMISSION.

3. BUILDING AND SAFETY DEPARTMENT APPROVALS FOR FIRE SPRINKLER SYSTEMS SHALL BE OBTAINED PRIOR TO INSTALLATION. THE FIRE SPRINKLER SYSTEM SHALL BE INSPECTED AND APPROVED PRIOR TO BUILDING PERMIT FINAL.

4. CONTRACTOR TO COORDINATE LOCATIONS OF ALL SPRINKLER HEADS WITH THE ARCHITECTURAL REFLECTIVE CEILING PLANS, DUCT WORK, AND ELECTRICAL FIXTURE LAYOUT. PRIOR TO FABRICATION SUBMIT LAYOUT DRAWINGS FOR ARCHITECTURAL APPROVAL.

5. IT SHALL BE THE RESPONSIBILITY OF THE CONTRACTOR TO INSTALL PIPING IN SUCH A MANNER AS TO CONFORM TO NEW STRUCTURE, AVOID OBSTRUCTIONS, PRESERVE HEADROOM, KEEP OPENINGS AND NECESSARY PASSAGEWAY CLEAR, AND MAKE ALL EQUIPMENT REQUIRING INSPECTION, MAINTENANCE AND REPAIR, ACCESSIBLE WITHOUT FURTHER INSTRUCTIONS OR EXTRA COST TO THE OWNER.

6. THE CONTRACTOR SHALL PROVIDE PORTABLE FIRE EXTINGUISHERS AS REQUIRED BY CODE AND AUTHORITY HAVING JURISDICTION, AT ALL PORTIONS OF THE BUILDING ON EACH FLOOR. THESE EXTINGUISHERS SHALL BE INSTALLED IN THE LOCATIONS APPROVED BY THE FIRE DEPARTMENT AND THE ARCHITECT.

7. WHERE TESTING LABORATORY DESIGN NUMBERS ARE LISTED FOR FIRE RATED CONSTRUCTION, THE COMPONENTS AND INSTALLATION DETAILS MUST CONFORM WITH THE DESIGN NUMBER SPECIFIED.

RATED ASSEMBLY PENETRATIONS

1. MECHANICAL DUCTS, ETC. PENETRATING FIRE-RATED CEILINGS AND FIRE WALLS SHALL BE CORRESPONDINGLY RATED OR DAMPERED. CABINETS, ELECTRICAL PANELS, LIGHTS, ETC. RECESSED INTO FIRE RATED WALLS OR CEILINGS SHALL BE BACKED WITH CORRESPONDING FIRE-RESISTIVE CONSTRUCTION AS REQUIRED TO MAINTAIN THE INTEGRITY OF THE FIRE PROTECTION.

2. FIRE RESISTIVE ASSEMBLIES FOR PROTECTION OF OPENINGS SHALL COMPLY WITH CBC CHAPTER 7.

3. PENETRATION OF FIRE RATED ASSEMBLIES WHICH REQUIRE OPENING PROTECTION SHALL BE FIRE STOPPED. FIRE STOPPING SHALL BE IDENTICAL TO AN APPROVED UNDERWRITERS LABORATORIES (UL) LISTED ASSEMBLY WITH AN "F" OF "T" RATING. PENETRATIONS MUST ALSO CONSIST OF APPROVED MATERIALS FOR THROUGH WALL PENETRATIONS FIRE STOP SYSTEMS AS PRESCRIBED IN CBC STANDARD 7-5 FIRE RATING FOR FIRE STOP SYSTEMS SHALL BE EQUAL TO THE ASSEMBLY PENETRATED. (SECTION 709.6, CBC)

4. SHAFT ENCLOSURES: OPENINGS EXTENDING VERTICALLY THROUGH FLOORS SHALL BE ENCLOSED IN A SHAFT OF 1 HOUR FIRE-RESISTIVE CONSTRUCTION IF PENETRATING A 1 HOUR FIRE RATED FLOOR ASSEMBLY. SHAFTS SHALL INCLUDE A GYPSUM BOARD HORIZONTAL TERMINATION AT BOTTOM. ENGINEERED BY GENERAL CONTRACTOR. PROTECTION FOR STAIRWAYS SHALL BE AS SPECIFIED IN CODE OF JURISDICTION.

GLAZING

1. ALL GLAZING SHALL COMPLY WITH C.P.S.C. 16 C.F.R. AND CBC.

2. GLASS DOORS, ADJACENT PANELS AND ALL GLAZED OPENINGS SHALL BE APPROVED FOR IMPACT HAZARD PER CBC SECTION 2406. PROVIDE IDENTIFICATION OF GLAZING PER SECTION 2406.2

3. PROVIDE TEMPERED GLASS AS REQUIRED BY CBC SECTION 2406 AND BY OTHER APPLICABLE CODES.

SIGNAGE

1. FURNISH AND INSTALL SUPPORTS AND OTHER NECESSARY FINISH MATERIALS FOR A COMPLETE SIGNAGE INSTALLATION, BOTH INTERIOR & EXTERIOR

2. DISABILITY SIGNAGE / IDENTIFICATION

a. THE INTERNATIONAL SYMBOL OF ACCESSIBILITY SHALL BE THE STANDARD USED TO IDENTIFY FACILITIES THAT ARE ACCESSIBLE TO AND USEABLE BY PHYSICALLY DISABLED PERSONS.

b. LETTERS AND NUMBERS ON SIGNS HAVE A WIDTH TO HEIGHT RATIO OF BETWEEN .35 AND 1:1 AND A STROKE WIDTH TO HEIGHT RATIO OF BETWEEN 1:5 AND 1:10.

c. CHARACTERS AND SYMBOLS SHALL CONTRAST WITH THEIR BACKGROUND, EITHER LIGHT CHARACTERS ON A DARK BACKGROUND OR DARK CHARACTERS ON A LIGHT BACKGROUND.

d. ALL BUILDING ENTRANCES THAT ARE ACCESSIBLE TO AND USABLE BY PHYSICALLY HANDICAPPED PERSONS SHALL BE IDENTIFIED WITH AT LEAST ONE STANDARD SIGN AND WITH ADDITIONAL DIRECTIONAL SIGNS AS REQUIRED TO BE VISIBLE TO PERSONS ALONG APPROACHING PEDESTRIAN WAYS.

e. ALL SANITARY FACILITIES WILL BE PROVIDED WITH APPROPRIATE IDENTIFICATION SYMBOLS.

3. AREA AND OCCUPANCY SIGNAGE REQUIREMENTS OCCUPANT LOAD SIGN SHALL BE POSTED IN EACH MEETING ROOM, ASSEMBLY ROOM OR SIMILAR PURPOSE ROOM HAVING AN OCCUPANT LOAD OF 50 OR MORE.

4. EXIT SIGNS SHALL BE POSTED OVER EXITS DOORS SERVING 50 OR MORE AND ALL HAZARDOUS AREAS. MINIMUM LETTER HEIGHT IS 6" AND SHALL CONFORM WITH CBC AND LOCAL CODES. CBC SECTION 1003.2.8 AND UPC SECTION 12113A. SEE ELECTRICAL PLANS FOR LOCATIONS AND FURTHER INFO.

5. AN APPROVED SIGN SHALL BE LOCATED AT EACH FLOOR LEVEL LANDING IN ALL ENCLOSED STAIRWAYS. THE SIGN SHALL INDICATE FLOOR LEVEL, TERMINUS OF THE TOP AND BOTTOM OF THE STAIRWAY, AND THE IDENTIFICATION OF THE STAIRWAY.

EXITS

1. EXIT DOORS SHALL BE OF THE PIVOTED OR SIDE-HINGED SWINGING TYPE. EXIT DOORS SHALL SWING IN THE DIRECTION OF EXIT TRAVEL WHEN THE AREA SERVED HAS AN OCCUPANT LOAD OF 50 OR MORE.

2. EVERY EXIT DOOR SHALL BE OPERABLE FROM THE INSIDE WITHOUT THE USE OF A KEY OR ANY SPECIAL KNOWLEDGE OR EFFORT. NOTE ALSO THAT FLUSH BOLTS OR SURFACE BOLTS ARE PROHIBITED.

3. PANIC HARDWARE SHALL BE PROVIDED ON EXIT DOORS OF ROOMS, CORRIDORS, STAIRWAYS, HANDLING AN OCCUPANT CAPACITY OF 50 OR MORE PERSONS.

4. EXIT SIGNS SHALL BE INSTALLED AT REQUIRED EXIT DOORWAYS AND WHERE OTHERWISE NECESSARY TO CLEARLY INDICATE THE DIRECTION OF EGRESS IN COMPLIANCE WITH THE CODE OF JURISDICTION.

5. EGRESS DOORS SHALL BE SET IN MOTION WHEN SUBJECTED TO A 30 LB. FORCE. THE DOOR SHALL SWING TO THE FULLY OPEN POSITION WHEN AN OPENING FORCE NOT EXCEEDING 15 LBS IS APPLIED TO THE LATCH SIDE.

6. EACH DOOR IN A MEANS OF EGRESS FROM A GROUP 'A' OCCUPANCY SHALL NOT BE PROVIDED WITH A LATCH OR LOCK UNLESS IT IS PANIC HARDWARE OR FIRE EXIT HARDWARE (CBC 1008.1.9).

7. DOOR HANDLES, LOCK AND OTHER OPERATING DEVICES SHALL BE INSTALLED AT A MIN. 34" AND A MAX. 48" AFF

8. EXIT SIGNS SHALL BE CONNECTED TO AN EMERGENCY POWER SYSTEM THAT WILL PROVIDE AN ILLUMINATION OF NOT LESS THAN 90min IN DURATION. IN CASE OF PRIMARY POWER LOSS (CBC 1011.2 - 1011.5.3)

9. THE MEANS OF EGRESS, INCLUDING THE EXIT DISCHARGE, SHALL BE ILLUMINATED AT ALL TIMES THE BUILDING SPACE SERVED BY THE MEANS OF EGRESS IS OCCUPIED.

THERMAL ENVELOPE NOTES

THERMAL INSULATION PERFORMANCE TO MEET LOCAL MINIMUM ENERGY CODES. INSULATION ASSEMBLY, AS TESTED IN ACCORDANCE WITH ASTM 318, TO PROVIDE A CONTINUOUS THERMAL PERFORMANCE RATING AT EXTERIOR PERIMETER OF NEW WORK. PROVIDE ASSEMBLY THICKNESS TO MEET THERMAL RESISTANCE R-VALUE AS INDICATED BUT NO LESS THAN THE CODE. MINIMUM THERMAL RESISTANCE VALUES AS FOLLOWING:

- R-36 AT CEILING AND ATTIC SPACES
- R-19 AT EXTERIOR WALLS
- R-11 AT INTERIOR WALLS WHERE INSULATION IS USED FOR SOUND CONTROL
- R-13 AT FLOOR CRAWL SPACES

THERMAL ENVELOPE NOTES

1. DURING CONSTRUCTION OF THIS SCOPE OF WORK, CONTRACTORS MUST COMPLY AS APPLICABLE TO CCR TITLE 24 CALIFORNIA FIRE CODE CHAPTER 33 FIRE SAFETY DURING CONSTRUCTION AND DEMOLITION.

2. ENSURE EXITS PROVIDE FREE AND UNOBSTRUCTED EGRESS. PERSONNEL RECEIVE TRAINING IF ALTERNATIVE EXITS MUST BE DESIGNATED. BUILDING/AREAS UNDER CONSTRUCTION MUST MAINTAIN ESCAPE FACILITIES FOR CONSTRUCTION WORKERS AT ALL TIMES. MEANS OF EGRESS IN CONSTRUCTION AREAS ARE INSPECTED DAILY.

3. FIRE ALARM, DETECTION & SUPPRESSION SYSTEMS ARE NOT TO BE IMPAIRED. A TEMPORARY BUT EQUIVALENT SYSTEM SHALL BE PROVIDED WHEN ANY FIRE SYSTEM IS IMPAIRED. TEMPORARY SYSTEMS MUST BE INSPECTED AND TESTED MONTHLY.

4. PROVIDE ADDITIONAL FIRE-FIGHTING EQUIPMENT AND USE TRAINED PERSONNEL. CONTRACTOR TO TRAIN STAFF ON LOCATION OF AFS SHUT OFF VALVES SERVING PROJECT AREA.

5. SMOKING SHALL BE PROHIBITED AT ALL TIMES, IN OR ADJACENT TO ALL CONSTRUCTION AREAS. NO SMOKING ON STATION.

6. DEVELOP AND ENFORCE STORAGE, HOUSEKEEPING, AND DEBRIS REMOVAL PRACTICES THAT REDUCE THE FLAMMABLE AND COMBUSTIBLE FIRE LOAD OF THE BUILDING TO THE LOWEST LEVEL NECESSARY FOR DAILY OPERATIONS COMPLY WITH CHAPTER 33 FIRE SAFETY DURING CONSTRUCTION.

7. INCREASE SURVEILLANCE OF BUILDINGS, AND EQUIPMENT WITH SPECIAL ATTENTION TO EXCAVATIONS, CONSTRUCTION AREAS, CONSTRUCTION STORAGE, AND FIELD OFFICES.

8. CONDUCT ORGANIZATION-WIDE SAFETY EDUCATION PROGRAMS TO ENSURE AWARENESS OF ANY LIFE SAFETY CODE DEFICIENCIES. CONSTRUCTION HAZARDS AND INTERIM LIFE SAFETY MEASURES.

9. PROVIDE TEMPORARY DIRECTIONAL SIGNAGE APPROVED BY THE OWNERS FACILITY REPRESENTATIVE/ PROJECT MANAGER, REFER TO G-001

GENERAL

THESE PLANS ARE THE PROPERTY OF COUNTY OF SAN BERNARDINO, AND ARE NOT TO BE USED FOR ANY OTHER THAN THE LOCATION SHOWN HEREON.

1. NO CHANGES ARE TO BE MADE ON THESE PLANS WITHOUT THE KNOWLEDGE AND CONSENT OF THE ARCHITECT OR ENGINEER WHOSE SIGNATURE APPEARS HEREON.

2. DO NOT SCALE DRAWINGS. ALL DIMENSIONS ARE TO FACE OF CONCRETE, FACE OF CONCRETE MASONRY UNITS, CENTERLINE OF COLUMNS AND BEAMS, OR FACE OF STUDS, UNLESS OTHERWISE NOTED. FINISH FLOOR ELEVATIONS ARE TO TOP OF CONCRETE SLAB OR TOP OF INTERIOR PAVING UNLESS OTHERWISE NOTED.

3. ALL LEVELS REFERENCE POINTS ARE TAKEN FROM TOP OF SHEATHING OR TOP OF CONC. SLAB/COMBO DECKING. DIMENSIONS ON ELEVATIONS, SECTIONS AND WALL SECTIONS ARE REFERENCED TO THESE POINTS, UNLESS NOTED.

4. NO SUBSTITUTIONS WILL BE ALLOWED WITHOUT PRIOR WRITTEN APPROVAL. REQUEST FOR SUBSTITUTIONS SHALL BE IN ACCORDANCE WITH THE SPECIFICATIONS OF SHEETS G-001, 902, 903 AND ETC. THESE DRAWINGS DO NOT CONTAIN THE NECESSARY COMPONENTS FOR CONSTRUCTION SAFETY.

- ALL CONSTRUCTION SHALL BE PERFORMED IN ACCORDANCE WITH THE STATE CONSTRUCTION SAFETY ORDERS ENFORCED BY THE STATE DIVISION OF INDUSTRIAL SAFETY.

CODES

CONSTRUCTION SHALL COMPLY WITH APPLICABLE EDITION OF CALIFORNIA BUILDING CODE, ALL APPLICABLE LOCAL, STATE AND FEDERAL CODES, ORDINANCES, LAWS, REGULATIONS AND PROTECTIVE COVENANTS GOVERNING THE WORK. IN CASE OF CONFLICTS, THE MORE STRINGENT REQUIREMENT SHALL GOVERN.

PERMIT

1. THE CONSTRUCTION OR DEMOLITION OF ANY BUILDING, STRUCTURE, USING SCAFFOLDING OR FRAMEWORK MORE THAN 3 STORIES OR 36'-0" IN HEIGHT, REQUIRES A PERMIT FROM THE STATE OF CALIFORNIA DIVISION OF INDUSTRIAL SAFETY PRIOR TO THE ISSUANCE OF A BUILDING PERMIT. (17C.B.9)

2. A SEPARATE INTERIOR IMPROVEMENT PERMIT IS REQUIRED FOR ANY TENANT IMPROVEMENT IN THIS BUILDING.

3. A PERMIT FROM THE DEPARTMENT OF PUBLIC WORKS IS REQUIRED FOR A PROTECTION FENCE OR CANOPY ON OR OVER ANY STREET OR PUBLIC SPACE. PROTECTION OF PEDESTRIANS DURING CONSTRUCTION SHALL BE PROVIDED PER CBC SECTION 905.2.

4. ALL ROOMS ARE REQUIRED TO BE MARKED WITH APPROVED SIGNAGE.

5. OBTAIN PERMIT FROM CITY ENGINEER PRIOR TO DOING ANY SIDEWALK AND CURB WORK.

6. SEPARATE PERMITS SHALL BE OBTAINED FOR SIGNS, FENCES, TRASH ENCLOSURES, RETAINING WALLS, PLANTERS, AND POOLS.

7. THE DEFERRED SUBMITTAL ITEMS SHALL NOT BE INSTALLED UNTIL THEIR DESIGN AND SUBMITTAL DOCUMENTS HAVE BEEN APPROVED BY THE BUILDING OFFICIAL. REFER TO SHEET G-001 FOR LIST OF DEFERRED SUBMITTALS.

METAL WORK

1. ALL METAL FRAMING MEMBERS SHALL BE ARRANGED AND SPACED AS TO PERMIT INSTALLATION OF PIPE CONDUITS AND DUCTWORK WITH A MINIMUM OF CUTTING. SHAFT WALLS SHALL BE PROVIDED WITH NECESSARY FRAMES, BRACING, AND SEALANT AROUND THE OPENING.

2. CONTACT BETWEEN DISSIMILAR METAL SHALL BE PROTECTED.

WOOD WORK INCLUDING METAL STUDS

1. OFFSET STUDS WHERE REQUIRED SO THAT FINISH WALL SURFACE WILL BE FLUSH. IF STRUCTURAL PANELS ARE REQUIRED ON A WALL PLANE, THE ENTIRE WALL PLANE SHALL BE FURRED OR FINISHED FLUSH.

2. INSTALL METAL CORNER BEADS AT ALL EXPOSED WALLBOARD EDGES. INSTALL CASING BEADS WHERE EVER WALLBOARD, PLASTER, ETC. ABUTS A DISSIMILAR FINISH MATERIAL AND PROVIDE SEALANT AS REQUIRED.

3. GYPSUM BOARD SHALL EXTEND TO UNDERSIDE OF STRUCTURE ABOVE AT ALL EXTERIOR PERIMETER WALLS

DOORS

1. DOORS IN RATED WALLS SHALL CONSIST OF SELF-CLOSING, SELF-LATCHING ASSEMBLIES WITH SMOKE AND DRAFT SEALS AT HEAD AND JAMBS. DOOR ASSEMBLY RATINGS SHALL BE AS INDICATED ON DOOR SCHEDULE. HOLD OPEN DEVICES ON RATED ASSEMBLIES SHALL BE MAGNETICALLY OPERATED AND ACTIVATED BY SMOKE DETECTORS.

2. DOOR SIZES SHOWN ON DOOR SCHEDULE ARE OPENING SIZES. ALLOWANCE FOR THRESHOLDS, ETC., SHALL BE TAKEN OFF THE DOOR. DOORS AND FRAMES SHALL BE REINFORCED WHERE REQUIRED FOR CLOSERS, STOPS, AND HARDWARE.

3. AIR LEAKAGE AT EXTERIOR DOORS SHALL BE LIMITED BY THE FOLLOWING:

a. ALL DOORS SHALL BE PROVIDED WITH A SEAL, ASTRAGAL, OR BAFFLE AT THE HEAD AND SILL.

b. DOORS MOUNTED ON EITHER THE INSIDE OR OUTSIDE OF AN EXTERIOR WALL SHALL HAVE A MINIMUM 1/2" LAP AT EACH JAMB.

c. DOORS REQUIRING VERTICAL TRACK OR GUIDES SHALL USE A CONTINUOUS MOUNTING ANGLE, SEALED IN ACCORDANCE WITH "G" LISTED HERE.

d. DOORS MOUNTED BETWEEN THE JAMBS SHALL HAVE A CONTINUOUS SEAL OR BAFFLE AT EACH JAMB.

e. MEETING RAILS OR SECTION DOORS AND MEETING STILES OR RAILS OR BI-PARTING DOORS SHALL BE PROVIDED WITH A SEAL, ASTRAGAL, OR BAFFLE.

f. SWINGING DOORS SHALL BE WEATHERSTRIPPED AT THE HEAD, SILL AND JAMBS.

g. OPEN EXTERIOR JOINTS AROUND WINDOW AND DOOR FRAMES, BETWEEN WALL AND FOUNDATIONS, THROUGH WALLS, FLOORS AND ROOFS AND ALL OTHER OPENINGS IN THE EXTERIOR ENVELOPE SHALL BE SEALED, CAULKED, GASKETED, OR WEATHERSTRIPPED TO CREATE AN AIRTIGHT ASSEMBLY.

DRAWINGS LIST

Sheet Number
01- GENERAL

Sheet Name

G-000 COVER
G-001 PROJECT INFORMATION
G-002 DRAWING LIST AND GENERAL NOTES
G-100 ACCESSIBILITY SITE PLAN - FOR REFERENCE ONLY
G-110 CODE COMPLIANCE PLAN - FOR REFERENCE ONLY
02-ARCHITECTURAL
A-201 OVERALL FLOOR PLAN FIRST FLOOR
A-201A FLOOR PLAN FIRST FLOOR - PARTIAL
A-301 EXTERIOR ELEVATIONS

03-STRUCTURAL
S-001 GENERAL NOTES
S-500 STRUCTURAL DETAILS
04-MECHANICAL
M-001 MECHANICAL NOTES LEGEND AND ABBREVIATIONS
M-101 MECHANICAL FLOOR PLAN DEMOLITION
M-102 MECHANICAL FLOOR PLAN TEMPORARY WORK
M-201 MECHANICAL FLOOR PLAN
M-301 MECHANICAL DETAILS

06-ELECTRICAL
E-001 ELECTRICAL FLOOR PLAN TEMPORARY WORK
E-002 SPECIFICATIONS
E-003 SINGLE LINE DIAGRAM & LOAD CALCS
E-004 PANEL SCHEDULES
E-101 ELECTRICAL FLOOR PLAN TEMPORARY WORK
E-102 ELECTRICAL FLOOR PLAN DEMOLITION
E-201 ELECTRICAL FLOOR PLAN
E-501 ELECTRICAL DETAILS

Total Sheets: 23



CLIENT



SAN BERNARDINO COUNTY
PROJECT AND FACILITIES
MANAGEMENT DEPARTMENT

385 NORTH ARROWHEAD AVENUE, 3RD FLOOR SAN
BERNARDINO, CA 92415-0184


PROJECT NAME

ARMC
DEAERATOR #1
REPLACEMENT

PROJECT NO.
WBSE # 10.10.0847
CIP # 26-011
HCAI # 5230562-36-00
FACILITY NO.
17282
BUILDING NO.
BLD-00075 CENTRAL PLANT

400 N. PEPPER AVENUE
COLTON, CA 92324-1801

ENGINEER/ARCHITECT

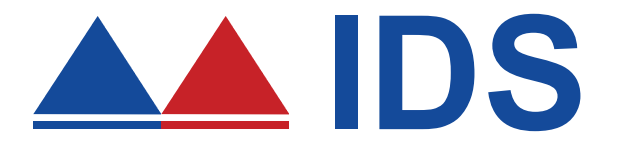

IDS GROUP

1 PETERS CANYON ROAD, SUITE 130
IRVINE, CA 92606
TEL: 949-387-8500, FAX: 949-387-0800


STAMP



C:\Users\cdfrs\cortell\Documents\22X066_02_ARCH_1_F202_01file.cortell\RSS\AS.rvt

8/4/2023 2:35:49 PM













IDS GROUP - FILE LOCATION:

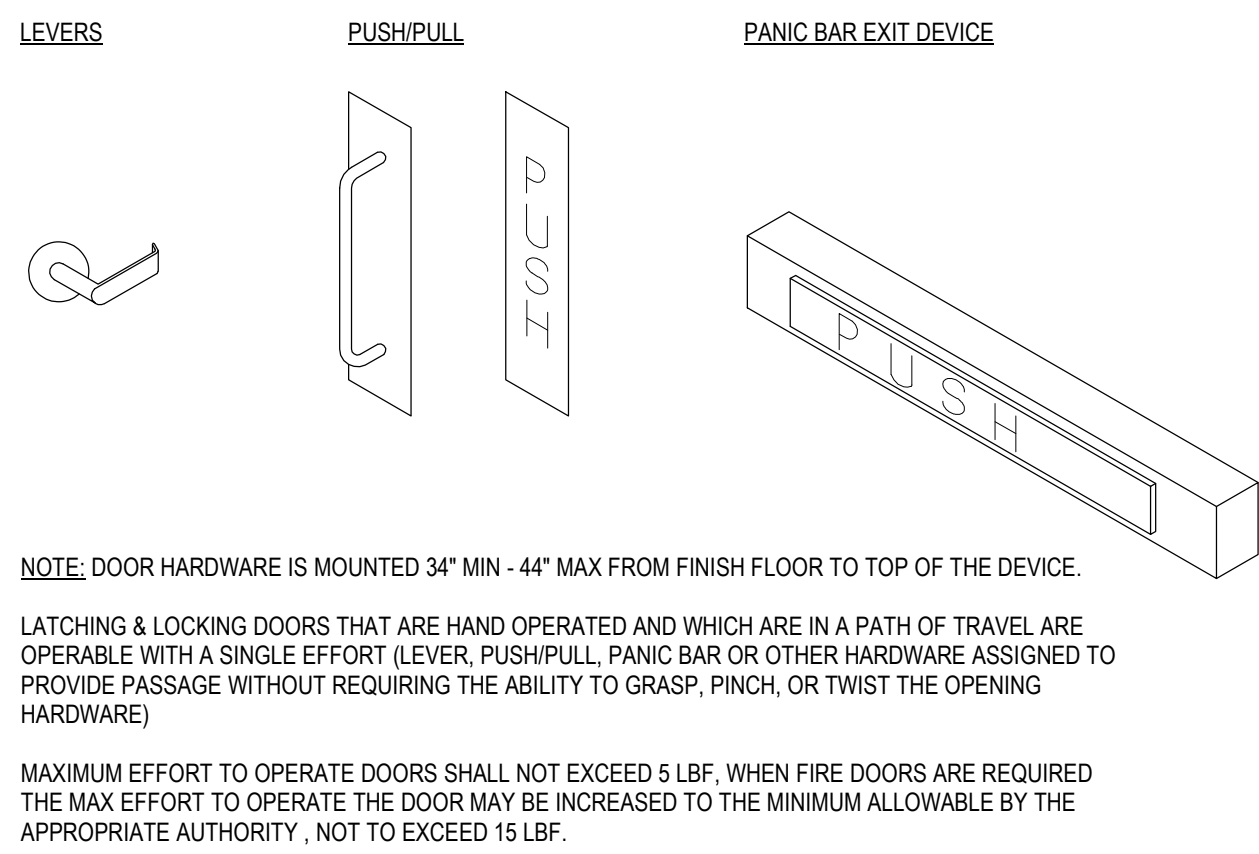

ACCESSIBLE DOOR HARDWARE

1" = 1'-0"

 D2

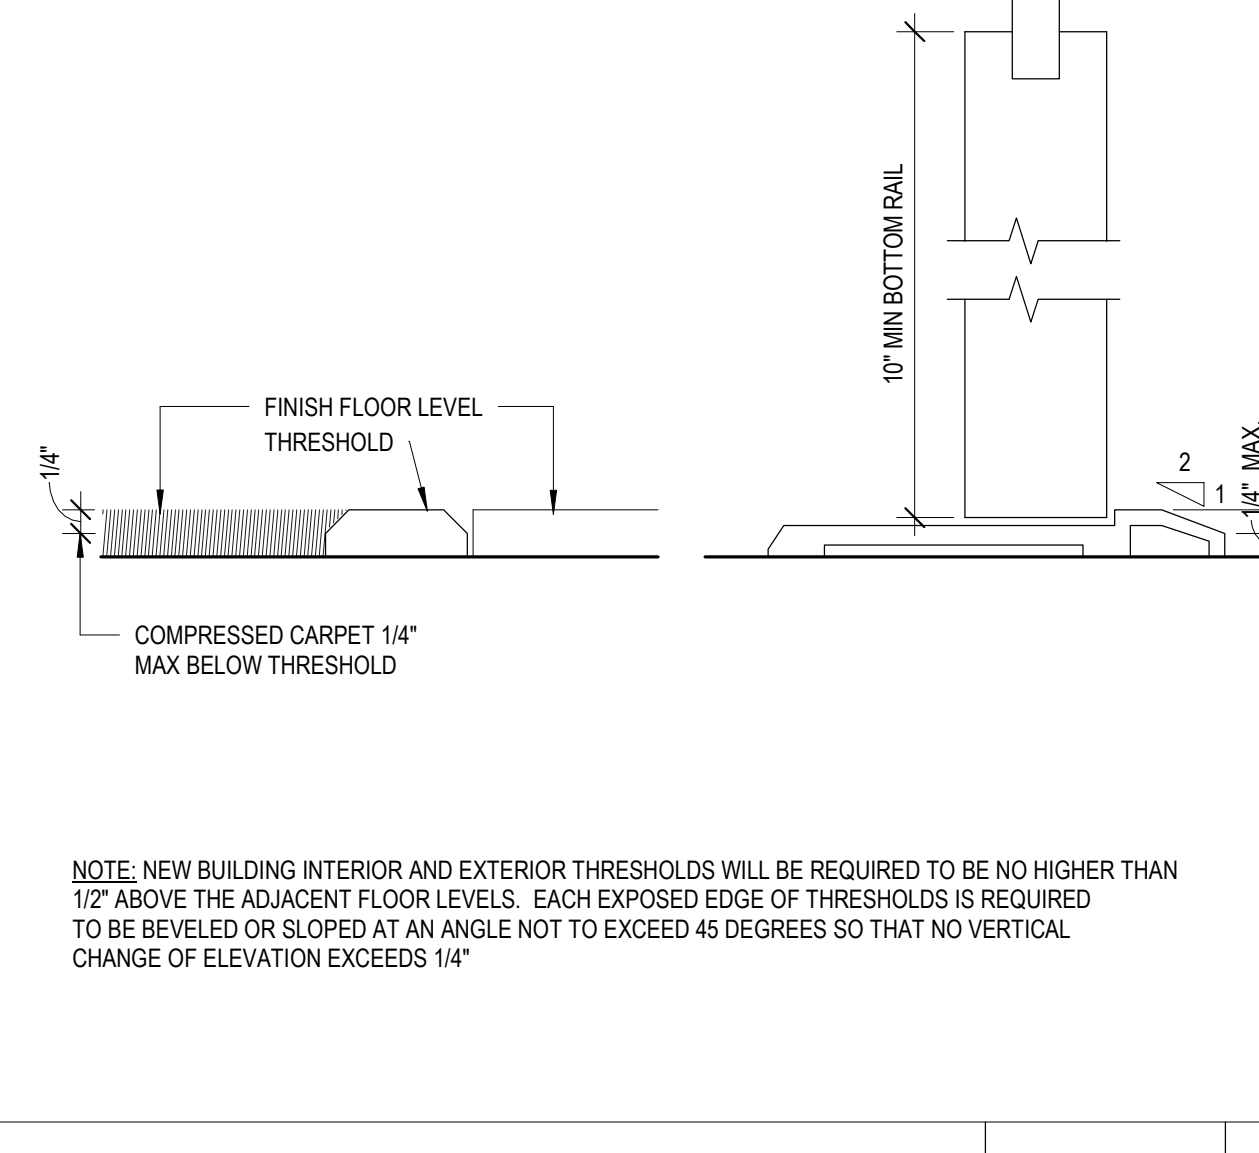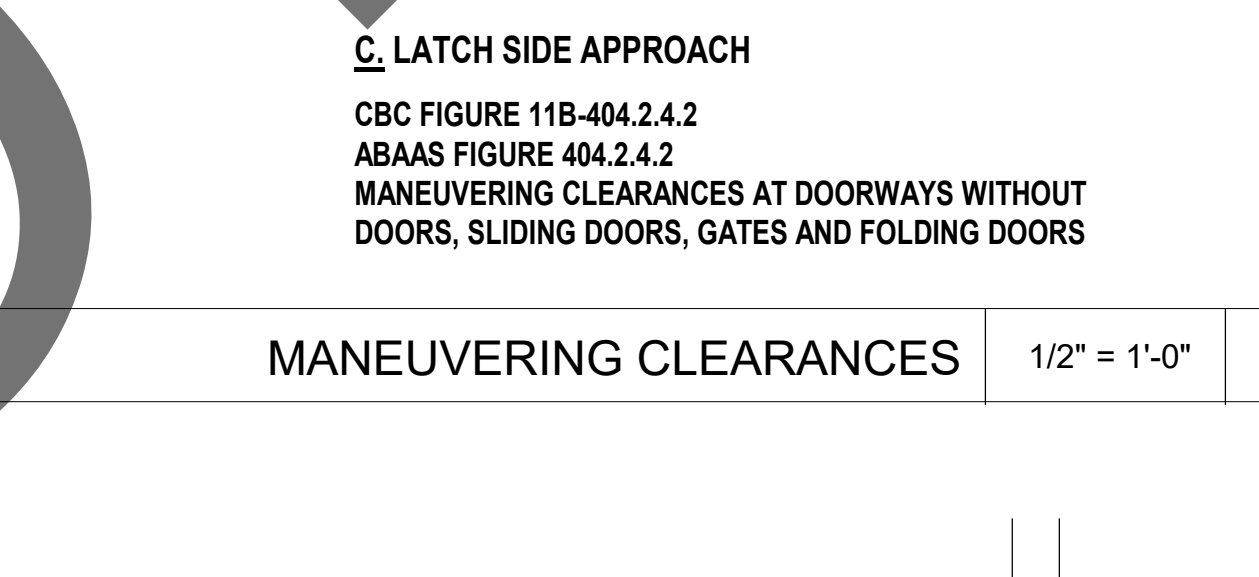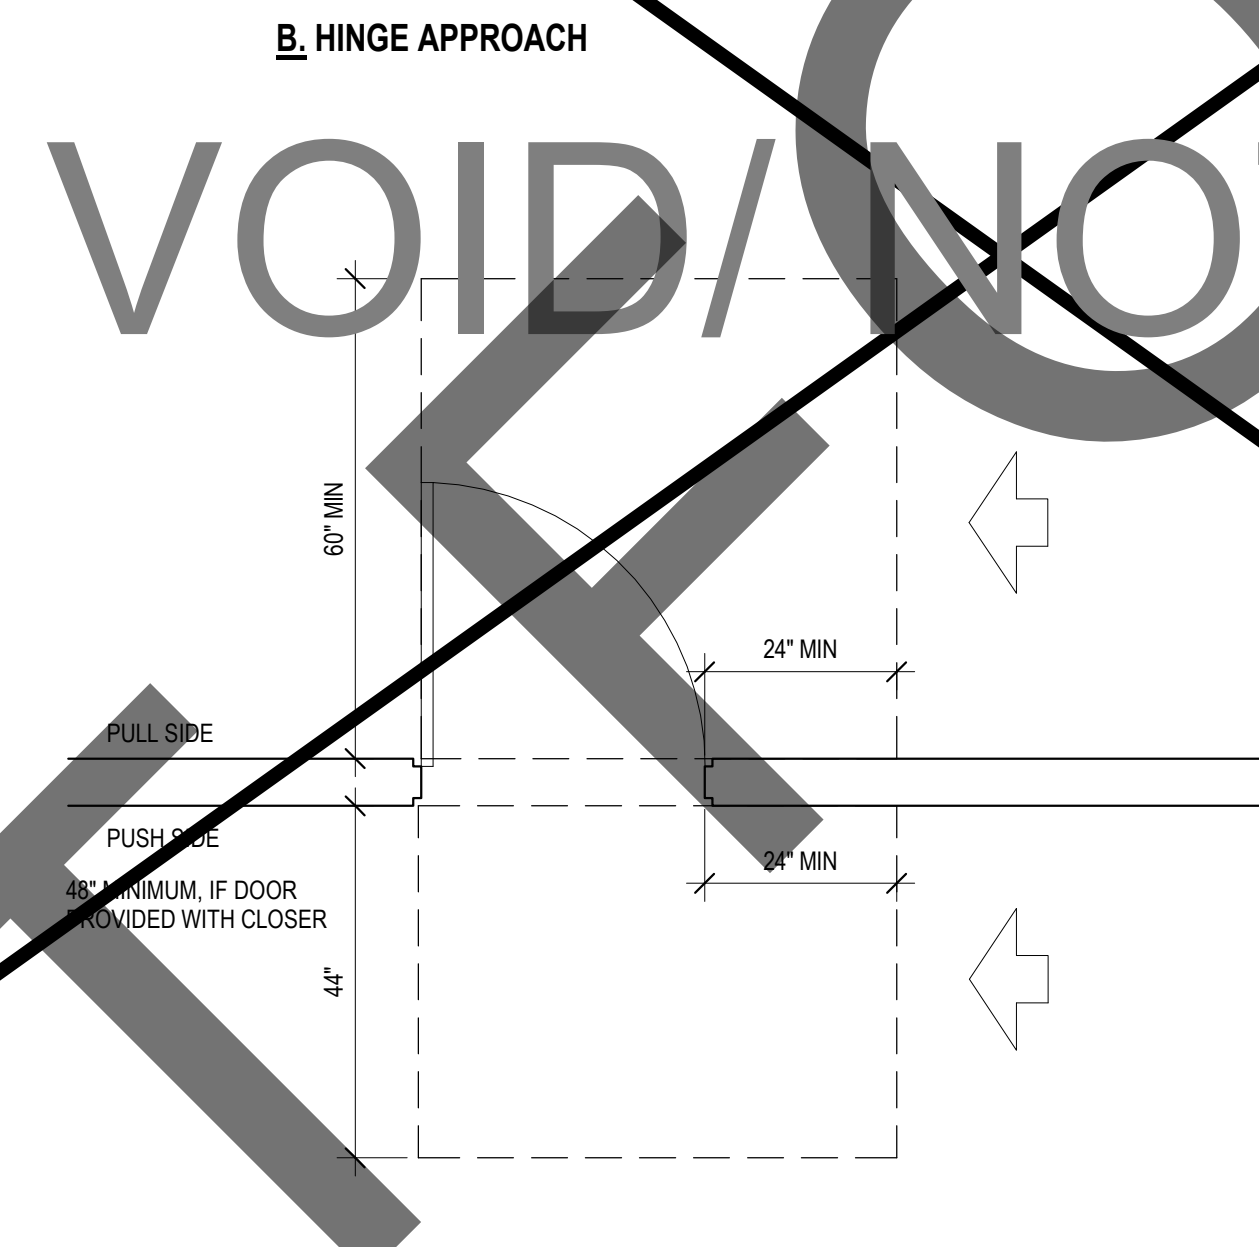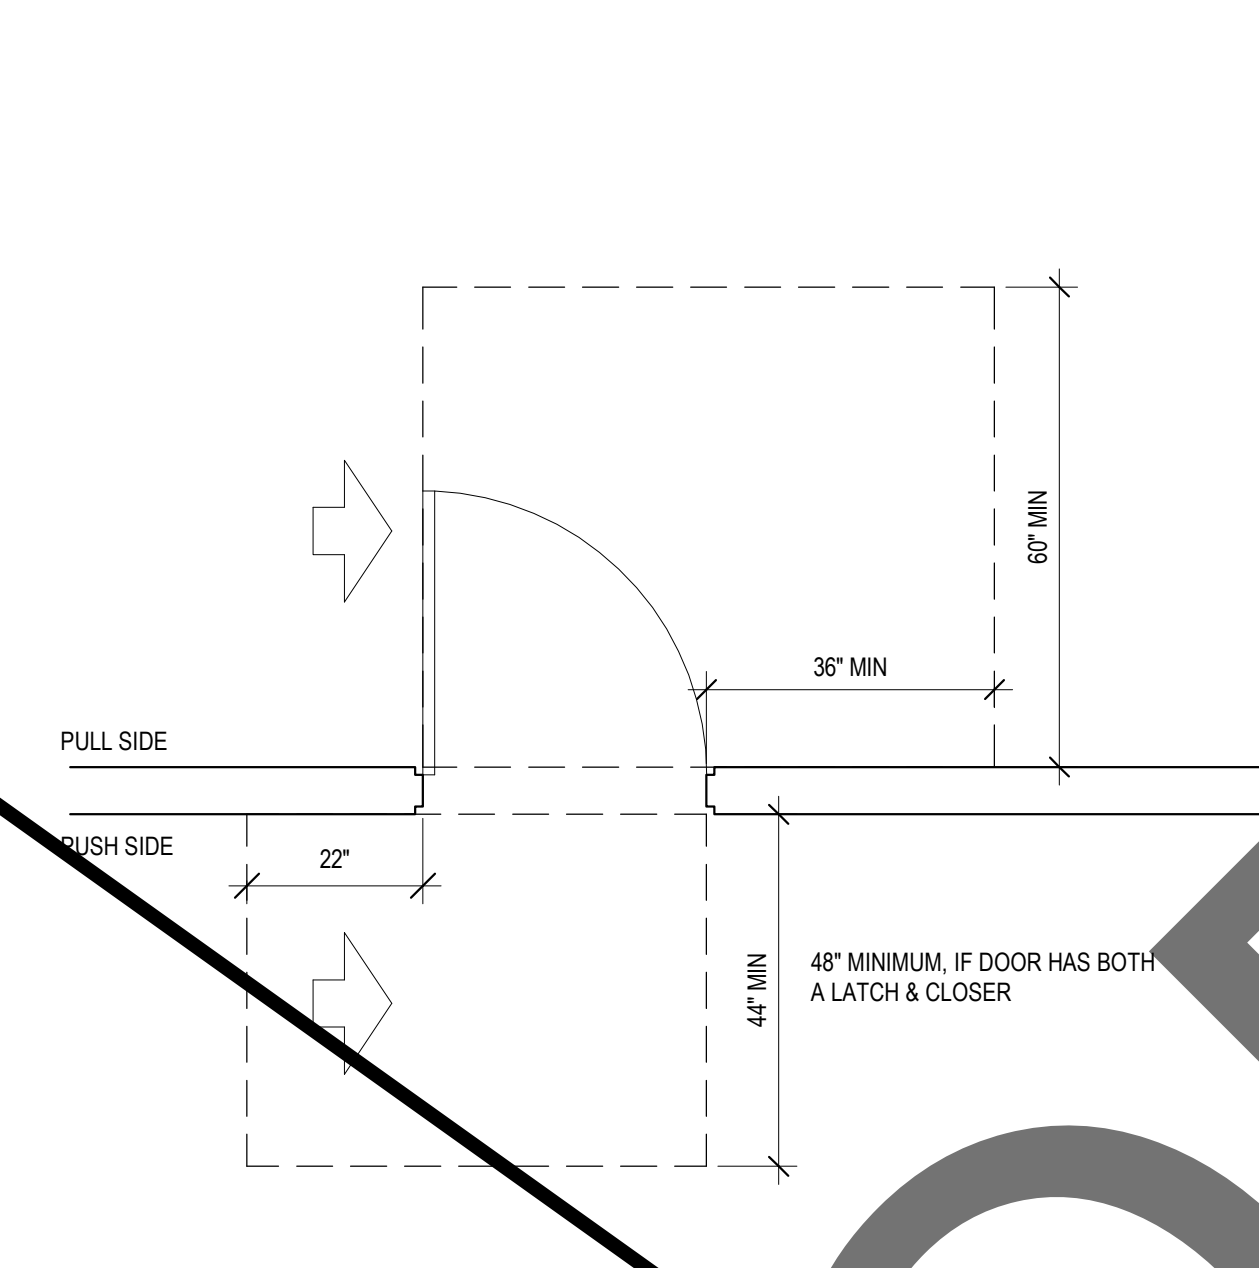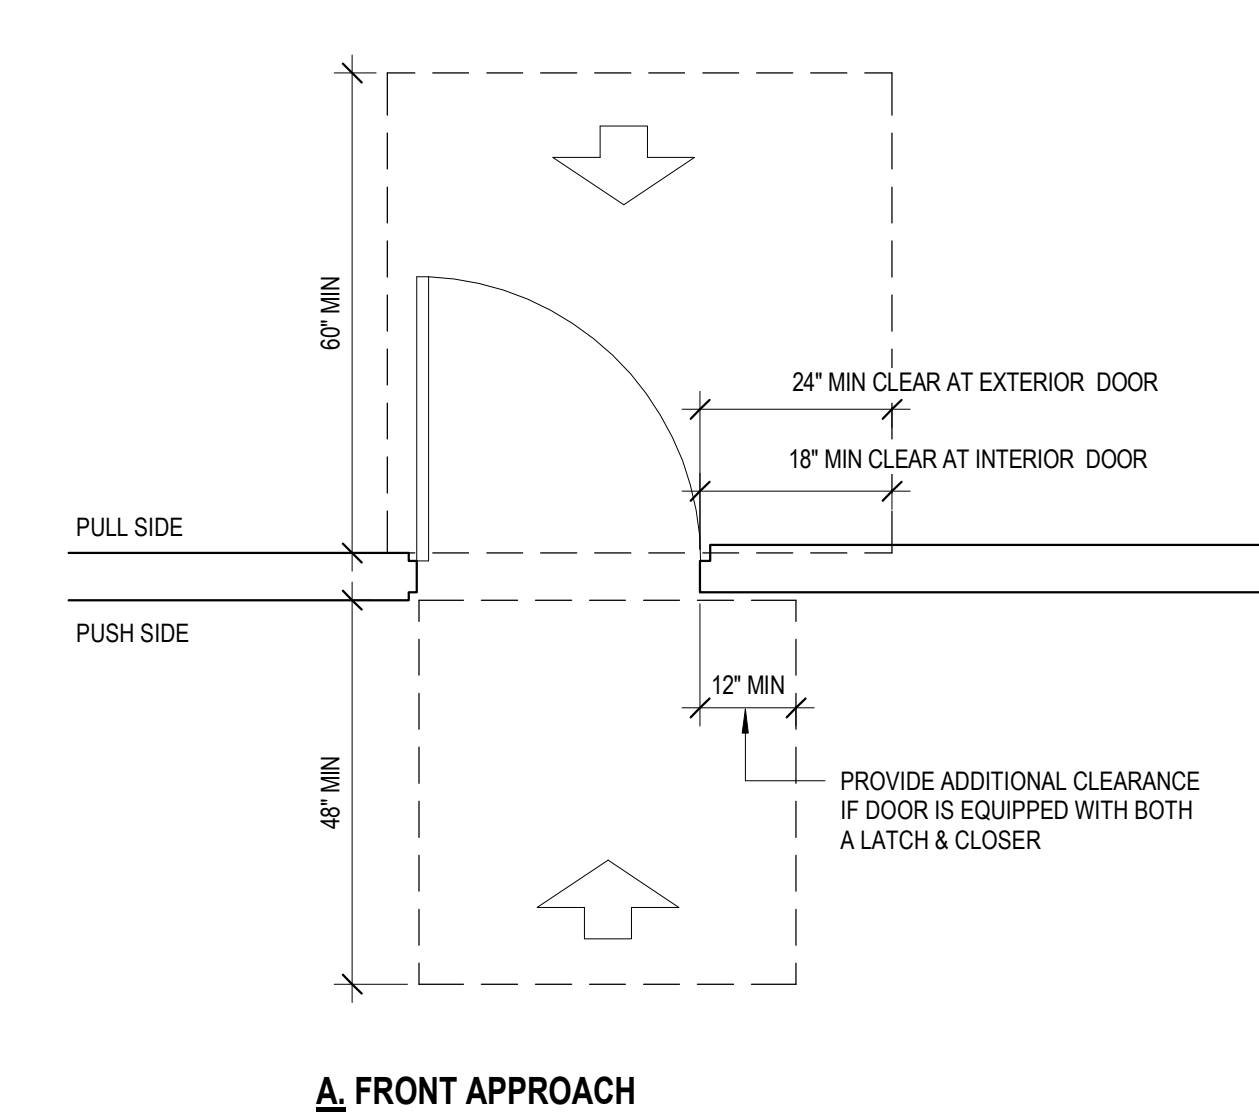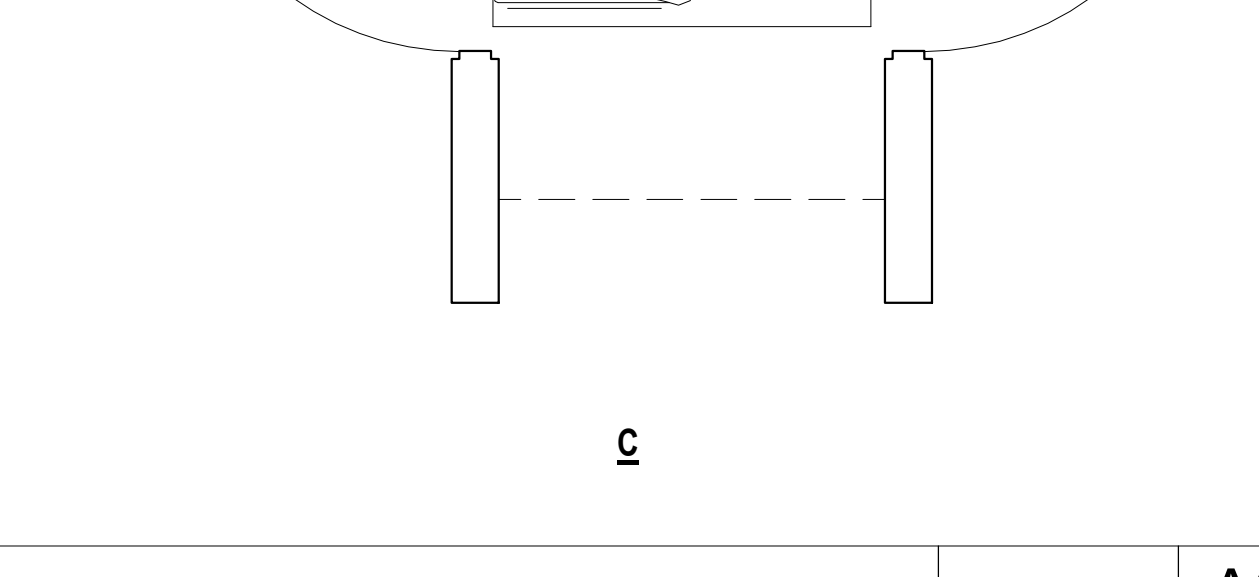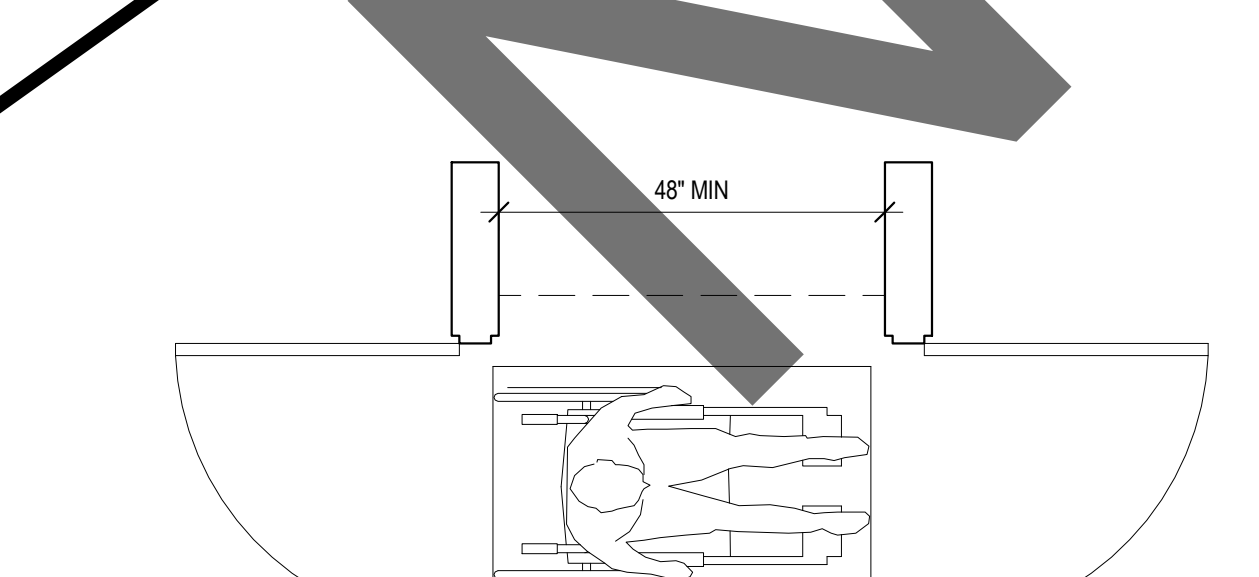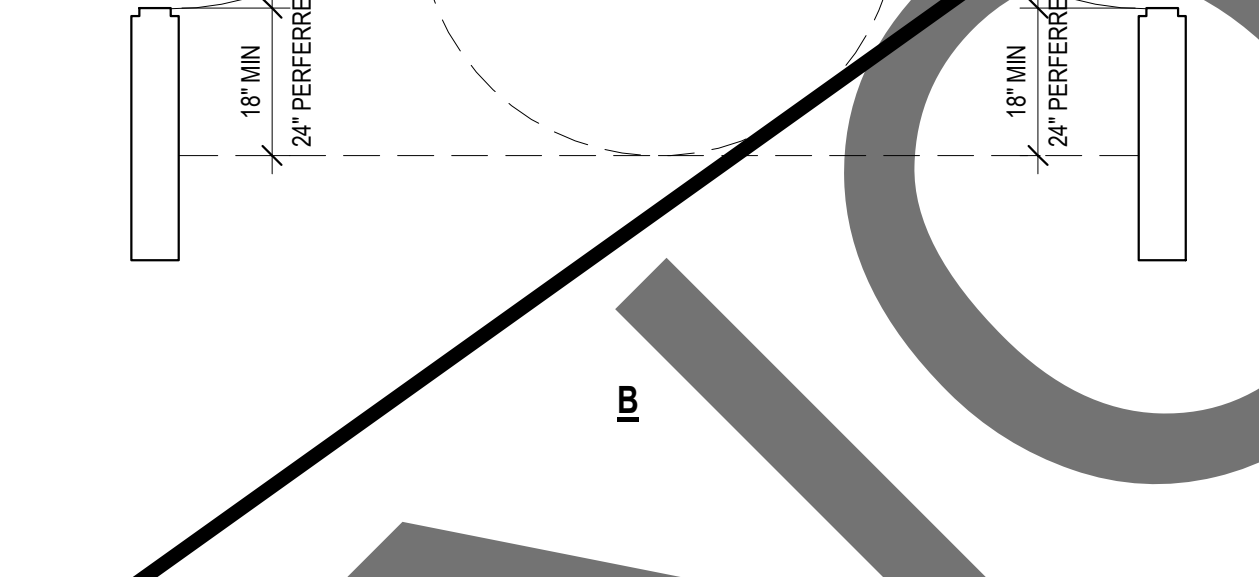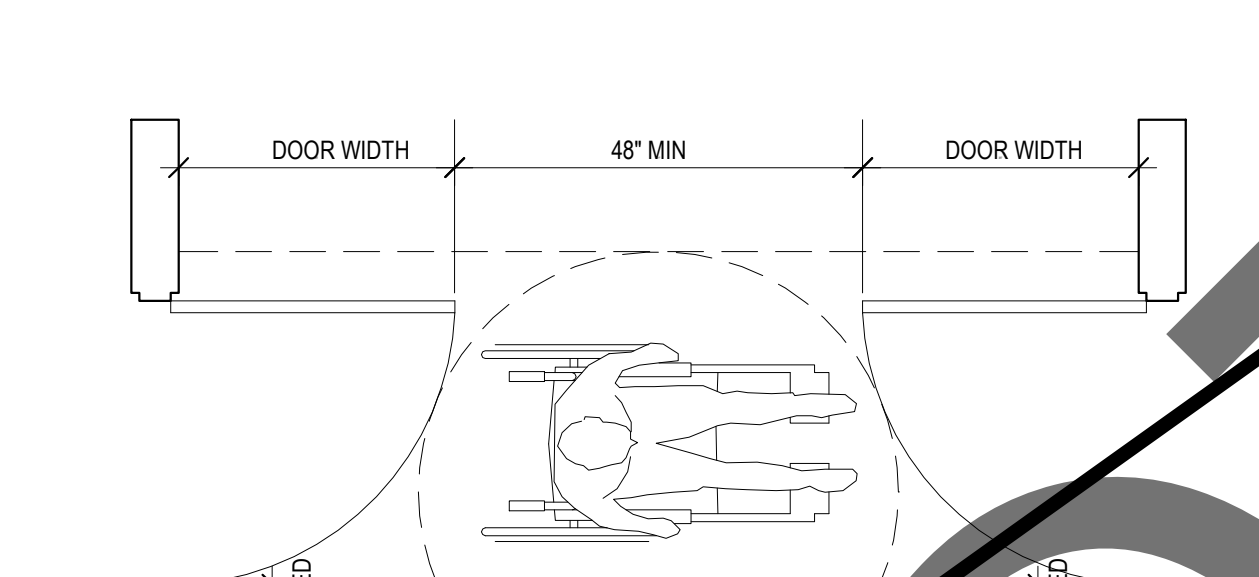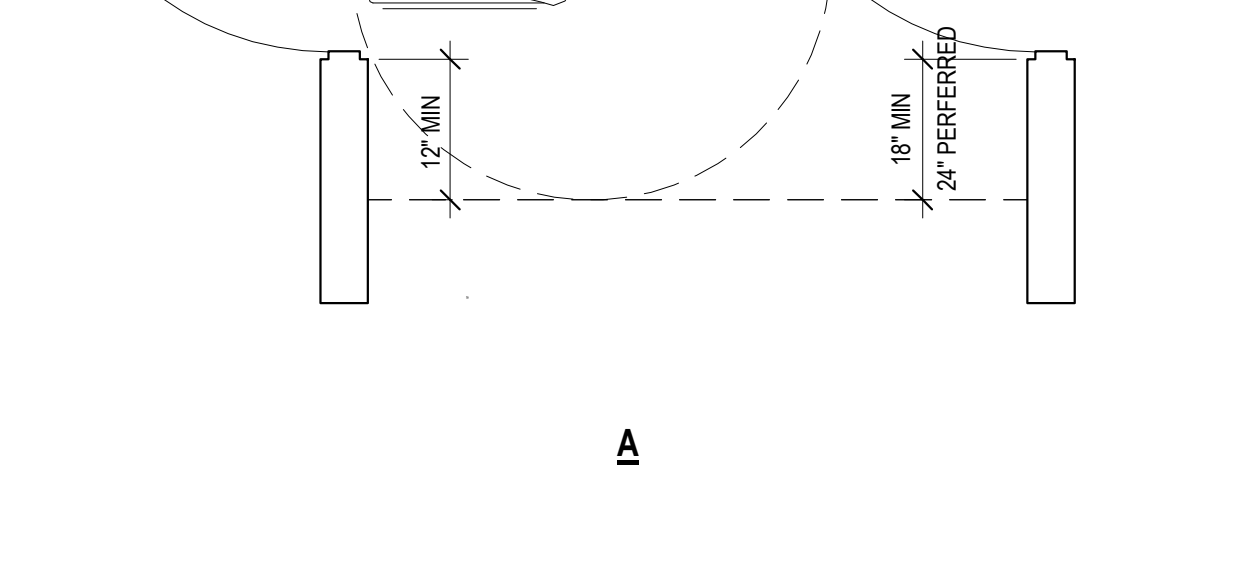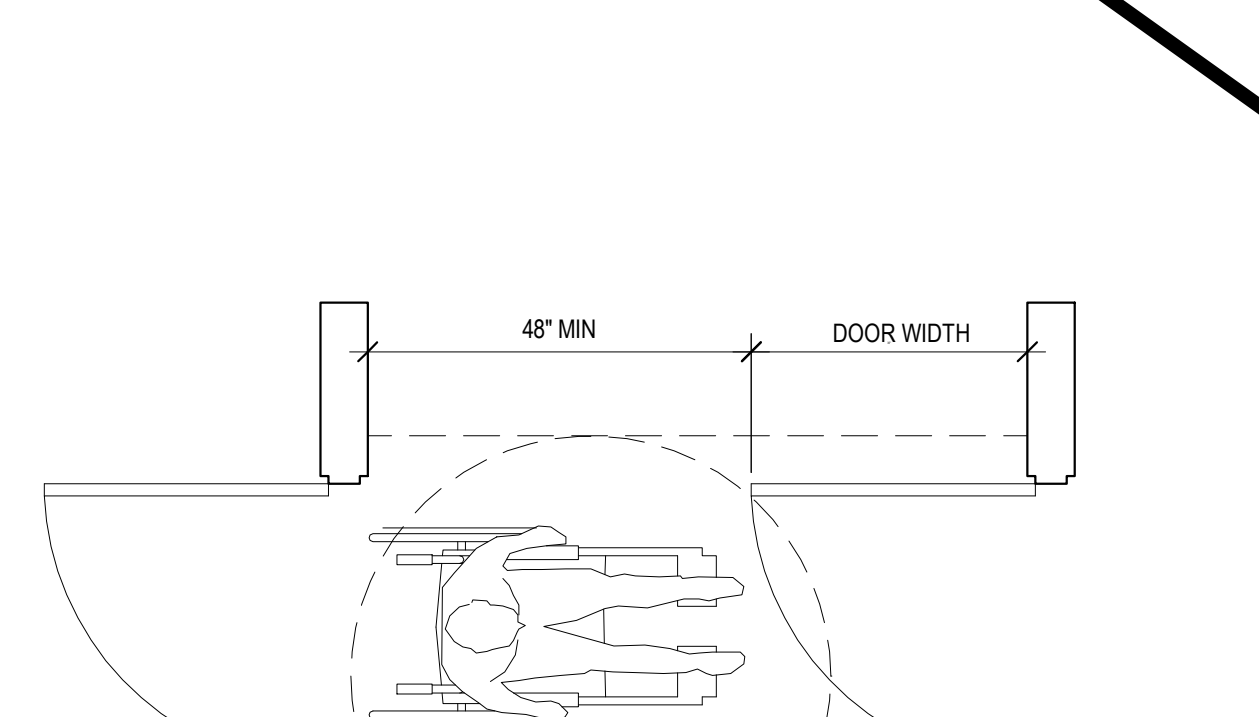

DOORS AND ENTRANCES:

1. MANUALLY OPERATED EDGE OR SURFACE MOUNTED FLUSH BOLTS AND SURFACE BOLTS OR ANY OTHER TYPE OF DEVICE THAT MAY BE USED TO CLOSE OR RESTRAIN THE DOOR OTHER THAN BY OPERATION OF THE LOCKING DEVICE SHALL NOT BE USED. WHERE EXIT DOORS ARE USED IN PAIRS AND APPROVED AUTOMATIC FLUSH BOLTS ARE USED, THE DOOR LEAF HAVING THE AUTOMATIC FLUSH BOLTS SHALL HAVE NO DOOR KNOB OR SURFACE-MOUNTED HARDWARE. THE UNLATCHING OF ANY LEAF SHALL BE OPERABLE WITH ONE HAND AND SHALL NOT REQUIRE TIGHT GRASPING, PINCHING, OR TWISTING OF THE WRIST. THE FORCE REQUIRED TO ACTIVATE OPERABLE PARTS SHALL BE 5 LBS MAX.

2. BARS, GRILLES, GRATES OR SIMILAR DEVICES PLACED OVER EXIT DOORS SHALL BE OPENABLE FROM INSIDE WITHOUT THE USE OF A KEY, TOOL, OR ANY SPECIAL KNOWLEDGE OR EFFORT. SUCH BARS, GRILLES, GRATES, OR SIMILAR DEVICES SHALL BE EQUIPPED WITH AN APPROVED RELEASE DEVICE FOR USE BY THE FIRE DEPARTMENT ONLY ON THE EXTERIOR SIDE FOR PURPOSE BY THE FIRE DEPARTMENT EMERGENCY ACCESS, WHEN REQUIRED BY THE AUTHORITY HAVING JURISDICTION.

3. THE CLEAR WIDTH OF MEANS OF EGRESS COMPONENTS IN AREA SERVING BED OR LITTER PATIENTS SHALL BE SUCH TO ALLOW READY PASSAGE OF BEDS, GURNEYS AND SIMILAR EQUIPMENTS, BUT SHALL NOT BE LESS THAN 44 INCHES. ENTRANCE DOORS TO PATIENTS' BEDROOMS FROM CORRIDORS SHALL NOT SWING INTO THE REQUIRED WIDTH OF CORRIDORS.

4. FOR HINGED DOOR, THE OPENING WIDTH SHALL BE MEASURED WITH THE DOOR POSITIONED AT AN ANGLE OF 90 DEGREES FROM ITS CLOSED POSITION. NONETHELESS, EXIT DOOR SHALL SWING TO THE FULLY OPEN POSITION.

5. WHERE A PAIR OF DOORS IS UTILIZED, AT LEAST ONE OF THE DOORS SHALL EXTEND 24" PAST THE STRIKE EDGE OF THE DOOR FOR EXTERIOR DOORS AND 18" PAST THE STRIKE EDGE FOR INTERIOR DOORS.

6. THE WIDTH OF THE LEVEL AREA ON THE PULL SIDE OF THE DOOR SHALL EXTEND 24" PAST THE STRIKE EDGE OF THE DOOR.

7. PROVIDE CLEAR SPACE OF 12" PAST STRIKE EDGE OF THE DOOR ON THE PUSH SIDE OF THE DOOR IF THE DOOR IS EQUIPPED WITH BOTH A LATCH AND A CLOSER ON THE PUSH SIDE OF THE DOOR.

8. LATCHING AND LOCKING DOORS THAT ARE HAND ACTIVATED AND WHICH ARE IN A PATH OF TRAVEL SHALL BE OPERABLE WITH A SINGLE EFFORT BY LEVER TYPE HARDWARE, PANIC BARS, PUSH/PULL ACTIVATING BARS, OR OTHER HARDWARE DESIGNED TO PROVIDE PASSAGE WITHOUT REQUIRING MORE THAN ONE HAND AND THE ABILITY TO GRASP, PINCH, OR TWIST THE OPENING HARDWARE. THE FORCE REQUIRED TO ACTIVATE OPERABLE PARTS SHALL BE 5 LBS MAX. LOCKED EXIT DOORS SHALL OPERATE AS ABOVE IN EGRESS DIRECTION. SECTION 11B-404.

9. THE FLOOR OR LANDING SHALL BE NOT MORE THAN 1/2 INCH LOWER THAN THE THRESHOLD OF THE DOORWAY. CHANGE IN LEVEL BETWEEN 1/4 INCH AND 1/2 INCH SHALL BE BEVELED WITH A SLOPE NO GREATER THAN 1:2. SECTION 11B-305.1.

10. THE BOTTOM 10 INCHES OF ALL DOORS EXCEPT AUTOMATIC AND SLIDING SHALL HAVE A SMOOTH UNINTERRUPTED SURFACE TO ALLOW THE DOOR TO BE OPENED BY A WHEELCHAIR FOOTREST WITHOUT CREATING A TRAP OR HAZARDOUS CONDITION. A 10 INCH HIGH SMOOTH PANEL SHALL BE INSTALLED ON PUSH SIDE OF THE DOOR, WHICH WILL ALLOW THE DOOR TO BE OPENED BY A WHEELCHAIR FOOTREST WITHOUT CREATING A TRAP OR HAZARDOUS CONDITION. SECTION 11B-404.2.1.

11. MAXIMUM EFFORT TO OPERATE DOORS SHALL NOT EXCEED 5 LBS FOR EXTERIOR DOORS AND 5 LBS FOR INTERIOR DOORS. SUCH PULL OR PUSH EFFORT BEING APPLIED AT RIGHT ANGLES TO HINGED DOORS, AND AT THE CENTER PLANE OF SLIDING OR FOLDING DOORS. COMPENSATING DEVICES OR AUTOMATIC DOOR OPERATORS MAY BE UTILIZED TO MEET THE ABOVE STANDARDS. WHEN FIRE DOORS ARE REQUIRED, THE MAXIMUM EFFORT TO OPERATE THE DOOR MAY BE INCREASED TO THE MAXIMUM ALLOWABLE BY THE APPROPRIATE ADMINISTRATIVE AUTHORITY, NOT TO EXCEED 15 POUNDS. DOOR CLOSERS SHALL BE ADJUSTED TO PROVIDE AN OPEN POSITION OF 18 DEGREES. THE FORCE REQUIRED TO MOVE THE DOOR TO A POSITION OF 12 DEGREES FROM THE LATCH IS 5 SECONDS MIN. CBC SECTION 11B-404.2.3 & 11B-404.2.4.

SPACE ALLOWANCE & REACH RANGES:

1. IF THE CLEAR FLOOR SPACE ONLY ALLOWS FORWARD APPROACH TO AN OBJECT, THE MAXIMUM HIGH FORWARD REACH SHALL BE 48"; SEE FIGURE 11B-308.1.1. THE MINIMUM LOW FORWARD REACH IS 15" IF THE HIGH FORWARD REACH IS OVER AN OBSTRUCTION, REACH AND CLEARANCES SHALL BE AS SHOWN IN FIGURE 11B-308.2.2.

2. IF THE CLEAR FLOOR SPACE ALLOWS PARALLEL APPROACH BY A PERSON IN A WHEELCHAIR, THE MAXIMUM HIGH SIDE REACH ALLOWED SHALL BE 48" AND THE LOW SIDE REACH SHALL BE NO LESS THAN 15" ABOVE THE FLOOR AS SHOWN IN FIGURE 11B-308.3.1. IF THE SIDE REACH IS OVER AN OBSTRUCTION, THE REACH AND CLEARANCES SHALL BE AS SHOWN IN FIGURE 11B-308.3.2.

CONTROLS & OPERATING MECHANISMS:

1. CONTROLS AND OPERATING MECHANISMS REQUIRED FOR ACCESSIBLE SHALL COMPLY WITH THE REQUIREMENTS OF SECTION 11B-305.

2. CLEAR FLOOR SPACE COMPLYING WITH SECTION 11B-305 THAT ALLOWS A FORWARD OR PARALLEL APPROACH BY A PERSON USING A WHEELCHAIR SHALL BE PROVIDED AT CONTROLS, DISPENSERS, RECEPTACLES, AND OTHER OPERABLE EQUIPMENT.

3. THE HIGHEST AND LOWEST OPERABLE PART OF ALL CONTROLS, DISPENSERS, RECEPTACLES, AND OTHER OPERABLE EQUIPMENT SHALL BE LOCATED WITHIN THE CLEAR FLOOR SPACE. THE HIGHEST OPERABLE PART SHALL BE NO MORE THAN 54" ABOVE THE FLOOR BUT NOT LOWER THAN 15" IF FORWARD APPROACHED AND WITHIN 48" BUT NOT MORE THAN 54" IF SIDE APPROACHED. ELECTRICAL AND COMMUNICATION SYSTEM RECEPTACLES ON WALLS SHALL BE LOCATED NO LESS THAN 15" ABOVE THE FLOOR TO THE BOTTOM OF THE OUTLET BOX.

4. CONTROLS AND OPERATING MECHANISMS SHALL BE OPERABLE WITH THE ONE HAND AND SHALL NOT REQUIRE TIGHT GRASPING, PINCHING, OR TWISTING OF THE WRIST. THE FORCE REQUIRED TO ACTIVATE CONTROLS SHALL BE NO GREATER THAN 5 POUNDS OF FORCE PER SECTION 11B-305.4.

5. THE BOTTOM OF THE OUTLET BOX OF RECEPTACLE OUTLETS SHALL BE NOT LESS THAN 15 INCHES ABOVE THE FLOOR OR WORKING PLATFORM.

6. THE TOP OF THE OUTLET BOX OF SWITCHES INTENDED TO BE USED BY THE OCCUPANT OF THE ROOM OR AREA TO CONTROL LIGHTING AND RECEPTACLE OUTLETS, AIR VENTILATES, OR COOLING, HEATING AND VENTILATING EQUIPMENT SHALL NOT BE MORE THAN 54" ABOVE THE FLOOR OR WORKING PLATFORM.

7. PER SECTION 901.22, THE HEIGHT OF THE MANUAL EDGE ALARM BELL SHALL BE 42" TO 48" TO THE HIGHEST POINT OF ACTUATING HANDLE.

8. CHANGES IN LEVEL GREATER THAN 1/2" HIGH SHALL BE ACCOMPLISHED BY MEANS OF A RAMP NO STEEPER THAN 1 VERTICAL TO 2 HORIZONTAL.

9. CARPET, IF CARPET OR CARPET TILE IS USED ON A GROUND OR FLOOR SURFACE, THEN IT SHALL BE SECURELY ATTACHED, HAVE A FIRM CUSHION, PAD OR BACKING OR NO PAD, AND HAVE A LEVEL LOOP. TEXTURED LOOP, LEAD-OUT, CUT-PILE, OR LEVEL-CUT UNICUT PILE TEXTURE. THE MAXIMUM PILE HEIGHT SHALL BE 1/8 INCH EXPOSED EDGES OF CARPET SHALL BE FASTENED TO FLOOR SURFACES AND HAVE TRIM ALONG THE ENTIRE LENGTH OF THE EXPOSED EDGE. CARPET EDGE TRIM SHALL COMPLY WITH SECTION 11B-302.2.

10. OPENINGS IN FLOOR OR GROUND SURFACE SHALL NOT ALLOW PASSAGE OF A SPHERE MORE THAN 1/2" IN DIAMETER. ELONGATED OPENINGS SHALL BE PLACED SO THAT THE LONG DIMENSION IS PERPENDICULAR TO THE DOMINANT DIRECTION OF TRAVEL.

11. IF A WALK CROSSES OR ADJACENT A VERTICAL RAMP WAY, AND THE WALKING SURFACES ARE NOT SEPARATED BY CURBS, RAILINGS, OR OTHER ELEMENTS BETWEEN THE PEDESTRIAN AREAS AND VEHICULAR AREAS, THE BOUNDARY BETWEEN THE AREAS SHALL BE DEFINED BY A CONTINUOUS DETECTABLE WARNING COMPLYING WITH 11B-705.

12. THE RUNNING SLOPE SHALL NOT EXCEED 1:20 AND CROSS SLOPE SHALL NOT EXCEED 1:48. FOR WALKING SURFACES THAT ARE PART OF AN ACCESSIBLE ROUTE.

CORRIDORS & AISLES, PROTRUDING OBJECTS, AND VERTICAL CLEARANCES:

1. WALKS, HALLS, CORRIDORS, PASSAGEWAYS, AISLES, OR OTHER CIRCULATION SPACES SHALL HAVE 96" MINIMUM CLEAR HEAD ROOM. ANY OBSTRUCTION PROJECTING FROM A CEILING SHALL BE A MINIMUM OF 8" ABOVE THE WALKING SURFACE AS MEASURED FROM THE BOTTOM OF THE OBSTRUCTION.

2. OBJECTS WITH LEADING EDGES MORE THAN 27 INCHES AND NOT MORE THAN 80 INCHES ABOVE THE FINISH FLOOR OR GROUND SHALL PROTRUDE 4 INCHES MAXIMUM HORIZONTALLY INTO THE CIRCULATION PATH.

3. FREESTANDING OBJECTS ON POSTS OR PYLONS SHALL OVERHANG CIRCULATION PATHS 12 INCHES MAXIMUM WHEN LOCATED 27 INCHES MINIMUM AND 80 INCHES MAXIMUM ABOVE THE FINISH FLOOR OR GROUND. WHERE A SIGN OR OTHER OBSTRUCTION IS MOUNTED BETWEEN POSTS OR PYLONS AND THE CLEAR DISTANCE BETWEEN THE POSTS OR PYLONS IS GREATER THAN 12 INCHES, THE LOWEST POINT OF SUCH SIGN OR OBSTRUCTION SHALL BE 27 INCHES MAXIMUM OR 80 INCHES MINIMUM ABOVE THE FINISH FLOOR OR GROUND.

4. VERTICAL CLEARANCE SHALL BE 80 INCHES HIGH MINIMUM. GUARDRAILS OR OTHER BARRIERS SHALL BE PROVIDED WHERE THE VERTICAL CLEARANCE IS LESS THAN 80 INCHES.

5. THE LEADING EDGE OF SUCH GUARDRAIL OR BARRIER SHALL BE LOCATED 27 INCHES MAXIMUM ABOVE THE FINISH FLOOR OR GROUND.

6. DOOR CLOSERS AND DOOR STOPS SHALL BE PERMITTED TO BE 78 INCHES MINIMUM ABOVE THE FINISH FLOOR OR GROUND.

TOILET ROOM FIXTURES AND ACCESSORIES:

1. THE HEIGHT OF ACCESSIBLE WATER CLOSETS SHALL BE A MINIMUM OF 17 INCHES AND A MAXIMUM OF 19 INCHES MEASURED TO THE TOP OF THE TOILET SEAT.

2. PROVIDE 17" TO 18 INCHES FROM THE CENTERLINE OF THE WATER CLOSETS TO THE ADJACENT WALLS.

3. CLEARANCE AROUND THE WATER CLOSET SHALL BE 60" MINIMUM MEASURED PERPENDICULAR FROM THE SIDE WALL AND 36" MINIMUM MEASURED PERPENDICULAR FROM THE REAR WALL FOR WALL HUNG WATER CLOSETS AND 50" DEEP MINIMUM FOR MOUNTED WATER CLOSETS.

4. A MINIMUM 60" WIDE AND 48" DEEP MANEUVERING SPACE SHALL BE PROVIDED IN FRONT OF THE WATER CLOSET.

5. FLUSH CONTROLS SHALL BE HAND OPERATED OR AUTOMATIC. HAND OPERATED CONTROLS SHALL BE LOCATED 44" MAXIMUM ABOVE THE FLOOR AND SHALL BE LOCATED ON THE OPEN SIDE OF THE WATER CLOSET COMPARTMENT. OPERABLE PARTS SHALL BE OPERABLE WITH ONE HAND AND SHALL NOT REQUIRE TIGHT GRASPING, PINCHING, OR TWISTING OF THE WRIST. THE FORCE REQUIRED TO ACTIVATE OPERABLE PARTS SHALL BE 5 LBS MAXIMUM.

6. URINALS SHALL BE STALL-TYPE OR WALL HUNG. WHERE ONE OR MORE WALL-HUNG URINALS ARE PROVIDED, AT LEAST ONE WITH AN ELONGATED RIM PROJECTING A MINIMUM OF 13 1/2 INCHES FROM THE WALL AND A MAXIMUM OF 19 INCHES ABOVE THE FLOOR SHALL BE PROVIDED. FLUSH CONTROLS SHALL BE HAND OPERATED OR AUTOMATIC. HAND OPERATED FLUSH CONTROLS SHALL COMPLY WITH SECTION 11B-308 EXCEPT THAT THE FLUSH CONTROL SHALL BE MOUNTED AT A MAXIMUM HEIGHT OF 44" (1118mm) ABOVE THE FINISH FLOOR. TOE CLEARANCE SHALL EXTEND 25" MAXIMUM UNDER AN ELEMENT.

7. LAVATORIES, WHEN LOCATED ADJACENT TO A SIDE WALL OR PARTITION, SHALL BE A MINIMUM OF 18 INCHES TO THE CENTERLINE OF THE FIXTURE. ALL LAVATORIES THAT ARE DESIGNATED TO BE ACCESSIBLE SHALL BE A MINIMUM 17 INCHES IN HORIZONTAL DEPTH AND MOUNTED WITH THE RIM OR COUNTER EDGE NO HIGHER THAN 34 INCHES ABOVE THE FINISHED FLOOR AND WITH VERTICAL CLEARANCE MEASURED FROM THE BOTTOM OF THE APRON OR THE OUTSIDE BOTTOM EDGE OF THE LAVATORY OF 29 INCHES REDUCING TO 27 INCHES AT A POINT LOCATED 8 INCHES BACK FROM THE FRONT EDGE. IN ADDITION, A MINIMUM 9 INCH HIGH TOE CLEARANCE MUST BE PROVIDED EXTENDING BACK TOWARD THE WALL TO A DISTANCE NO MORE THAN 6 INCHES FROM THE BACK WALL. THE TOE CLEARANCE SPACE MUST BE FREE OF EQUIPMENT OR OBSTRUCTIONS.

8. A CLEAR FLOOR SPACE 30 INCHES BY 48 INCHES COMPLYING WITH SECTION 11B-305 SHALL BE PROVIDED IN FRONT OF A LAVATORY TO ALLOW FORWARD APPROACH. SUCH CLEAR FLOOR SPACE SHALL ADJOIN OR OVERLAP AN ACCESSIBLE ROUTE AND SHALL EXTEND A MAXIMUM OF 19 INCHES INTO KNEE AND TOE SPACE UNDERNEATH THE LAVATORY.

9. HOT WATER AND DRAIN PIPES ACCESSIBLE UNDER LAVATORIES SHALL BE INSULATED OR OTHERWISE COVERED. THERE SHALL BE NO SHARP OR ABRASIVE SURFACES UNDER LAVATORIES.

ACCESSIBILITY NOTES

10. FAUCET CONTROLS AND OPERATING MECHANISMS SHALL BE OPERABLE WITH ONE HAND IN ACCORDANCE WITH THIS CHAPTER AND SHALL NOT REQUIRE TIGHT GRASPING, PINCHING OR TWISTING OF THE WRIST. THE FORCE REQUIRED TO ACTIVATE CONTROLS SHALL BE NO GREATER THAN 5 LBF. LEVER-OPERATED, PUSH-TYPE AND ELECTRONICALLY CONTROLLED MECHANISMS (PREFERABLE) ARE EXAMPLES OF ACCEPTABLE DESIGNS. SELF-CLOSING VALVES ARE ALLOWED IF THE FAUCET REMAINS OPEN FOR AT LEAST 10 SECONDS.

11. MIRRORS SHALL BE MOUNTED WITH THE BOTTOM EDGE OF THE REFLECTING SURFACE NO HIGHER THAN 40 INCHES FROM THE FLOOR.

12. WHERE TOWEL, SANITARY MARKING, WASTE RECEPTACLES, DISPENSERS, OTHER EQUIPMENT AND CONTROLS ARE PROVIDED, AT LEAST ONE OF EACH TYPE SHALL BE LOCATED ON AN ACCESSIBLE ROUTE, WITH ALL OPERABLE PARTS, INCLUDING COUN SLOTS, WITHIN 40 INCHES FROM THE FINISHED FLOOR AND SHALL COMPLY WITH SECTION 11B-308, CONTROLS AND OPERATING MECHANISMS.

13. TOILET TISSUE DISPENSERS SHALL BE LOCATED ON THE WALL 7 TO 9" IN THE FRONT EDGE OF THE TOILET BOWL MEASURED TO THE CENTERLINE OF THE DISPENSER. MOUNTED 1 1/2" MINIMUM BELOW THE GRAB BAR. AT A MINIMUM HEIGHT OF 15" MINIMUM TO THE OUTLET OF THE DISPENSER. DISPENSERS THAT CONTROL DELIVERY OR THAT DO NOT PERMIT CONTINUOUS PAPER FEED SHALL NOT BE USED.

14. GRAB BARS, TUB AND SHOWER SEATS, FASTENERS AND MOUNTING DEVICES SHALL BE DESIGNED FOR A 250-LB POINT LOAD.

15. WHERE COAT HOOKS ARE PROVIDED IN TOILET ROOMS OR TOILET COMPARTMENTS AT LEAST ONE IN EACH AREA SHALL BE MOUNTED WITHIN 48" FROM THE FLOOR OR GROUND SURFACE.

16. AT LEAST ONE BABY CHANGE, WHEN PROVIDED, SHALL BE MOUNTED SO THAT THE COUNTER SURFACE, WHEN OPEN, IS NOT MORE THAN 34" ABOVE THE FINISH FLOOR AND THE HANDLE, WHEN CLOSED, IS NO HIGHER THAN 48" ABOVE THE FINISH FLOOR. THE COUNTER SURFACE SHALL PROVIDE 27" HIGH KNEE CLEARANCE WHEN FULLY OPEN.

17. CHANGING TABLES SHALL NOT OBSTRUCT THE REQUIRED WIDTH OF AN ACCESSIBLE ROUTE, OR BE LOCATED IN A TOILET COMPARTMENT.

18. RESTROOM DISPENSERS AND ACCESSORIES SHALL BE MOUNTED SO THEY DO NOT PROVIDE INTO THE ACCESSIBLE ROUTES GREATER THAN 4 INCHES.

19. GRAB BARS FOR WATER CLOSETS NOT LOCATED WITHIN A COMPARTMENT SHALL COMPLY WITH SECTION 11B-404.5 AND SHALL BE PROVIDED ON THE SIDE WALL CLOSEST TO THE WATER CLOSET AND ON THE REAR WALL. GRAB BARS FOR WATER CLOSETS LOCATED WITHIN AN ACCESSIBLE COMPARTMENT SHALL COMPLY WITH SECTION 11B-404.6.5 AND SHALL BE PROVIDED ON THE SIDE WALL CLOSEST TO THE WATER CLOSET AND ON THE REAR WALL. GRAB BARS FOR WATER CLOSETS LOCATED WITHIN A TOILET COMPARTMENT SHALL COMPLY WITH SECTION 11B-404.6.2.2 AND SHALL BE PROVIDED ON BOTH SIDES OF THE COMPARTMENT.

20. THE DIAMETER OR WIDTH OF THE GRIPPING SURFACES OF A GRAB BAR SHALL BE 1 1/4" TO 2" OR THE SHAPE SHALL PROVIDE AN EQUITABLE GRIPPING SURFACE. GRAB BARS SHALL NOT PROJECT MORE THAN 3" INTO ANY REQUIRED CLEAR SPACE.

21. THE GRAB BARS ARE MOUNTED ADJACENT TO A WALL, THE SPACE BETWEEN THE WALL AND THE GRAB BARS SHALL BE 1-1/2 INCHES. NO OBJECT TO BE LOCATED WITHIN 1-1/2" BELOW OR 12" ABOVE GRAB BARS.

22. A GRAB BAR AND ANY WALL OR OTHER SURFACE ADJACENT TO IT, SHALL BE FREE OF ANY SHARP OR ABRASIVE ELEMENTS.

23. EDGES SHALL HAVE A MINIMUM RADIUS OF 18 INCH.

24. THE STRUCTURAL STRENGTH OF GRAB BARS, TUB AND SHOWER SEATS, FASTENERS, AND MOUNTING DEVICES SHALL MEET THE FOLLOWING SPECIFICATIONS:

25. BENDING STRESS IN A GRAB BAR OR SEAT INDUCED BY THE MAXIMUM BENDING MOMENT FROM THE APPLICATION OF A 250-LB POINT LOAD SHALL BE LESS THAN THE ALLOWABLE STRESS FOR THE MATERIAL OF THE GRAB BAR OR SEAT.

26. SHEAR STRESS INDUCED IN A GRAB BAR OR SEAT BY THE APPLICATION OF A 250-LB POINT LOAD SHALL BE LESS THAN THE ALLOWABLE SHEAR STRESS FOR THE MATERIAL OF THE GRAB BAR OR SEAT, AND ITS MOUNTING BRACKET OR OTHER SUPPORT IS CONSIDERED TO BE FULLY RESTRAINED, THEN DIRECT AND TORSIONAL SHEAR STRESSES SHALL NOT EXCEED THE ALLOWABLE SHEAR STRESS.

27. SHEAR FORCE INDUCED IN FASTENER OR MOUNTING DEVICE FROM THE APPLICATION OF A 250-LB POINT LOAD SHALL BE LESS THAN THE ALLOWABLE LATERAL LOAD OF EITHER THE FASTENER OR MOUNTING DEVICE OR THE SUPPORTING STRUCTURE, WHICHEVER HAS THE SMALLER ALLOWABLE LOAD.

28. TENSILE FORCE INDUCED IN A FASTENER BY A DIRECT TENSION FORCE OF A 250-LB POINT LOAD, PLUS THE MAXIMUM MOMENT FROM THE APPLICATION OF A 250-LB POINT LOAD, SHALL BE LESS THAN THE ALLOWABLE WITHDRAWAL LOAD BETWEEN THE FASTENER AND SUPPORTING STRUCTURE.

29. GRAB BARS SHALL NOT ROTATE WITHIN THEIR FITTINGS.

SIGNS & IDENTIFICATION:

1. CHARACTERS SHALL BE SELECTED FORM FONTS WHERE THE WIDTH OF THE UPPERCASE LETTER "O" IS 60% MINIMUM AND 110% MAXIMUM OF THE HEIGHT OF THE UPPERCASE LETTER "T".

2. CHARACTERS AND NUMBERS ON SIGNS SHALL CONTRAST WITH THEIR BACKGROUND, EITHER LIGHT CHARACTERS ON A DARK BACKGROUND OR DARK CHARACTERS ON A LIGHT BACKGROUND.

3. CHARACTERS AND NUMBER ON SIGNS SHALL BE SIZED ACCORDING TO THE VIEWING DISTANCE FROM WHICH THEY ARE TO BE READ. THE MINIMUM HEIGHT IS MEASURED USING AN UPPER CASE I. LOWER CASE CHARACTERS ARE PERMITTED. FOR SIGNS SUSPENDED OR PROJECTED ABOVE THE FINISHED FLOOR IN COMPLIANCE WITH SECTION 11B-703.5.4.

4. CONTRACTED GRADE 2 BRAILLE SHALL BE USED WHEREVER BRAILLE SYMBOLS ARE SPECIFICALLY REQUIRED IN OTHER PORTIONS OF THESE REGULATIONS. DOTS SHALL BE 110" ON CENTERS IN EACH CELL WITH 210" SPACE BETWEEN CELLS. DOTS SHALL BE RAISED A MINIMUM OF 1/40" ABOVE THE BACKGROUND. THE INDICATION OF UPPERCASE LETTERS SHALL ONLY BE USED BEFORE THE FIRST WORD OF SENTENCES, PROPER NOUNS AND NAMES, INDIVIDUAL LETTER OF THE ALPHABET, INITIALS, AND ACRONYMS.

4A. ALL BUILDING ENTRANCES THAT ARE ACCESSIBLE TO AND USABLE BY PERSONS WITH DISABILITIES AND AT EVERY MAJOR JUNCTION ALONG OR LEADING TO AN ACCESSIBLE ROUTE OF TRAVEL SHALL BE IDENTIFIED WITH A SIGN DISPLAYING THE INTERNATIONAL SYMBOL OF ACCESSIBILITY AND WITH ADDITIONAL DIRECTIONAL SIGNS, AS REQUIRED, TO BE VISIBLE TO PERSONS ALONG APPROACHING PEDESTRIAN WAYS.

ACCESSIBLE MEANS OF EGRESS AND COMMUNICATION ELEMENTS

1. TACTILE SIGNS CONTAINING BRAILLE SHALL BE PROVIDED PER SECTION 11B-703.

2. TACTILE EXIT SIGNS SHALL BE REQUIRED AT THE FOLLOWING LOCATIONS:

3. EACH GRADE-LEVEL EXTERIOR EXIT DOOR SHALL BE IDENTIFIED BY A TACTILE EXIT WITH THE WORD, "EXIT."

4. EACH EXIT DOOR THAT LEADS DIRECTLY TO A GRADE-LEVEL EXTERIOR EXIT BY MEANS OF A STAIRWAY OR RAMP SHALL BE IDENTIFIED BY A TACTILE EXIT SIGN WITH THE FOLLOWING WORDS AS APPROPRIATE:

A. "EXIT STAIR DOWN"

B. "EXIT RAMP DOWN"

C. "EXIT STAIR UP"

D. "EXIT RAMP UP"

5. EACH EXIT DOOR THAT LEADS DIRECTLY TO A GRADE-LEVEL EXTERIOR EXIT BY MEANS OF AN EXIT ENCLOSURE OR AN EXIT PASSAGEWAY SHALL BE IDENTIFIED BY A TACTILE EXIT SIGN WITH THE WORDS, "EXIT ROUTE."

6. EACH EXIT ACCESS DOOR FROM AN INTERIOR ROOM OR AREA TO A CORRIDOR OR HALLWAY THAT IS REQUIRED TO HAVE A VISUAL EXIT SIGN SHALL BE IDENTIFIED BY A TACTILE EXIT SIGN WITH THE WORDS, "EXIT ROUTE."

7. EACH EXIT DOOR THROUGH A HORIZONTAL EXIT SHALL BE IDENTIFIED BY A SIGN WITH THE WORDS, "TO EXIT."

8. PERMANENT ROOM SIGNAGE (2013 CBC), WHEN RAISED CHARACTERS ARE REQUIRED OR WHEN PICTORIAL SYMBOLS (PICTOGRAMS) ARE USED ON SUCH SIGNS, THEY SHALL CONFORM TO THE FOLLOWING REQUIREMENTS:

9. CHARACTER TYPE: CHARACTERS ON SIGNS SHALL BE RAISED 1/32 INCH MINIMUM AND SHALL BE SANS SERIF UPPERCASE CHARACTERS ACCOMPANIED BY GRADE 2 BRAILLE COMPLYING WITH SECTION 11B-703.2.

10. CHARACTER HEIGHT: RAISED CHARACTERS SHALL BE A MINIMUM OF 5/8 INCH AND A MAXIMUM OF 2 INCHES HIGH.

11. PICTORIAL SYMBOL SIGNS (PICTOGRAMS): PICTORIAL SYMBOLS SIGNS (PICTOGRAMS) SHALL BE ACCOMPANIED BY THE VERBAL DESCRIPTION PLACED DIRECTLY BELOW THE PICTOGRAM. THE OUTSIDE DIMENSION OF THE PICTOGRAM FIELD SHALL BE A MINIMUM OF 6 INCHES IN HEIGHT.

12. CHARACTER POSITION: CHARACTERS AND BRAILLE SHALL BE IN A HORIZONTAL FORMAT. BRAILLE SHALL BE PLACED A MINIMUM 1/8 INCH AND A MAXIMUM OF 1/2 INCH DIRECTLY BELOW THE TACTILE CHARACTERS AND 3/8" MINIMUM FROM RAISED BORDERS AND OPERATIVE ELEMENTS. FLUSH LEFT OR CENTERED WHEN TACTILE TEXT IS MULTILINE. ALL BRAILLE SHALL BE PLACED TOGETHER, BELOW ALL LINES OF TACTILE TEXT.

13. MOUNTING LOCATION AND HEIGHTS: WHERE PERMANENT IDENTIFICATION IS PROVIDED FOR ROOMS AND SPACES, RAISED LETTERS SHALL BE PLACED IN CONFORMANCE WITH SECTION 11B-703.4. SIGNS SHALL BE INSTALLED ON THE WALL ADJACENT TO THE DOOR OUTSIDE THE DOOR, WHERE THERE IS NO WALL SPACE ON THE LATCH SIDE, INCLUDING AT DOUBLE LEAF DOORS. SIGNS SHALL BE PLACED ON NEAREST ADJACENT WALL, PREFERABLY ON THE RIGHT. MOUNTING HEIGHT SHALL BE LOCATED MINIMUM 5 INCHES ABOVE THE FINISH FLOOR OR GROUND SURFACE MEASURED FROM THE BASELINE OF THE LOWEST BRAILLE CELLS AND 80 INCHES MAXIMUM ABOVE THE FINISH FLOOR OR GROUND SURFACE, MEASURED TO THE BASELINE OF THE HIGHEST LINE OF RAISED CHARACTERS.

14. SIGNS CONTAINING TACTILE CHARACTERS SHALL BE LOCATED SO THAT A CLEAR FLOOR SPACE OF 18 INCHES MINIMUM BY 18 INCHES MINIMUM, CENTERED ON THE TACTILE CHARACTERS, IS PROVIDED BEYOND THE ARCH OR ANY DOOR SWING BETWEEN THE CLOSED POSITION AND 45 DEGREE OPEN POSITION.

SERVICE COUNTERS AND WORK SURFACES

1. WHERE A SINGLE SERVICE COUNTER CONTAINS MORE THAN ONE TRANSACTION, SUCH AS WITH MULTIPLE TELLER WINDOWS OR CASH COUNTERS WITH MULTIPLE CASH REGISTER STATIONS, AT LEAST 5 PERCENT BUT NEVER LESS THAN ONE OF EACH TYPE OF STATION OR COUNTERS SHALL BE ACCESSIBLE.

2. SERVICE COUNTERS SHALL COMPLY WITH SECTION 11B-904.1.1 OR 11B-904.2.2. THE ACCESSIBLE PORTION OF THE COUNTER TOP SHALL EXTEND THE SAME DEPTH AS THE SERVICE COUNTER TOP.

3. A PORTION OF THE SERVICE COUNTER SURFACE THAT IS 36 INCHES LONG MINIMUM AND 34 INCHES HIGH MAXIMUM ABOVE THE FINISH FLOOR SHALL BE PROVIDED. A CLEAR FLOOR SPACE OR GROUND SPACE COMPLYING WITH SECTION 11B-305 SHALL BE POSITIONED FOR A PARALLEL OR APPROACH ADJACENT TO THE 36 INCH MINIMUM LENGTH OF COUNTER. IF A FORWARD APPROACH IS INTENDED, KNEE CLEARANCE MUST BE PROVIDED.

4. HEIGHT OF WORK SURFACES: THE TOPS OF TABLES AND COUNTERS SHALL BE 28 INCHES TO 34 INCHES FROM THE FLOOR OR GROUND.

APPROVAL

CLIENT

SAN BERNARDINO COUNTY

SAN BERNARDINO COUNTY
PROJECT AND FACILITIES
MANAGEMENT DEPARTMENT

385 NORTH ARROWHEAD AVENUE, 3RD FLOOR SAN
BERNARDINO, CA 92415-0184

PROJECT NAME

REPLACEMENT DEAEARATOR

PROJECT ADDRESS

400 N PEPPER AVE, COLTON, CA 92324

OSHDP/HCAI PROJECT NO.
S230562-36-00

FACILITY NO.
17282

BUILDING NO.
BLD-00075 CENTRAL PLANT

ENGINEER/ARCHITECT

IDS GROUP

1 PETERS CANYON ROAD, SUITE 130
IRVINE, CA 92606
TEL: 949-387-8500, FAX: 949-387-0800

STAMP

NOT USED

STAMP

NOT USED

ISSUE

REV.	DESCRIPTION	DATE
1	HCAI SUBMITTAL	03/01/23
2	HCAI BC 1	06/13/23
3	HCAI BC 2	07/28/23

PROJECT IDENTIFICATION

THE ORIGINAL SIZE OF THIS SHEET IS 30" X 42"

THESE DRAWINGS AND SPECIFICATIONS ARE THE PROPERTY AND COPYRIGHT OF IDS GROUP AND SHALL NOT BE USED ON ANY OTHER PROJECT OR LOCATIONS EXCEPT AS DESCRIBED ON THE DRAWINGS, WITHOUT THE WRITTEN AGREEMENT WITH IDS GROUP.

IDS PROJECT NO. 22X66.02

DRAWN BY CKC

CHECKED BY CKC

APPROVED BY JHM


SHEET TITLE

**ACCESSIBILITY COMPLIANCE
NOTES NOT USED**

SHEET NUMBER

G-010

SHEET NO. OF

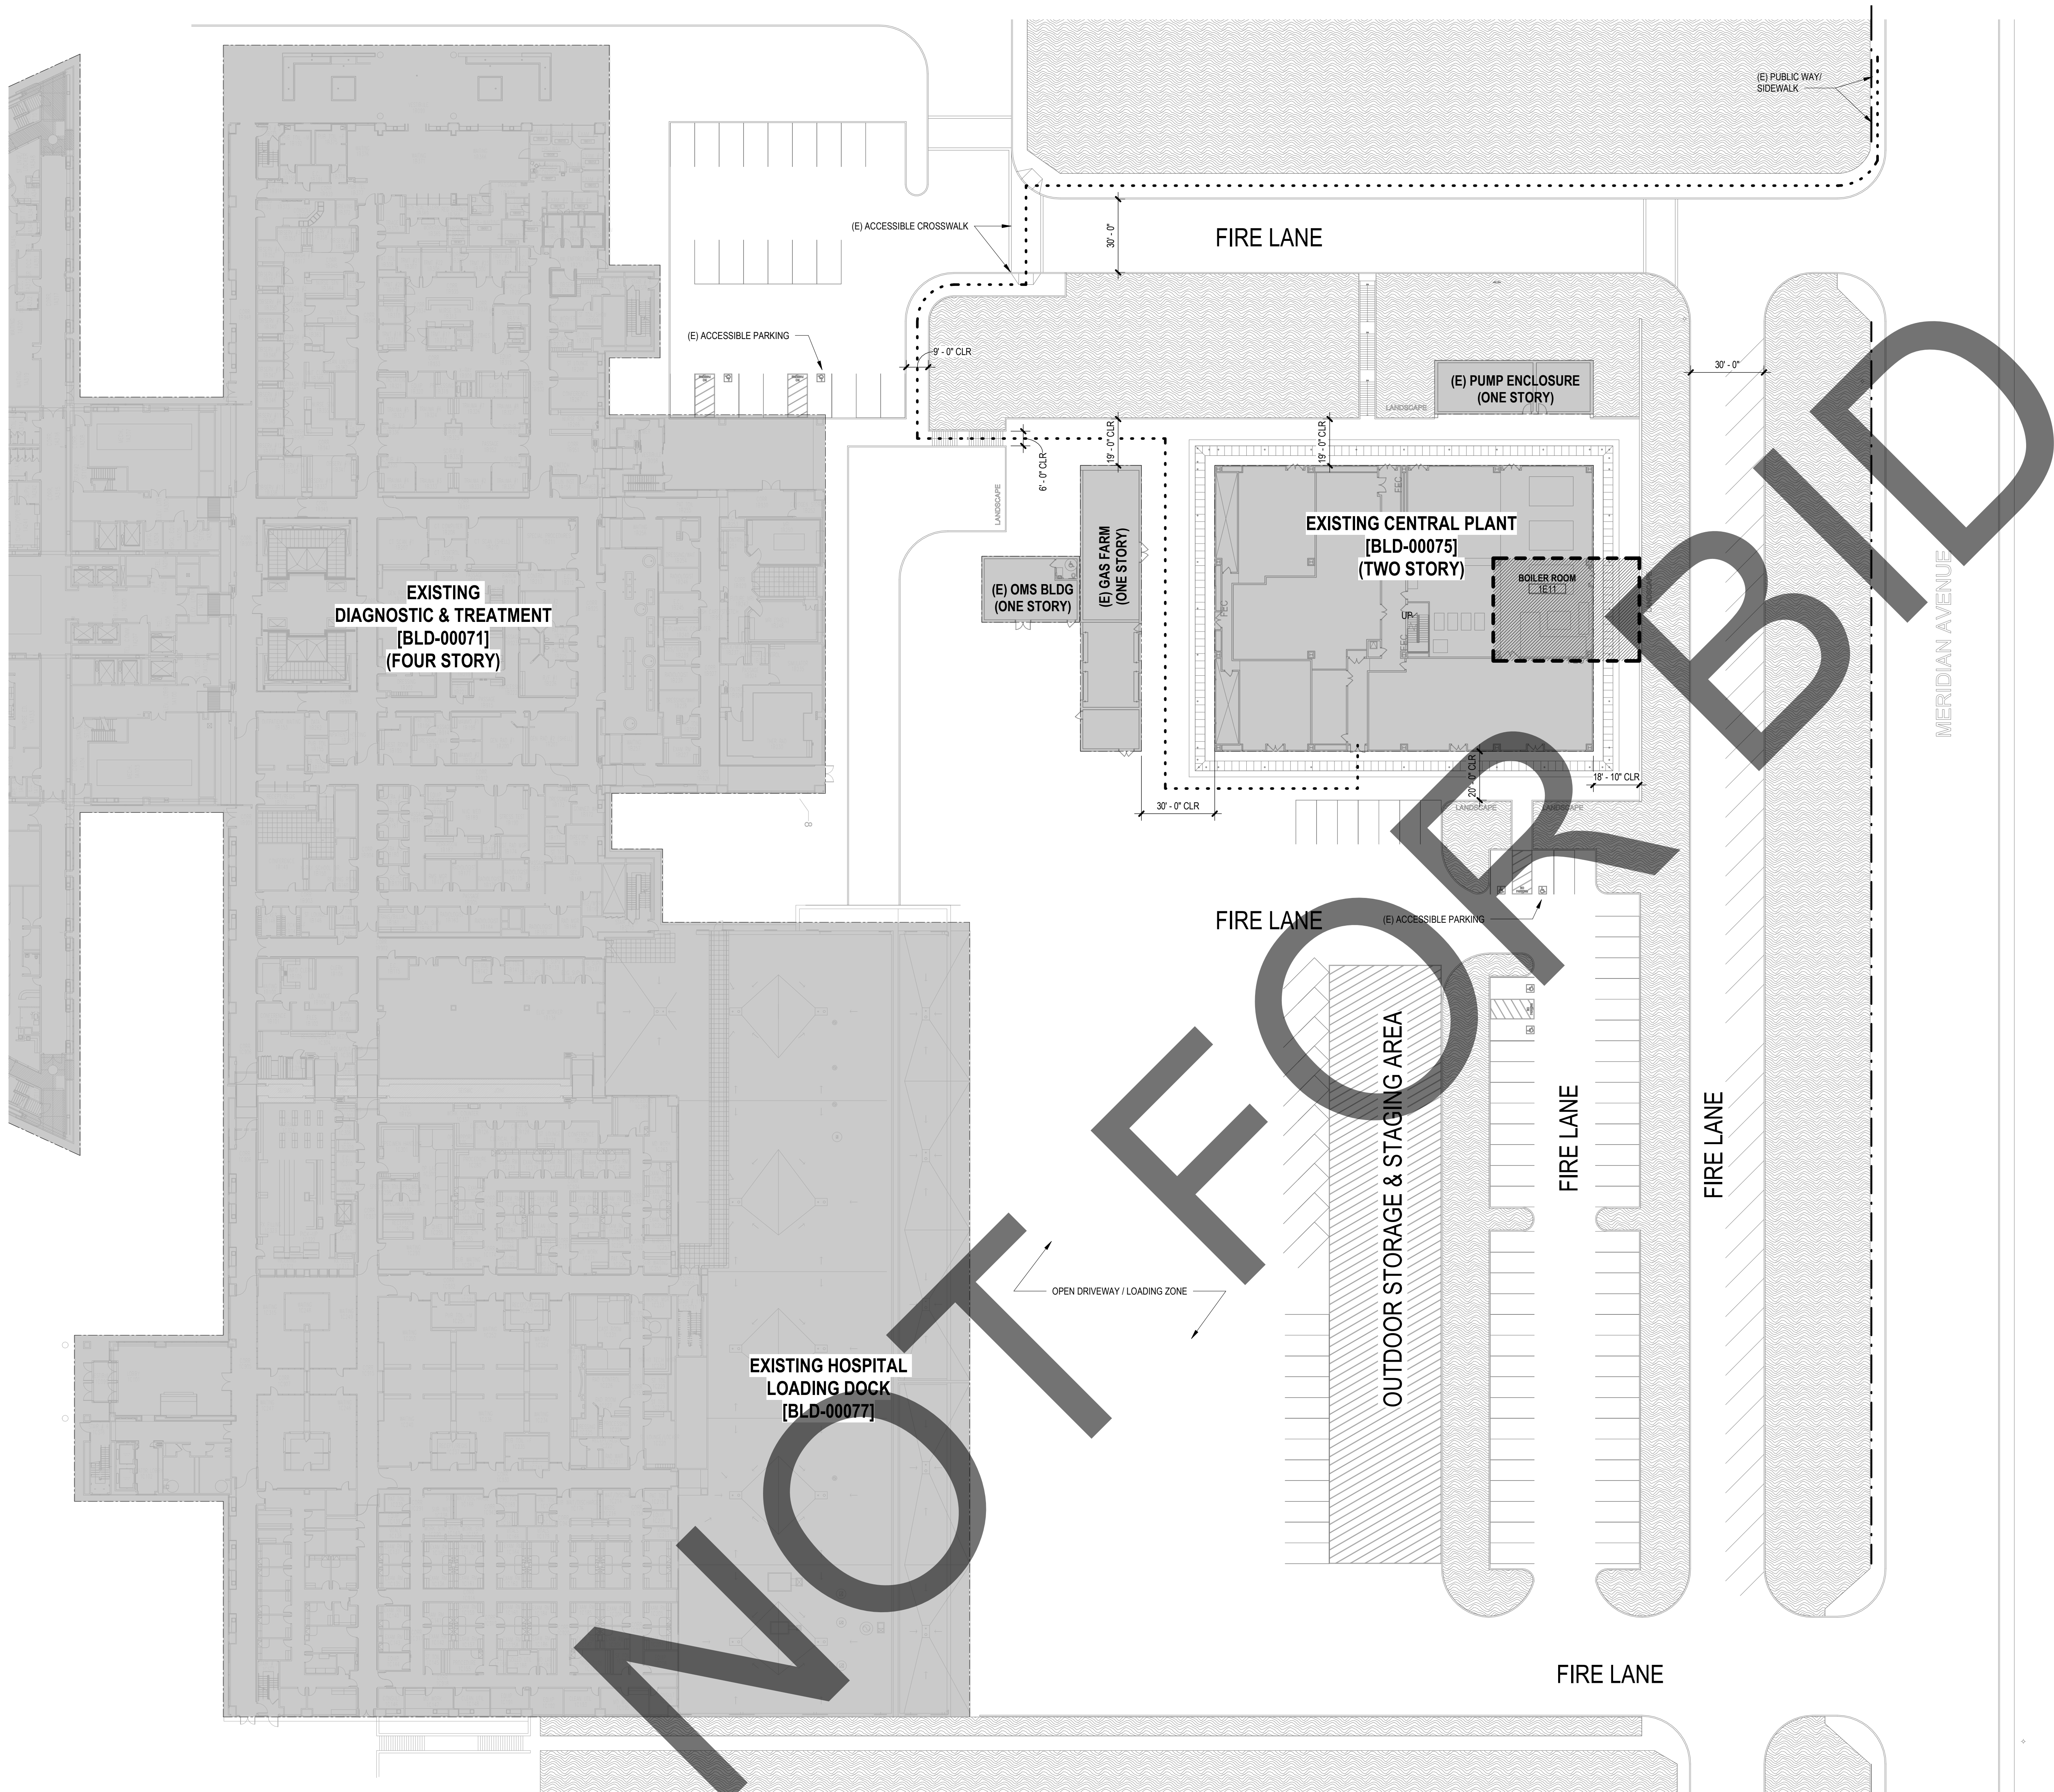

SITE LEGEND

--- PROPERTY LINE

--- PATH OF TRAVEL

--- STREET CENTERLINE

EXISTING BUILDING


AREA OF WORK

PATH OF TRAVEL DEFINITION

PATH OF TRAVEL (P.O.T.) AS INDICATED IS A COMMON BARRIER FREE ACCESS ROUTE WITHOUT ANY ABRUPT VERTICAL CHANGES EXCEEDING 1/2" BEVELED AT 1/2" MAXIMUM SLOPE. EXCEPT THAT LEVEL CHANGES DO NOT EXCEED 1/4" VERTICAL AND AT LEAST 48" WIDE.

THE CROSS SLOPE DOES NOT EXCEED 2% AND SLOPE IN THE DIRECTION OF TRAVEL AND IS LESS THAN 5% UNLESS OTHERWISE INDICATED.

(P.O.T.) SHALL BE MAINTAINED FREE OF OVERHANGING OBSTRUCTIONS TO 8' MINIMUM (1133B 8.2) AND PROTRUDING OBJECTS GREATER THAN 4" PROJECTION FROM WALL AND ABOVE 27" AND LESS THAN 80" (1133B 8.6).

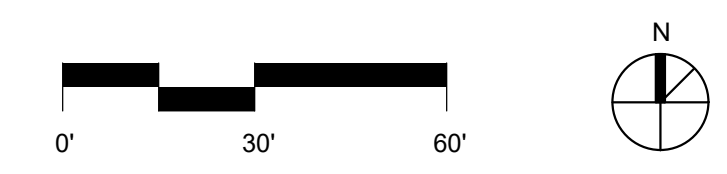

APPROVAL

REVIEWED IN ACCORDANCE WITH THE REQUIREMENTS OF T24, COR

APPROVED

Department of Health Care Access & Information

Office of Statewide Hospital Planning & Development

8/3/2023, 7:23:45 AM

S230562-36-00

Allen Cheng

FOR REFERENCE ONLY

CLIENT

SAN BERNARDINO COUNTY

SAN BERNARDINO COUNTY
PROJECT AND FACILITIES
MANAGEMENT DEPARTMENT

385 NORTH ARROWHEAD AVENUE, 3RD FLOOR SAN
BERNARDINO, CA 92415-0184

PROJECT NAME

**ARMC
DEAERATOR #1
REPLACEMENT**

PROJECT NO.
WBSE # 10.10.0847
CIP # 20-011
HCAI # S230562-36-00

FACILITY NO.
17282

BUILDING NO.
BLD-00075 CENTRAL PLANT

400 N. PEPPER AVENUE
COLTON, CA 92324-1801

ENGINEER/ARCHITECT

IDS

IDS GROUP

1 PETERS CANYON ROAD, SUITE 130
IRVINE, CA 92606
TEL: 949-387-8500, FAX: 949-387-0800

STAMP

STAMP

REV.	DESCRIPTION	DATE
	HCAI SUBMITTAL	03/01/23
A	HCAI BC 1	06/13/23
B	HCAI BC 2	07/28/23

PROJECT IDENTIFICATION

THE ORIGINAL SIZE OF THIS SHEET IS 30" X 42"

THESE DRAWINGS AND SPECIFICATIONS ARE THE PROPERTY AND COPYRIGHT OF IDS GROUP AND SHALL NOT BE USED ON ANY OTHER PROJECT OR LOCATIONS EXCEPT AS DESCRIBED ON THE DRAWINGS, WITHOUT THE WRITTEN AGREEMENT WITH IDS GROUP.

IDS PROJECT NO.	22X066.02
DRAWN BY	CKC
CHECKED BY	CKC
APPROVED BY	JHM


SHEET TITLE

**ACCESSIBILITY
SITE PLAN - FOR
REFERENCE ONLY**


SHEET NUMBER

G-100

SHEET NO. OF

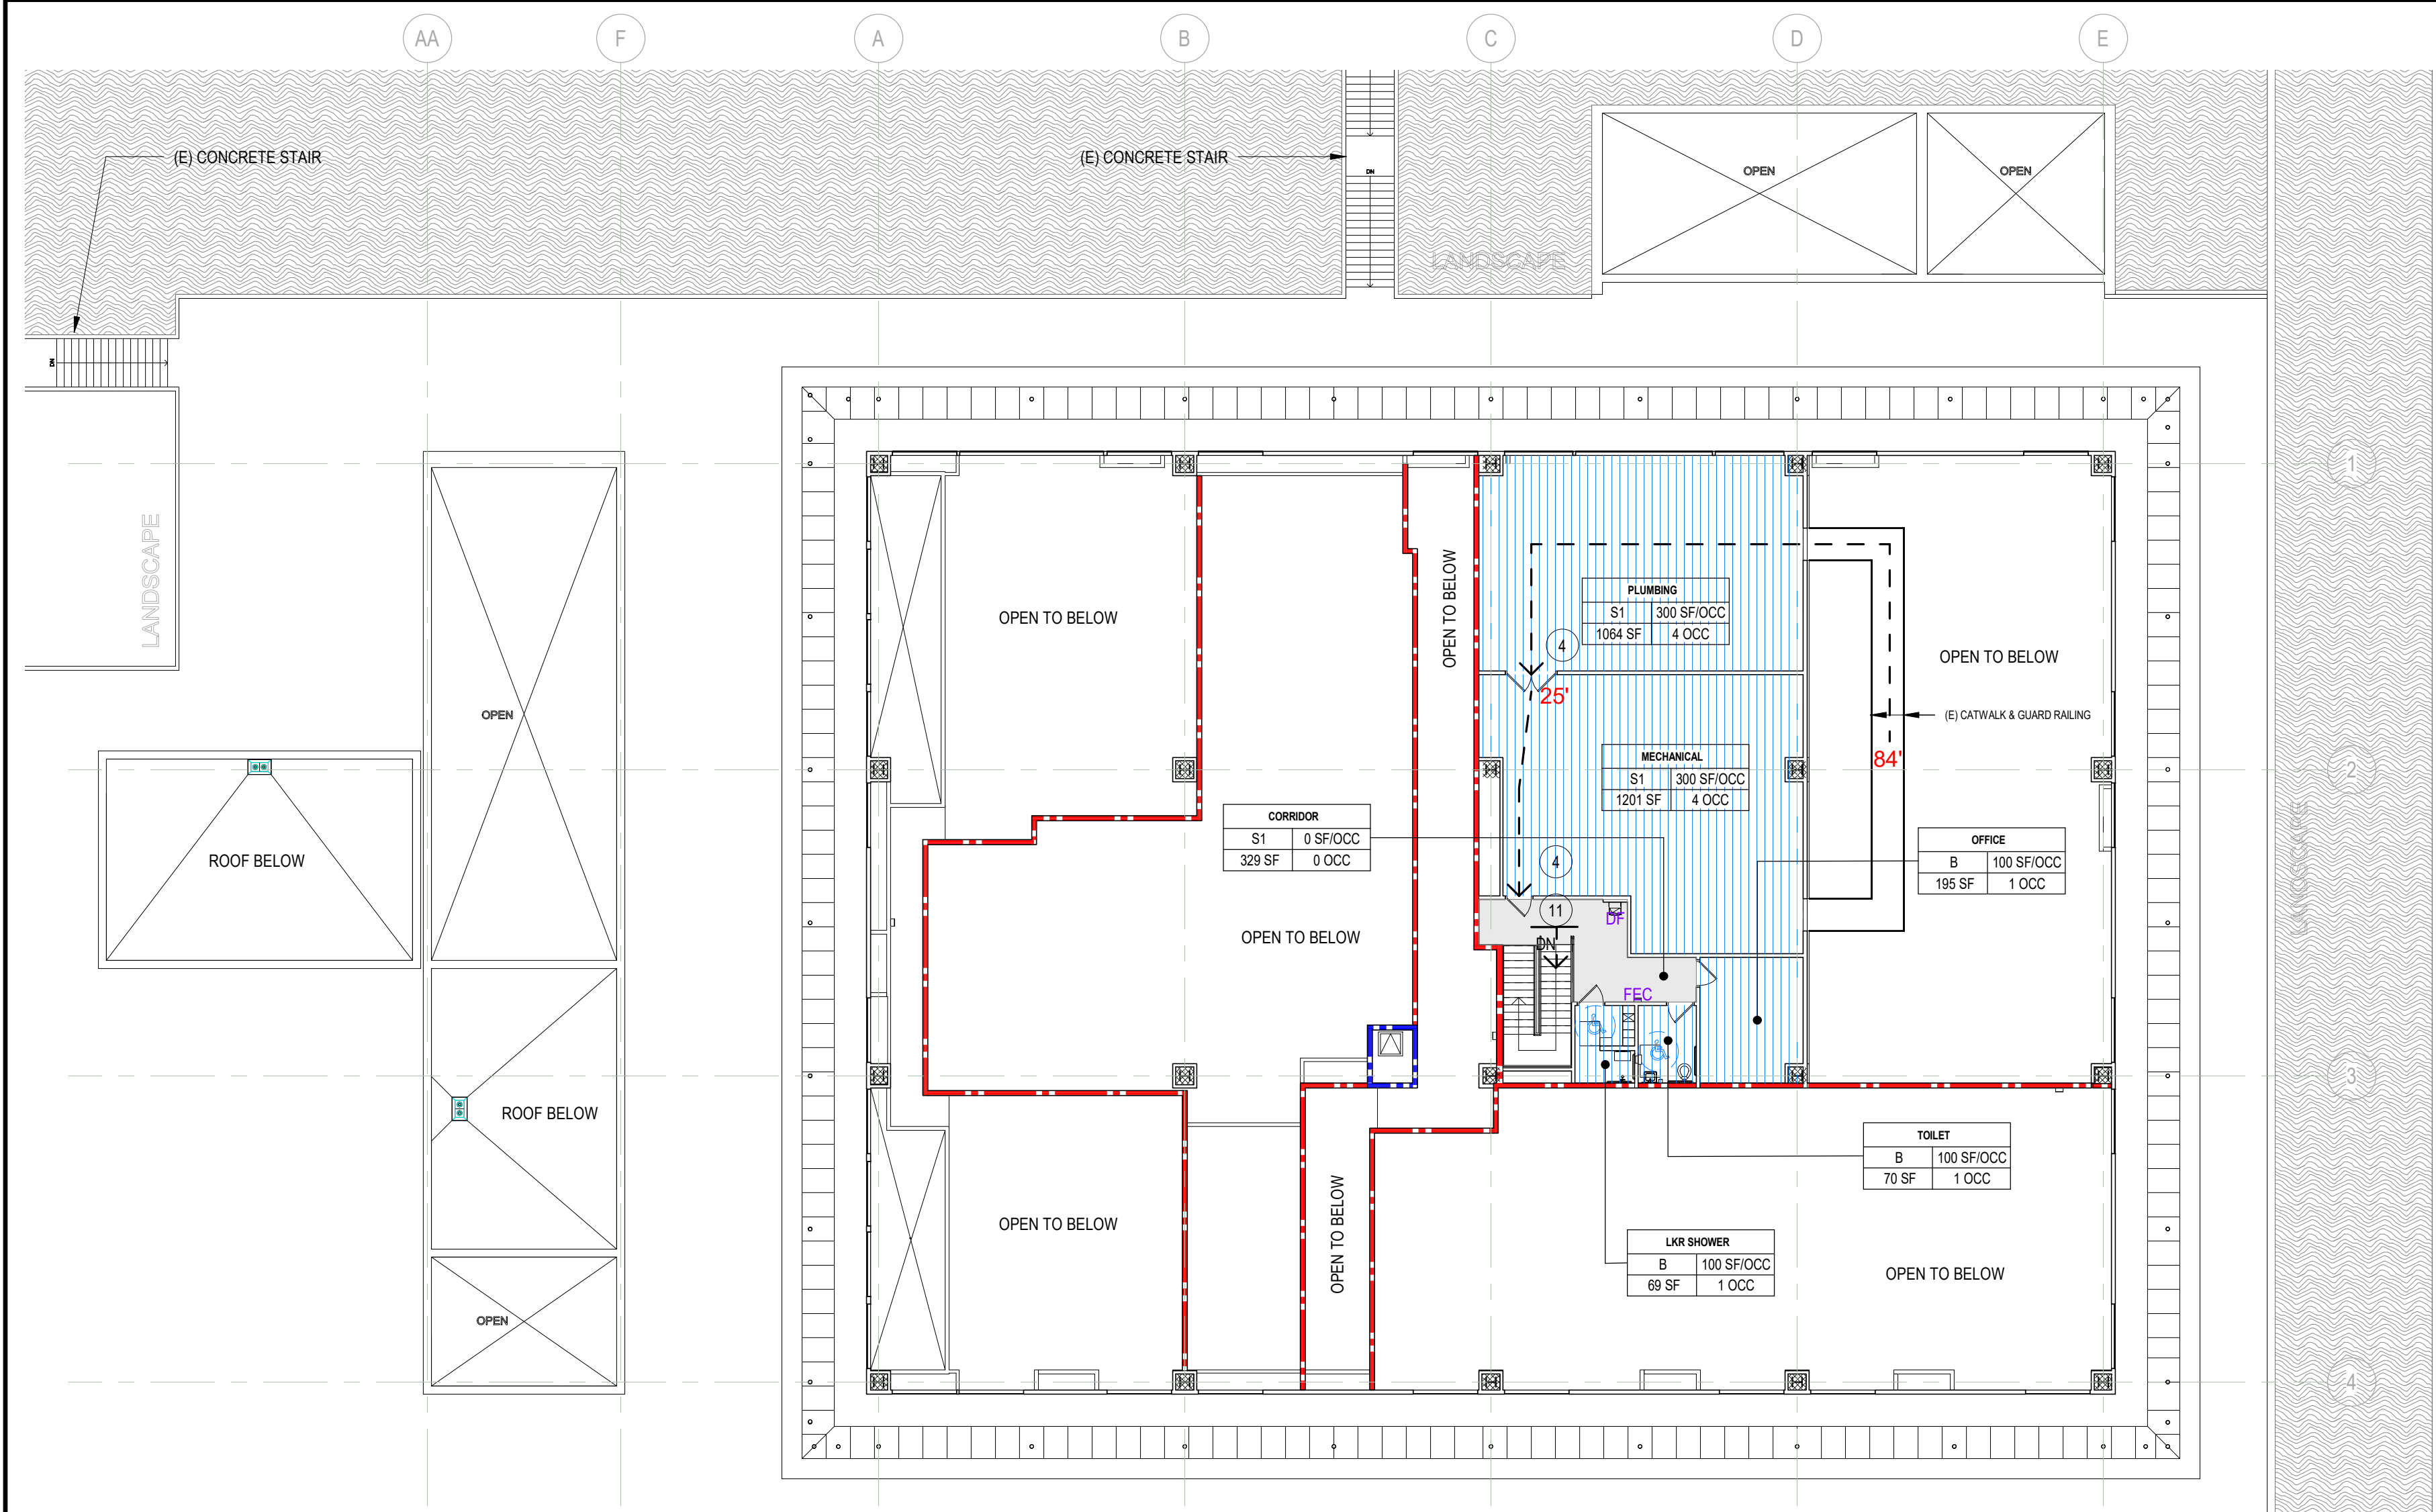

LEVEL 2 CODE PLAN 1/16" = 1'-0" 2

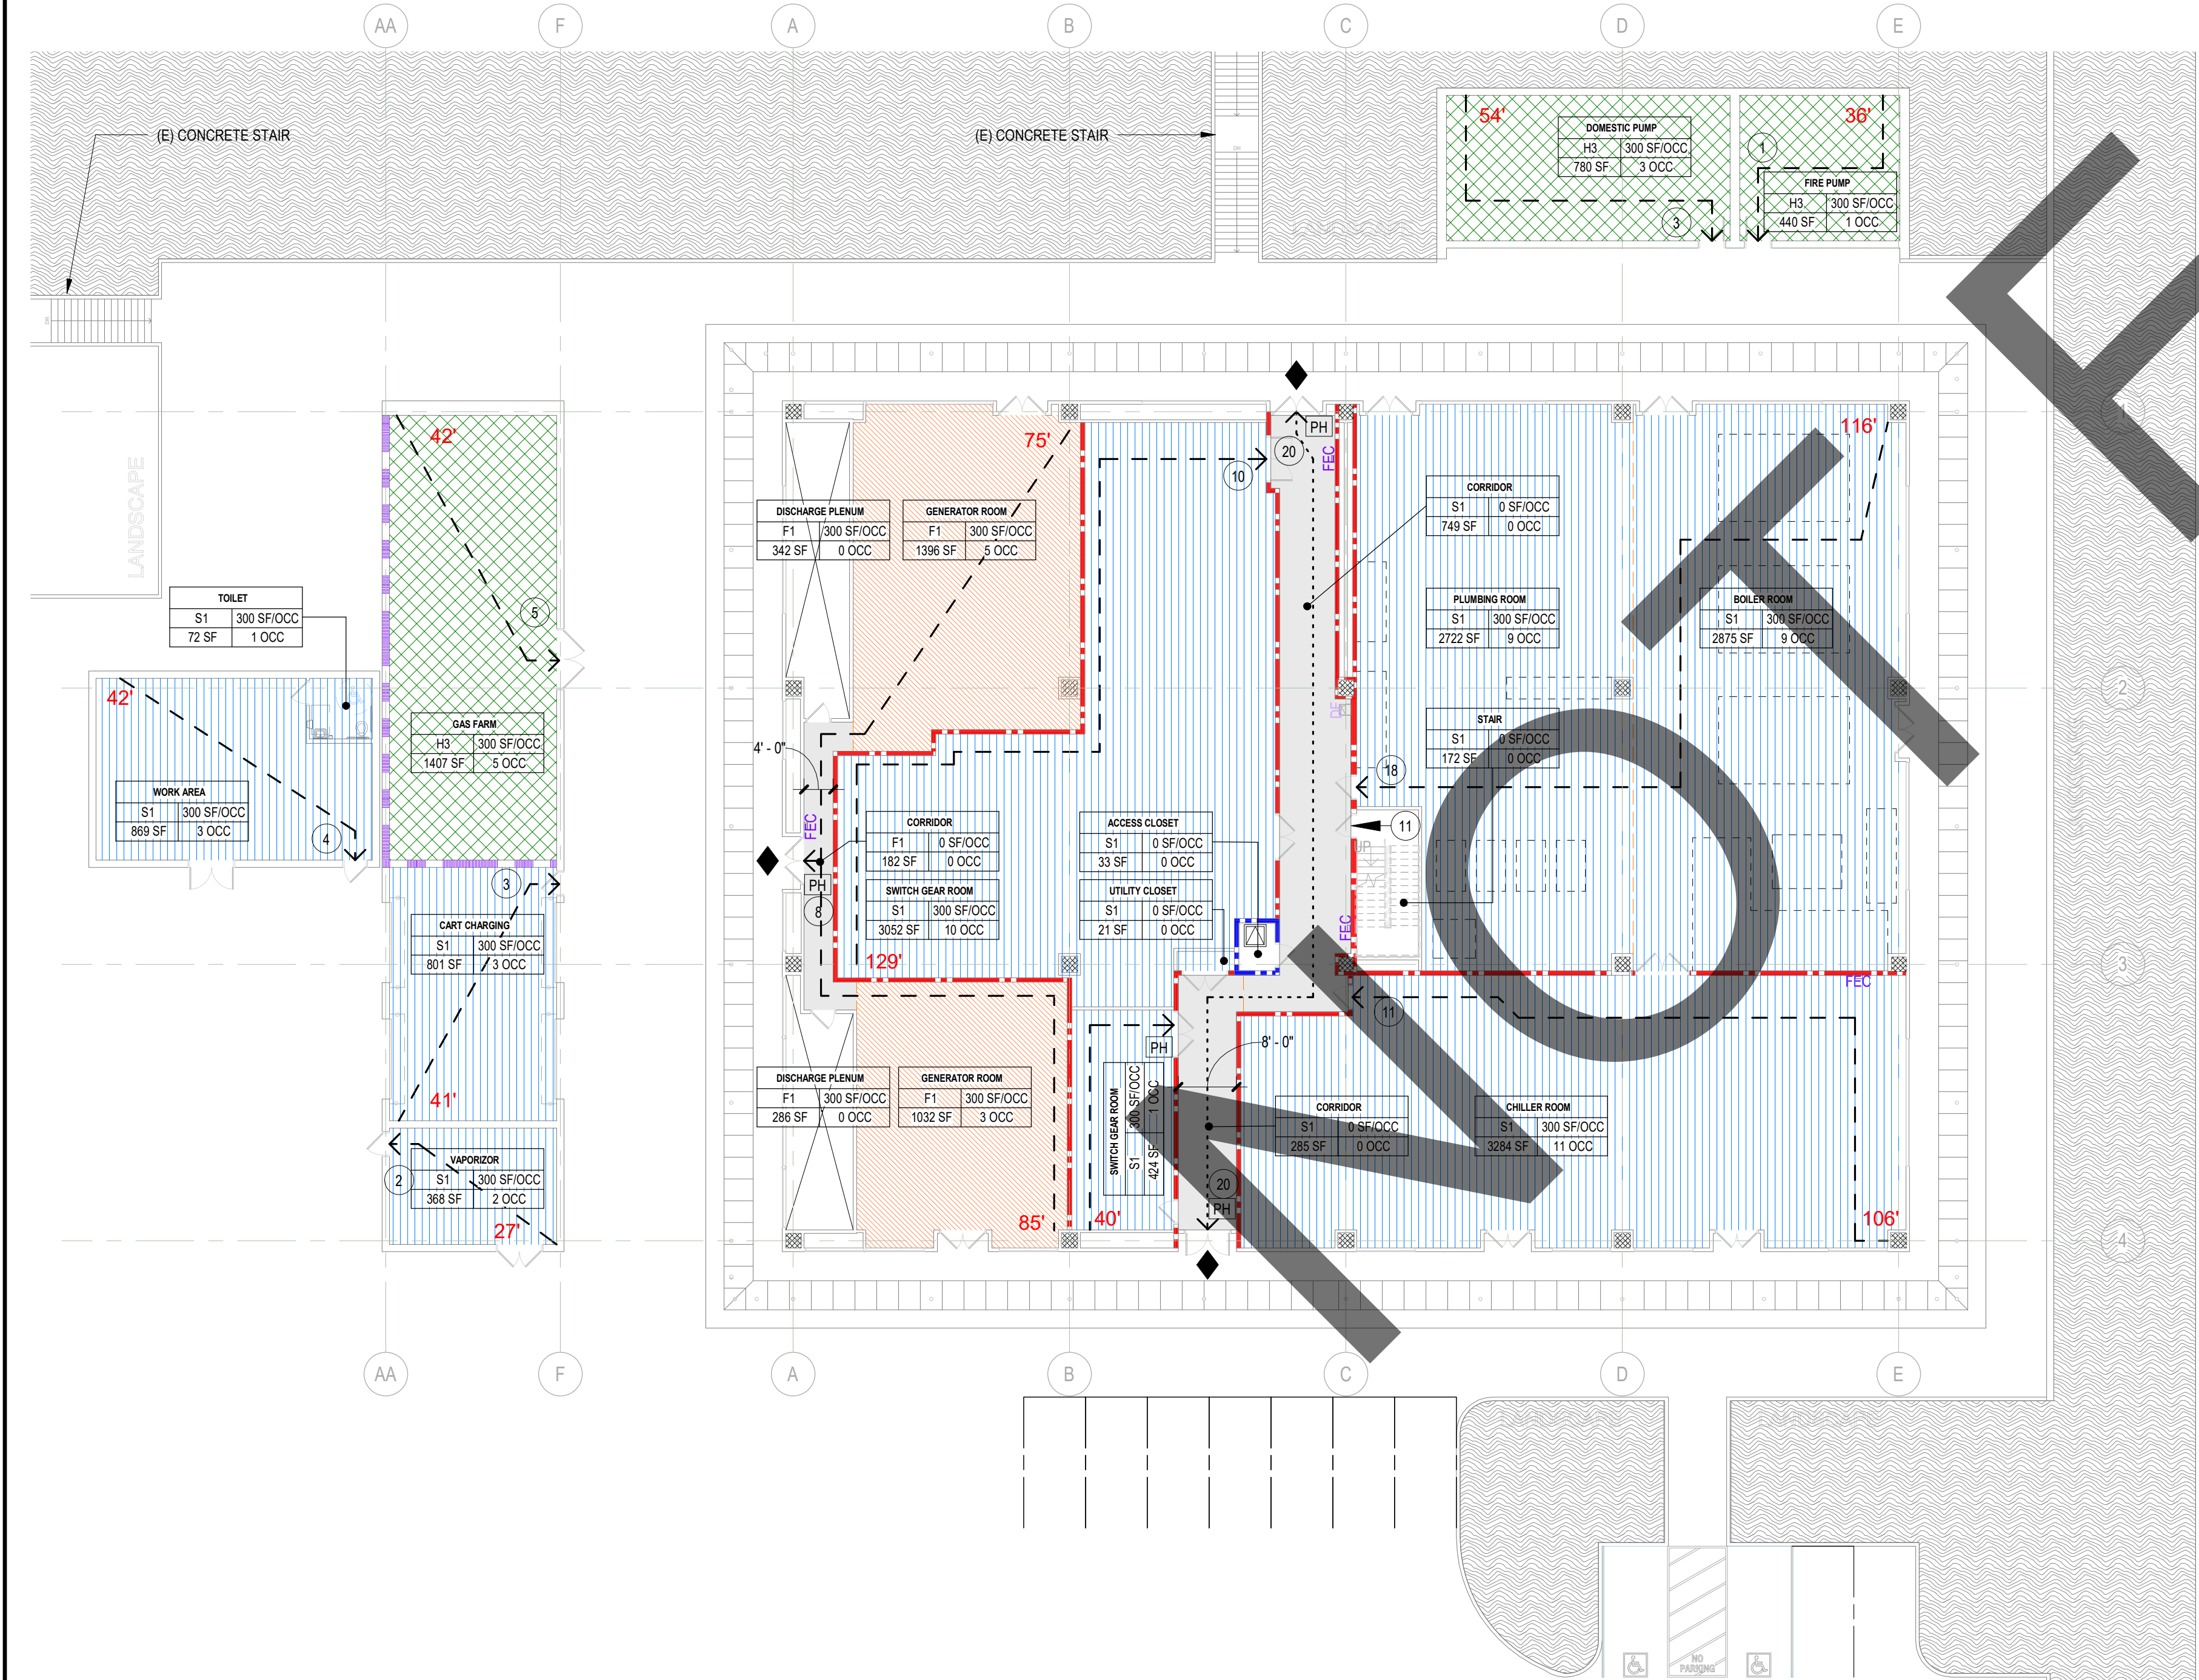

LEVEL 1 CODE PLAN 1/16" = 1'-0" 1

CODE ANALYSIS

PROJECT LOCATION:
400 N Pepper Ave, Colton, CA 92324

DESCRIPTION OF WORK:
REPLACEMENT OF EXISTING MECHANICAL EQUIPMENT AT THE BOILER ROOM INSIDE THE CENTRAL PLANT BUILDING. TEMPORARY REMOVAL AND RE-INSTALLATION OF EXISTING EXTERIOR LOUVER PANELS AS REQUIRED. TEMPORARY CONSTRUCTION AND TEMPORARY EQUIPMENT CONNECTIONS TO PROVIDE FULLY OPERATIONAL AND UNINTERRUPTED SERVICES TO HOSPITAL. SEISMIC BRACING AND ANCHORAGE OF ANY NEW MECHANICAL UTILITY CONNECTIONS. PATCH AND REPAIR OF ANY NEW MECHANICAL UTILITY PENETRATIONS.

OCCUPANCY AND USE:
- CENTRAL PLANT BUILDING:
GROUP F-1, GROUP S-1, AND GROUP H-3 (OUTER BUILDINGS B & C)

OCCUPANCY SEPARATION PER CBC TABLE 508.4, 1-HR

EXIT ACCESS TRAVEL DISTANCE
- (OCCUPANCIES F-1, H-3, S-1) = NOT GREATER THAN 300'

CONSTRUCTION CLASSIFICATION:
- TYPE I A, NON-COMBUSTIBLE, FULLY SPRINKLERED, UNLIMITED ALLOWABLE AREA

SEISMIC ZONE:
- REFER TO STRUCTURAL DRAWINGS

CLASSIFICATION AND STATUS:
- BLD-00075, OSHPD 1 AND IN SERVICE, BUILT 2000 (UNDER 1999 CBC),
SPC 5, NPC 5.

NUMBER OF STORIES:
- CENTRAL PLANT BUILDING : 2 STORIES ABOVE GRADE

BUILDING HEIGHT:

- 52'-6" ABOVE GRADE

BUILDING AREA:

- GROSS HCAI BLD-00075 CENTRAL PLANT - Bldg 05:
18,135 SF (A-1ST FLOOR)
+ 1,430 SF (B-1ST FLOOR)
+ 2,205 SF (C-1ST FLOOR)
+ 1,095 SF (D-1ST FLOOR) = 23,870 SF
+ 3,220 SF (2ND FLOOR)
= 26,790 SF (TOTAL SQUAREFOOTAGE)

FIRE-RESISTIVE RATING REQUIREMENTS FOR BUILDING ELEMENTS BASED ON CONSTRUCTION TYPE I A, CBC TABLE 601.

BUILDING ELEMENT	REQUIRED SEPARATION IN HOURS
PRIMARY STRUCTURAL FRAME	3
BEARING WALLS	2 - FIRE RETARDANT FRAMING REQUIRED
EXTERIOR	
FOR WOOD PER CBC 602.3	0
NON-BEARING WALLS AND PARTITIONS	0
EXTERIOR	SEE TABLE 705.5
INTERIOR	0
FLOOR CONSTRUCTION & SECONDARY MEMBERS	2
ROOF CONSTRUCTION & SECONDARY MEMBERS	1 1/2

ROOF CONSTRUCTION:
- CLASS A CLASS C MINIMUM REQUIREMENT CBC TABLE 1505

EXISTING PLUMBING FIXTURES, OCCUPANT LOAD FACTOR PER TABLE CPC TABLE 4-1

OCCUPANCY OCCUPANT LOAD FACTOR FLOOR AREA

F-1	4000	3,211
S-1	4000	15,727
H-3	4000	2,527

GENERAL NOTES - CODE PLAN

1. ALL FIRE LIFE SAFETY FEATURES SHOWN ARE BASED ON RECORD DRAWINGS PROVIDED BY ARROWHEAD REGIONAL MEDICAL CENTER.

GRAPHIC LEGEND - CODE PLAN


SYMBOL	DESCRIPTION
	EXISTING PARTITION WALL
	NON RATED PARTITION WALL
	1 HOUR RATED FIRE BARRIER
	2 HOUR RATED FIRE-SMOKE BARRIER
	2 HOUR RATED FIRE-SMOKE BARRIER OCCUPANCY SEP
	4 HOUR RATED FIRE WALL
	CURTAIN WALL / STOREFRONT/LOUVER PANEL
	PANIC HARDWARE
	FIRE EXTINGUISHER CABINET
	DRINKING FOUNTAIN

	F1 OCCUPANCY
	H3 OCCUPANCY
	S1 OCCUPANCY
	CORRIDOR CIRCULATION
	COLUMNS OR STRUCTURE WITH SPAY ON FIRE PROTECTION

	EGRESS TAG NUMBER OF OCCUPANTS EXITING IN DIRECTION OF TRAVEL
	EGRESS TRAVEL DISTANCE TO EXIT ENCLOSURE OR EXIT FROM FURTHEST POINT IN BUILDING AWAY FROM EXIT
	TRAVEL DISTANCE TO EXIT ACCESS DOORWAY FROM FURTHEST POINT IN ROOM AWAY FROM EXIT
	BUILDING EXIT/ENTRANCE

ROOM OCCUPANCY TAG
ROOM NAME
OCCUPANT LOAD
ROOM OCCUPANCY
OCCUPANCY GROUP
ROOM AREA

KEYPLAN

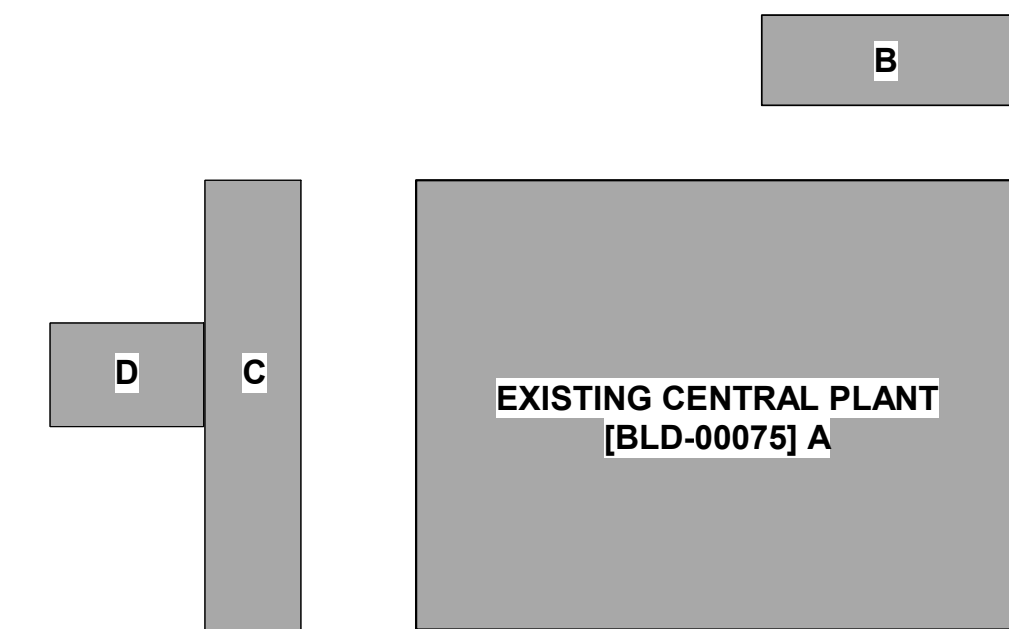

APPROVAL

REVIEWED IN ACCORDANCE WITH THE REQUIREMENTS OF T24, COR

APPROVED

Department of Health Care Access & Information
Office of Statewide Hospital Planning & Development
8/3/2023, 7:23:45 AM
S230562-36-00
Allen Cheng

FOR REFERENCE ONLY

CLIENT

SAN BERNARDINO COUNTY

SAN BERNARDINO COUNTY
PROJECT AND FACILITIES
MANAGEMENT DEPARTMENT

385 NORTH ARROWHEAD AVENUE, 3RD FLOOR SAN
BERNARDINO, CA 92415-0184

PROJECT NAME

**ARMC
DEAERATOR #1
REPLACEMENT**

PROJECT NO.
WBSE # 10.10.0847
CIP # 20-011
HCAI # S230562-36-00

FACILITY NO.
17282

BUILDING NO.
BLD-00075 CENTRAL PLANT

400 N. PEPPER AVENUE
COLTON, CA 92324-1801

ENGINEER/ARCHITECT

IDS

IDS GROUP

1 PETERS CANYON ROAD, SUITE 130
IRVINE, CA 92606
TEL: 949-387-8500, FAX: 949-387-0800

STAMP

LICENSED ARCHITECT
JOSEPH H. MACDONALD
C-34131
JUNE 2023
STATE OF CALIFORNIA

STAMP

REGISTERED PROFESSIONAL DOOR SCHEDULER
No. 30841
Exp. 12/31/25
BERNARD CA
STATE OF CALIFORNIA

REV.	DESCRIPTION	DATE
	HCAI SUBMITTAL	03/01/23
A	HCAI BC 1	06/13/23
B	HCAI BC 2	07/28/23

PROJECT IDENTIFICATION

THE ORIGINAL SIZE OF THIS SHEET IS 30" X 42"


THESE DRAWINGS AND SPECIFICATIONS ARE THE PROPERTY AND COPYRIGHT OF IDS GROUP AND SHALL NOT BE USED ON ANY OTHER PROJECT OR LOCATIONS EXCEPT AS DESCRIBED ON THE DRAWINGS, WITHOUT THE WRITTEN AGREEMENT WITH IDS GROUP.

IDS PROJECT NO.	22X66.02
DRAWN BY	CKC
CHECKED BY	CKC
APPROVED BY	JHM

SHEET TITLE

**CODE
COMPLIANCE PLAN
- FOR REFERENCE
ONLY**

SHEET NUMBER	G-110
SHEET NO.	OF

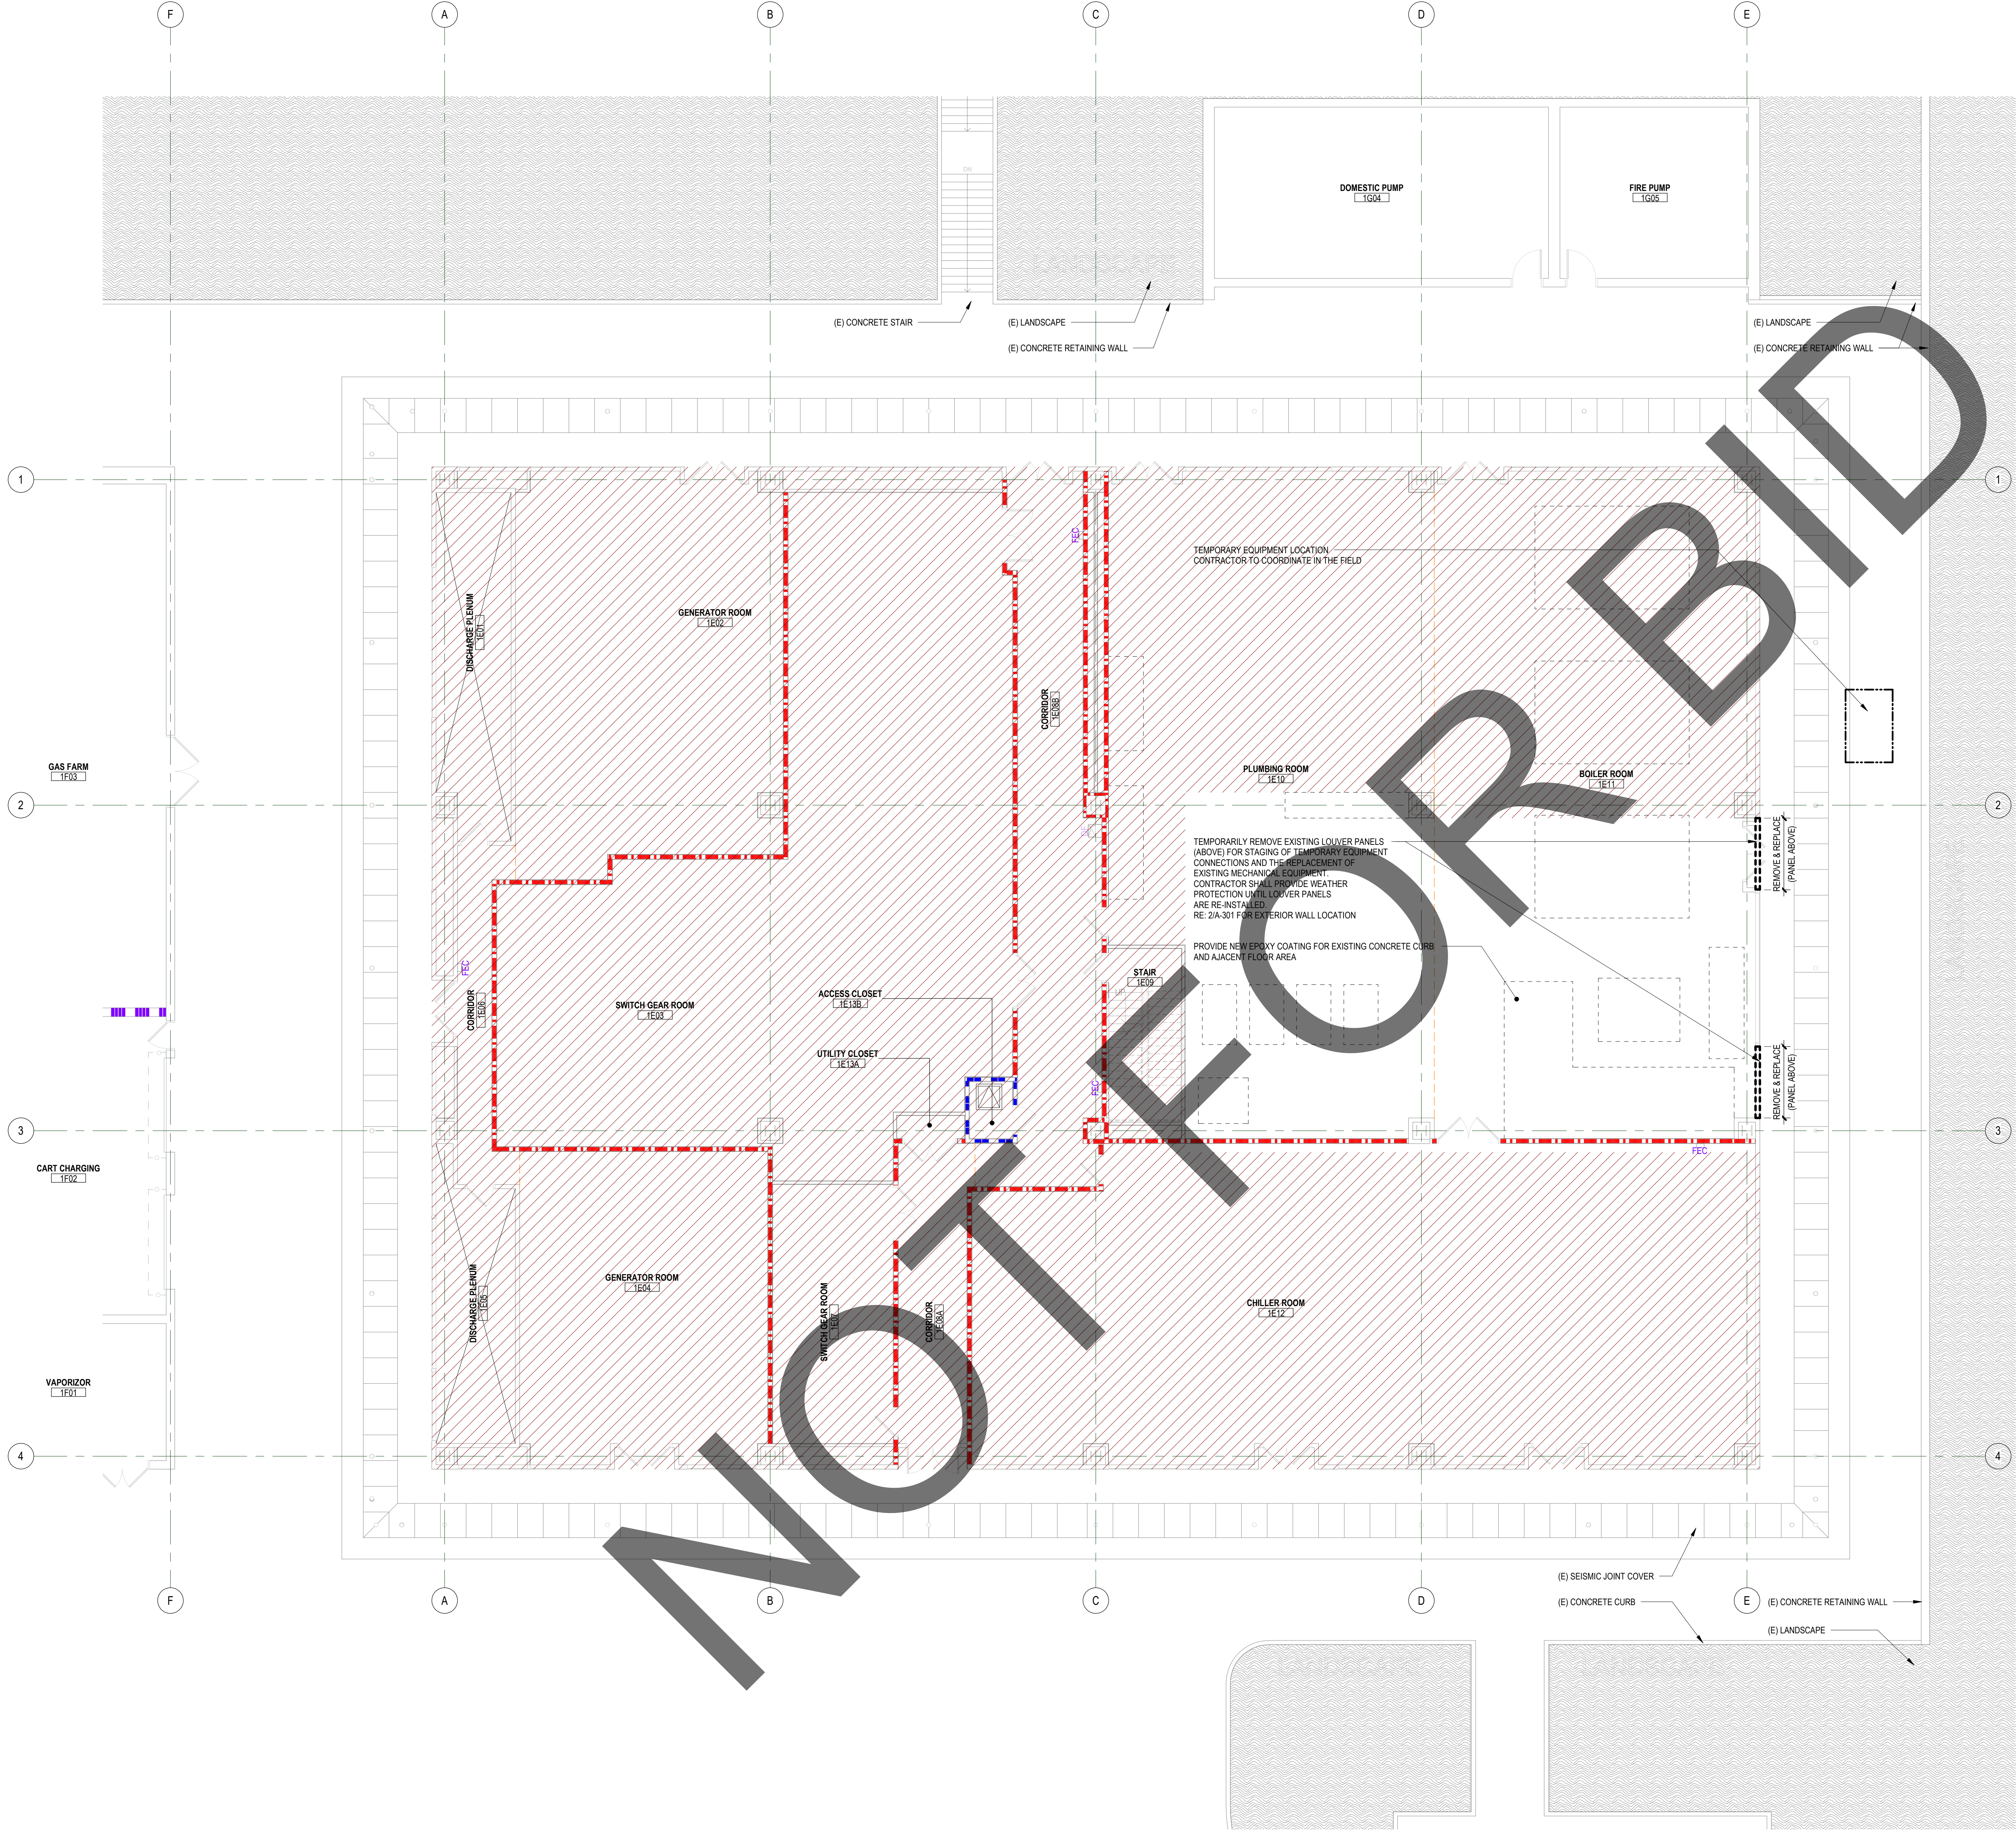


GENERAL NOTES - FLOOR PLAN

1. ARCHITECTURAL SCOPE IS LIMITED TO THE TEMPORARY REMOVAL AND SUBSEQUENT REINSTALLATION OF EXISTING LOUVER PANELS AT THE FIRST FLOOR AS INDICATED.

GRAPHIC LEGEND - FLOOR PLAN

- NOT IN CONTRACT
- ACCESS PANEL / HATCH
- ACCESSIBLE SINK
- ACCESSIBLE TOILET
- FIRE EXTINGUISHER
- DRINKING FOUNTAIN
- DOOR
- EXISTING PARTITION WALL
- NON RATED PARTITION WALL
- 1 HOUR RATED FIRE BARRIER
- 2 HOUR RATED FIRE-SMOKE BARRIER
- 2 HOUR RATED FIRE-SMOKE BARRIER OCCUPANCY SEP
- 4 HOUR RATED FIRE WALL
- CURTAINWALL / STOREFRONT/LOUVER PANEL

KEY PLAN

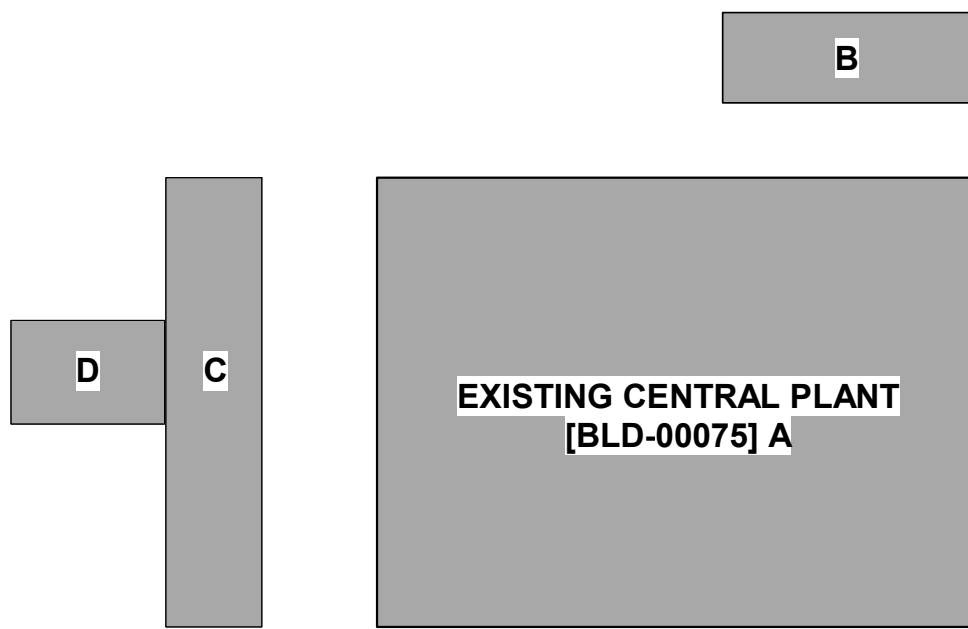

APPROVAL

REVIEWED IN ACCORDANCE WITH THE REQUIREMENTS OF T24, COR

APPROVED

Department of Health Care Access & Information
Office of Statewide Hospital Planning & Development
8/9/2023, 7:23:45 AM
S230562-36-00
Allen Cheng

CLIENT

SAN BERNARDINO COUNTY

SAN BERNARDINO COUNTY
PROJECT AND FACILITIES
MANAGEMENT DEPARTMENT

385 NORTH ARROWHEAD AVENUE, 3RD FLOOR SAN
BERNARDINO, CA 92415-0184

PROJECT NAME

**ARMC
DEAERATOR #1
REPLACEMENT**

PROJECT NO.
WBSE # 10.10.0847
CIP # 20-011
HCAI # S230562-36-00

FACILITY NO.
17282

BUILDING NO.
BLD-00075 CENTRAL PLANT

400 N. PEPPER AVENUE
COLTON, CA 92324-1801

ENGINEER/ARCHITECT

IDS

IDS GROUP

1 PETERS CANYON ROAD, SUITE 130
IRVINE, CA 92606
TEL: 949-387-8500, FAX: 949-387-0800

STAMP

LICENSED ARCHITECT
JOSEPH H. MACDONALD
C-34131
JUNE 2023
STATE OF CALIFORNIA

STAMP

REGISTERED PROFESSIONAL ENGINEER
DARREN B. SMITH
No. 30841
Exp. 12/31/25
IRVINE, CA
STATE OF CALIFORNIA

REV.	DESCRIPTION	DATE
	HCAI SUBMITTAL	03/01/23
A	HCAI BC 1	06/13/23
B	HCAI BC 2	07/28/23

PROJECT IDENTIFICATION

THE ORIGINAL SIZE OF THIS SHEET IS 30" X 42"

THESE DRAWINGS AND SPECIFICATIONS ARE THE PROPERTY AND COPYRIGHT OF IDS GROUP AND SHALL NOT BE USED ON ANY OTHER PROJECT OR LOCATIONS EXCEPT AS DESCRIBED ON THE DRAWINGS, WITHOUT THE WRITTEN AGREEMENT WITH IDS GROUP.

IDS PROJECT NO.	22X66.02
DRAWN BY	CKC
CHECKED BY	CKC
APPROVED BY	JHM

SHEET TITLE


**OVERALL FLOOR
PLAN FIRST FLOOR**

SHEET NUMBER	A-201
SHEET NO.	OF

C:\Users\dfrs.corbett\Documents\22X66.02_ARCH_120.dwg, c:\hmr\XSLT.rvt

7/24/2023 9:27:11 AM

IDS GROUP - FILE LOCATION:

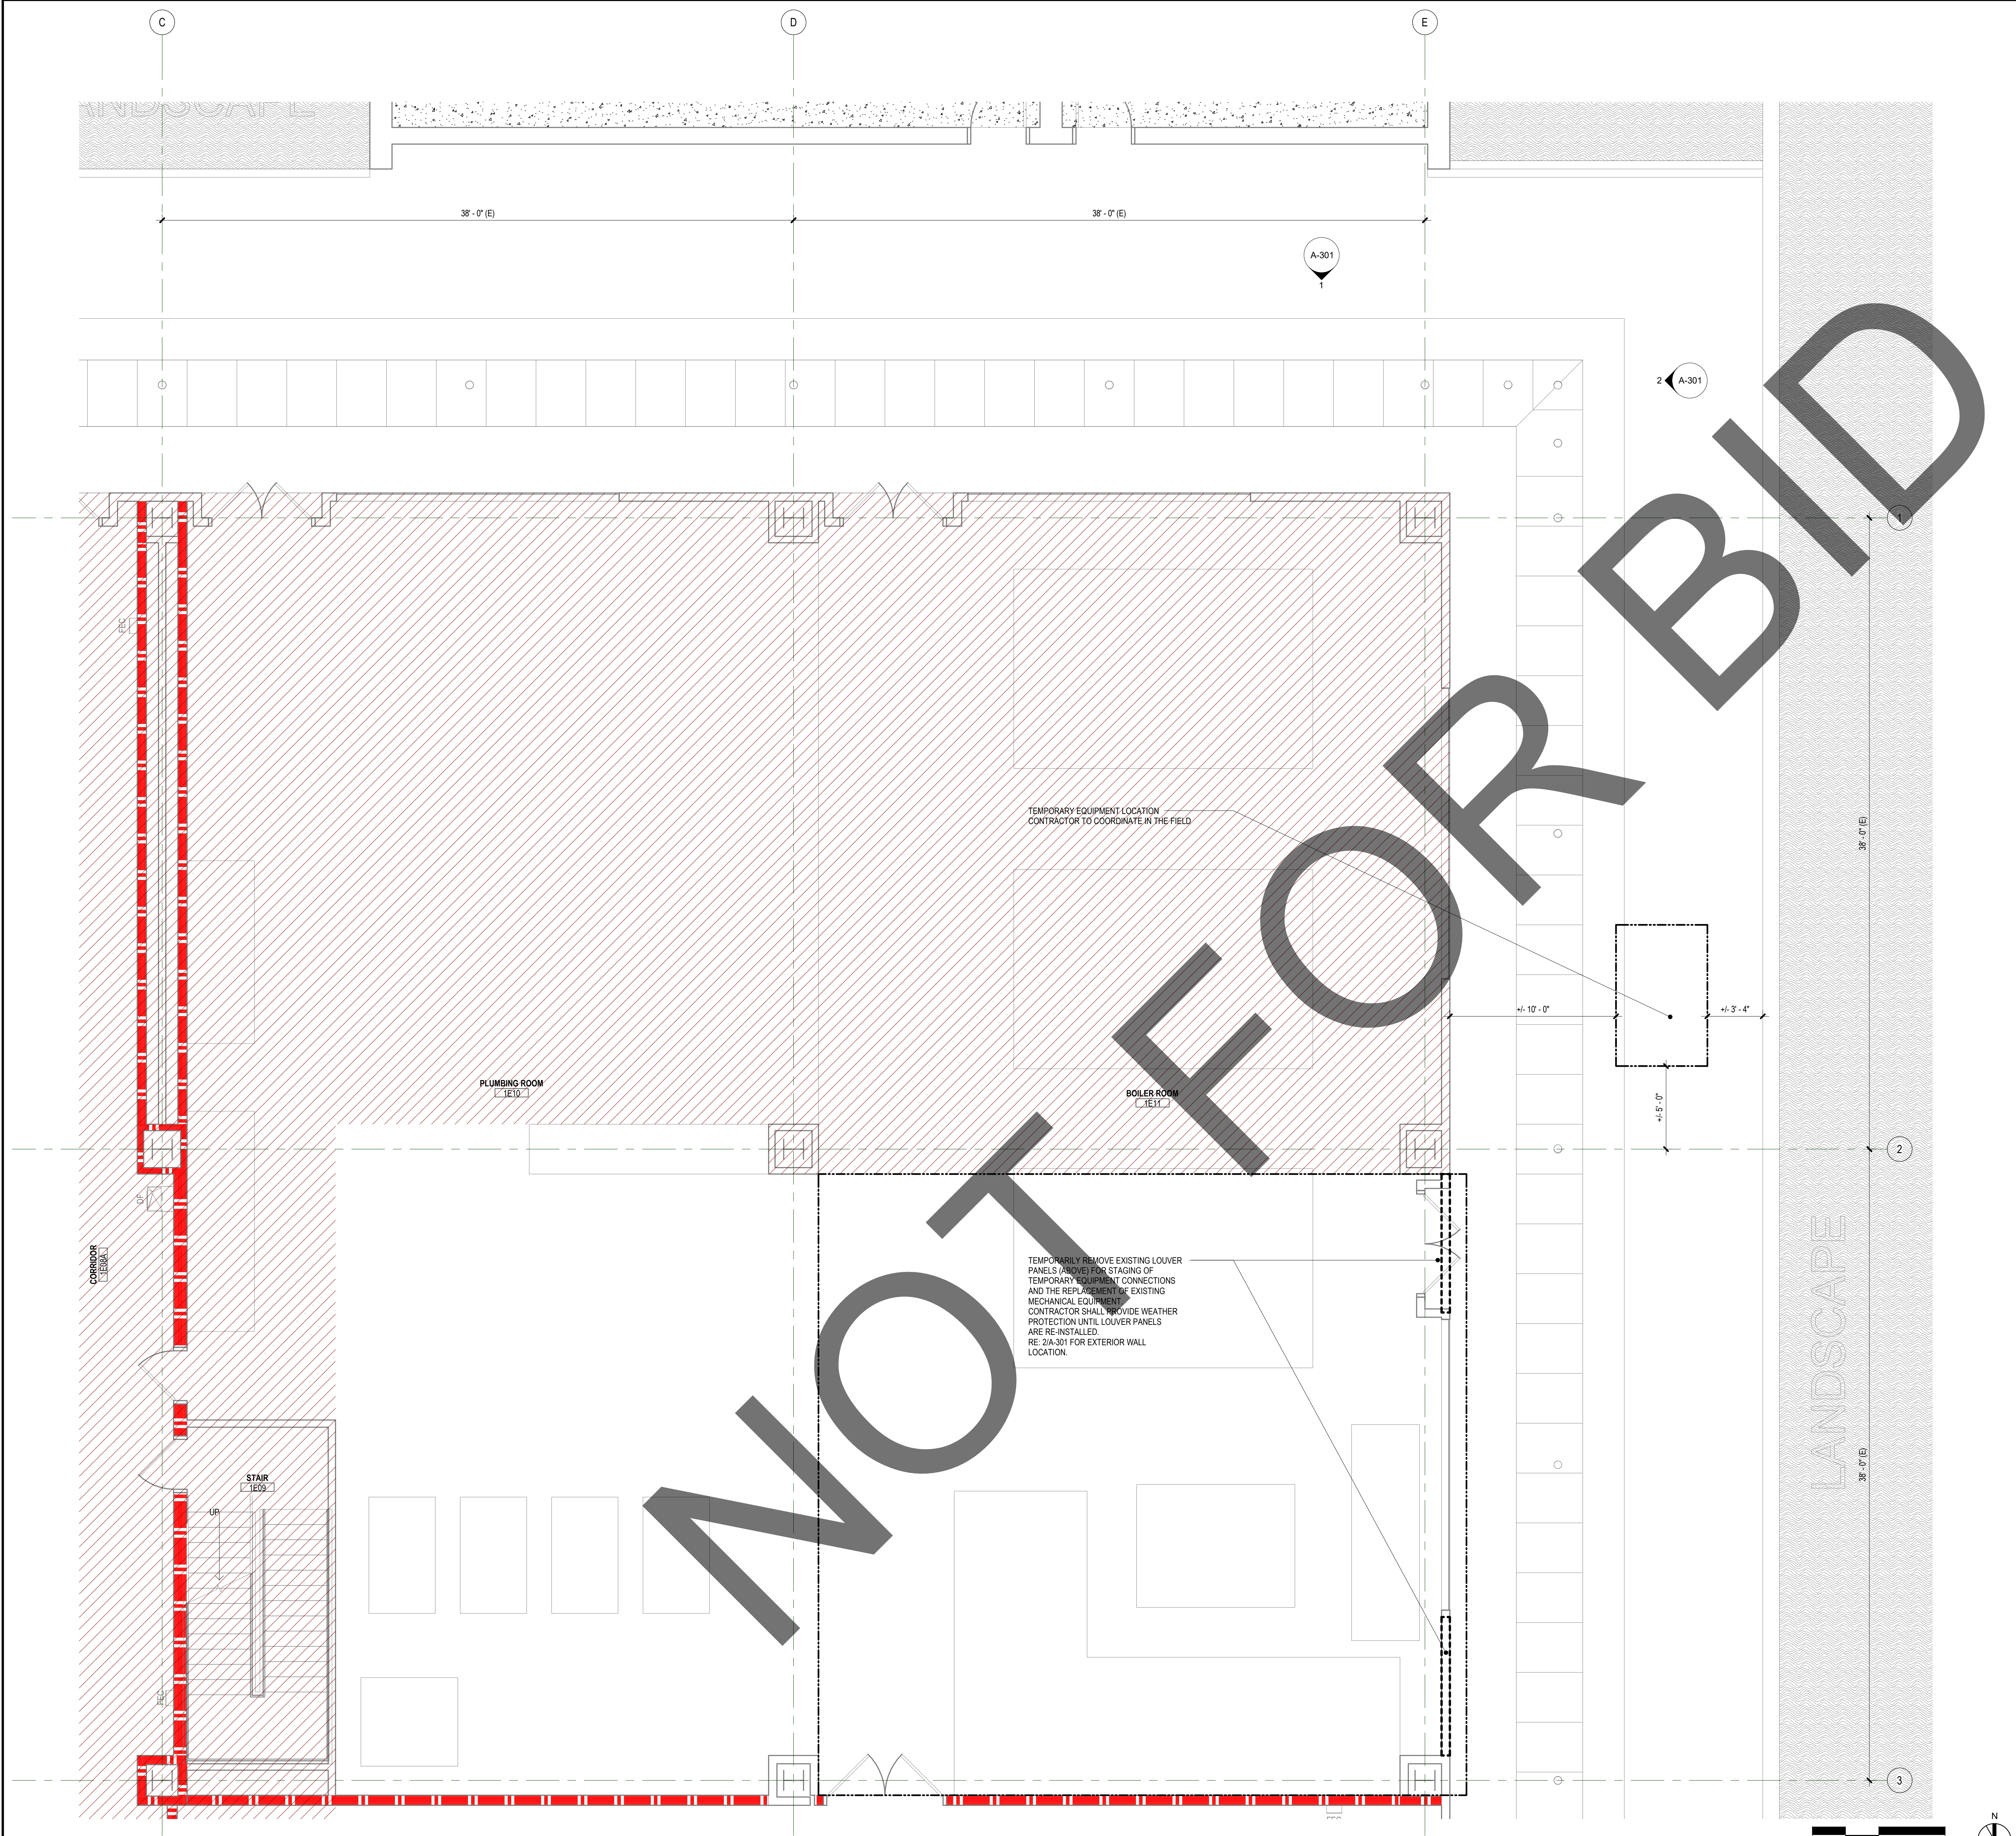

01 FIRST FLOOR PLAN PARTIAL 1/4" = 1'-0" 1


GENERAL NOTES - FLOOR PLAN

1. ARCHITECTURAL SCOPE IS LIMITED TO THE TEMPORARY REMOVAL AND SUBSEQUENT REINSTALLATION OF EXISTING LOUVER PANELS AT THE FIRST FLOOR AS INDICATED.

GRAPHIC LEGEND - FLOOR PLAN

- NOT IN CONTRACT
- ACCESS PANEL / HATCH
- ACCESSIBLE SINK
- ACCESSIBLE TOILET
- FIRE EXTINGUISHER
- DRINKING FOUNTAIN
- DOOR
- EXISTING PARTITION WALL
- NON RATED PARTITION WALL
- 1 HOUR RATED FIRE BARRIER
- 2 HOUR RATED FIRE-SMOKE BARRIER
- 2 HOUR RATED FIRE-SMOKE BARRIER OCCUPANCY SEP
- 4 HOUR RATED FIRE WALL
- CURTAINWALL / STOREFRONT/LOUVER PANEL

KEY PLAN

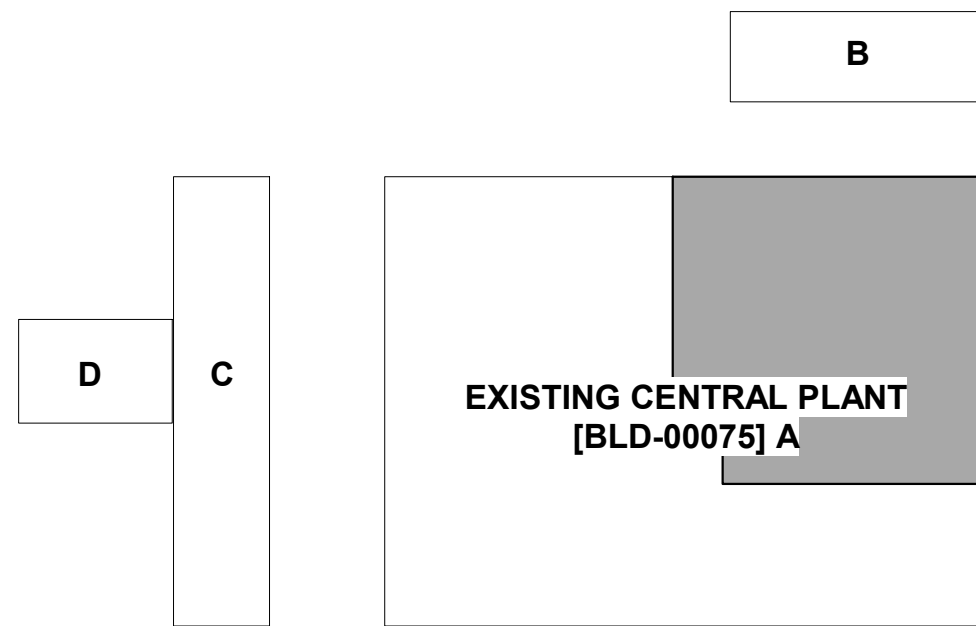

APPROVAL

REVIEWED IN ACCORDANCE WITH THE REQUIREMENTS OF T24, COR

APPROVED

Department of Health Care Access & Information
Office of Statewide Hospital Planning & Development
8/3/2023, 7:23:45 AM
S230562-36-00
Allen Cheng

CLIENT

SAN BERNARDINO COUNTY

SAN BERNARDINO COUNTY
PROJECT AND FACILITIES
MANAGEMENT DEPARTMENT

385 NORTH ARROWHEAD AVENUE, 3RD FLOOR SAN
BERNARDINO, CA 92415-0184

PROJECT NAME

**ARMC
DEAERATOR #1
REPLACEMENT**

PROJECT NO.
WBSE # 10.10.0847
CIP # 20-011
HCAI # S230562-36-00

FACILITY NO.
17282

BUILDING NO.
BLD-00075 CENTRAL PLANT

400 N. PEPPER AVENUE
COLTON, CA 92324-1801

ENGINEER/ARCHITECT

IDS

IDS GROUP

1 PETERS CANYON ROAD, SUITE 130
IRVINE, CA. 92606
TEL: 949-387-8500, FAX: 949-387-0800

STAMP

LICENSED ARCHITECT
JOSEPH H. MACDONALD
C-34131
JUNE 2023
STATE OF CALIFORNIA

STAMP

REGISTERED PROFESSIONAL ENGINEER
DARREN B. SMITH
No. 30841
Exp. 12/31/25
IRVINE, CA
STATE OF CALIFORNIA

REV.	DESCRIPTION	DATE
	HCAI SUBMITTAL	03/01/23
A	HCAI BC 1	06/13/23
B	HCAI BC 2	07/28/23

PROJECT IDENTIFICATION

THE ORIGINAL SIZE OF THIS SHEET IS 30" X 42"

THESE DRAWINGS AND SPECIFICATIONS ARE THE PROPERTY AND COPYRIGHT OF IDS GROUP AND SHALL NOT BE USED ON ANY OTHER PROJECT OR LOCATIONS EXCEPT AS DESCRIBED ON THE DRAWINGS, WITHOUT THE WRITTEN AGREEMENT WITH IDS GROUP.

IDS PROJECT NO.	22X66.02
DRAWN BY	CKC
CHECKED BY	CKC
APPROVED BY	JHM


SHEET TITLE

**FLOOR PLAN
FIRST FLOOR -
PARTIAL**

SHEET NUMBER

A-201A

SHEET NO. OF

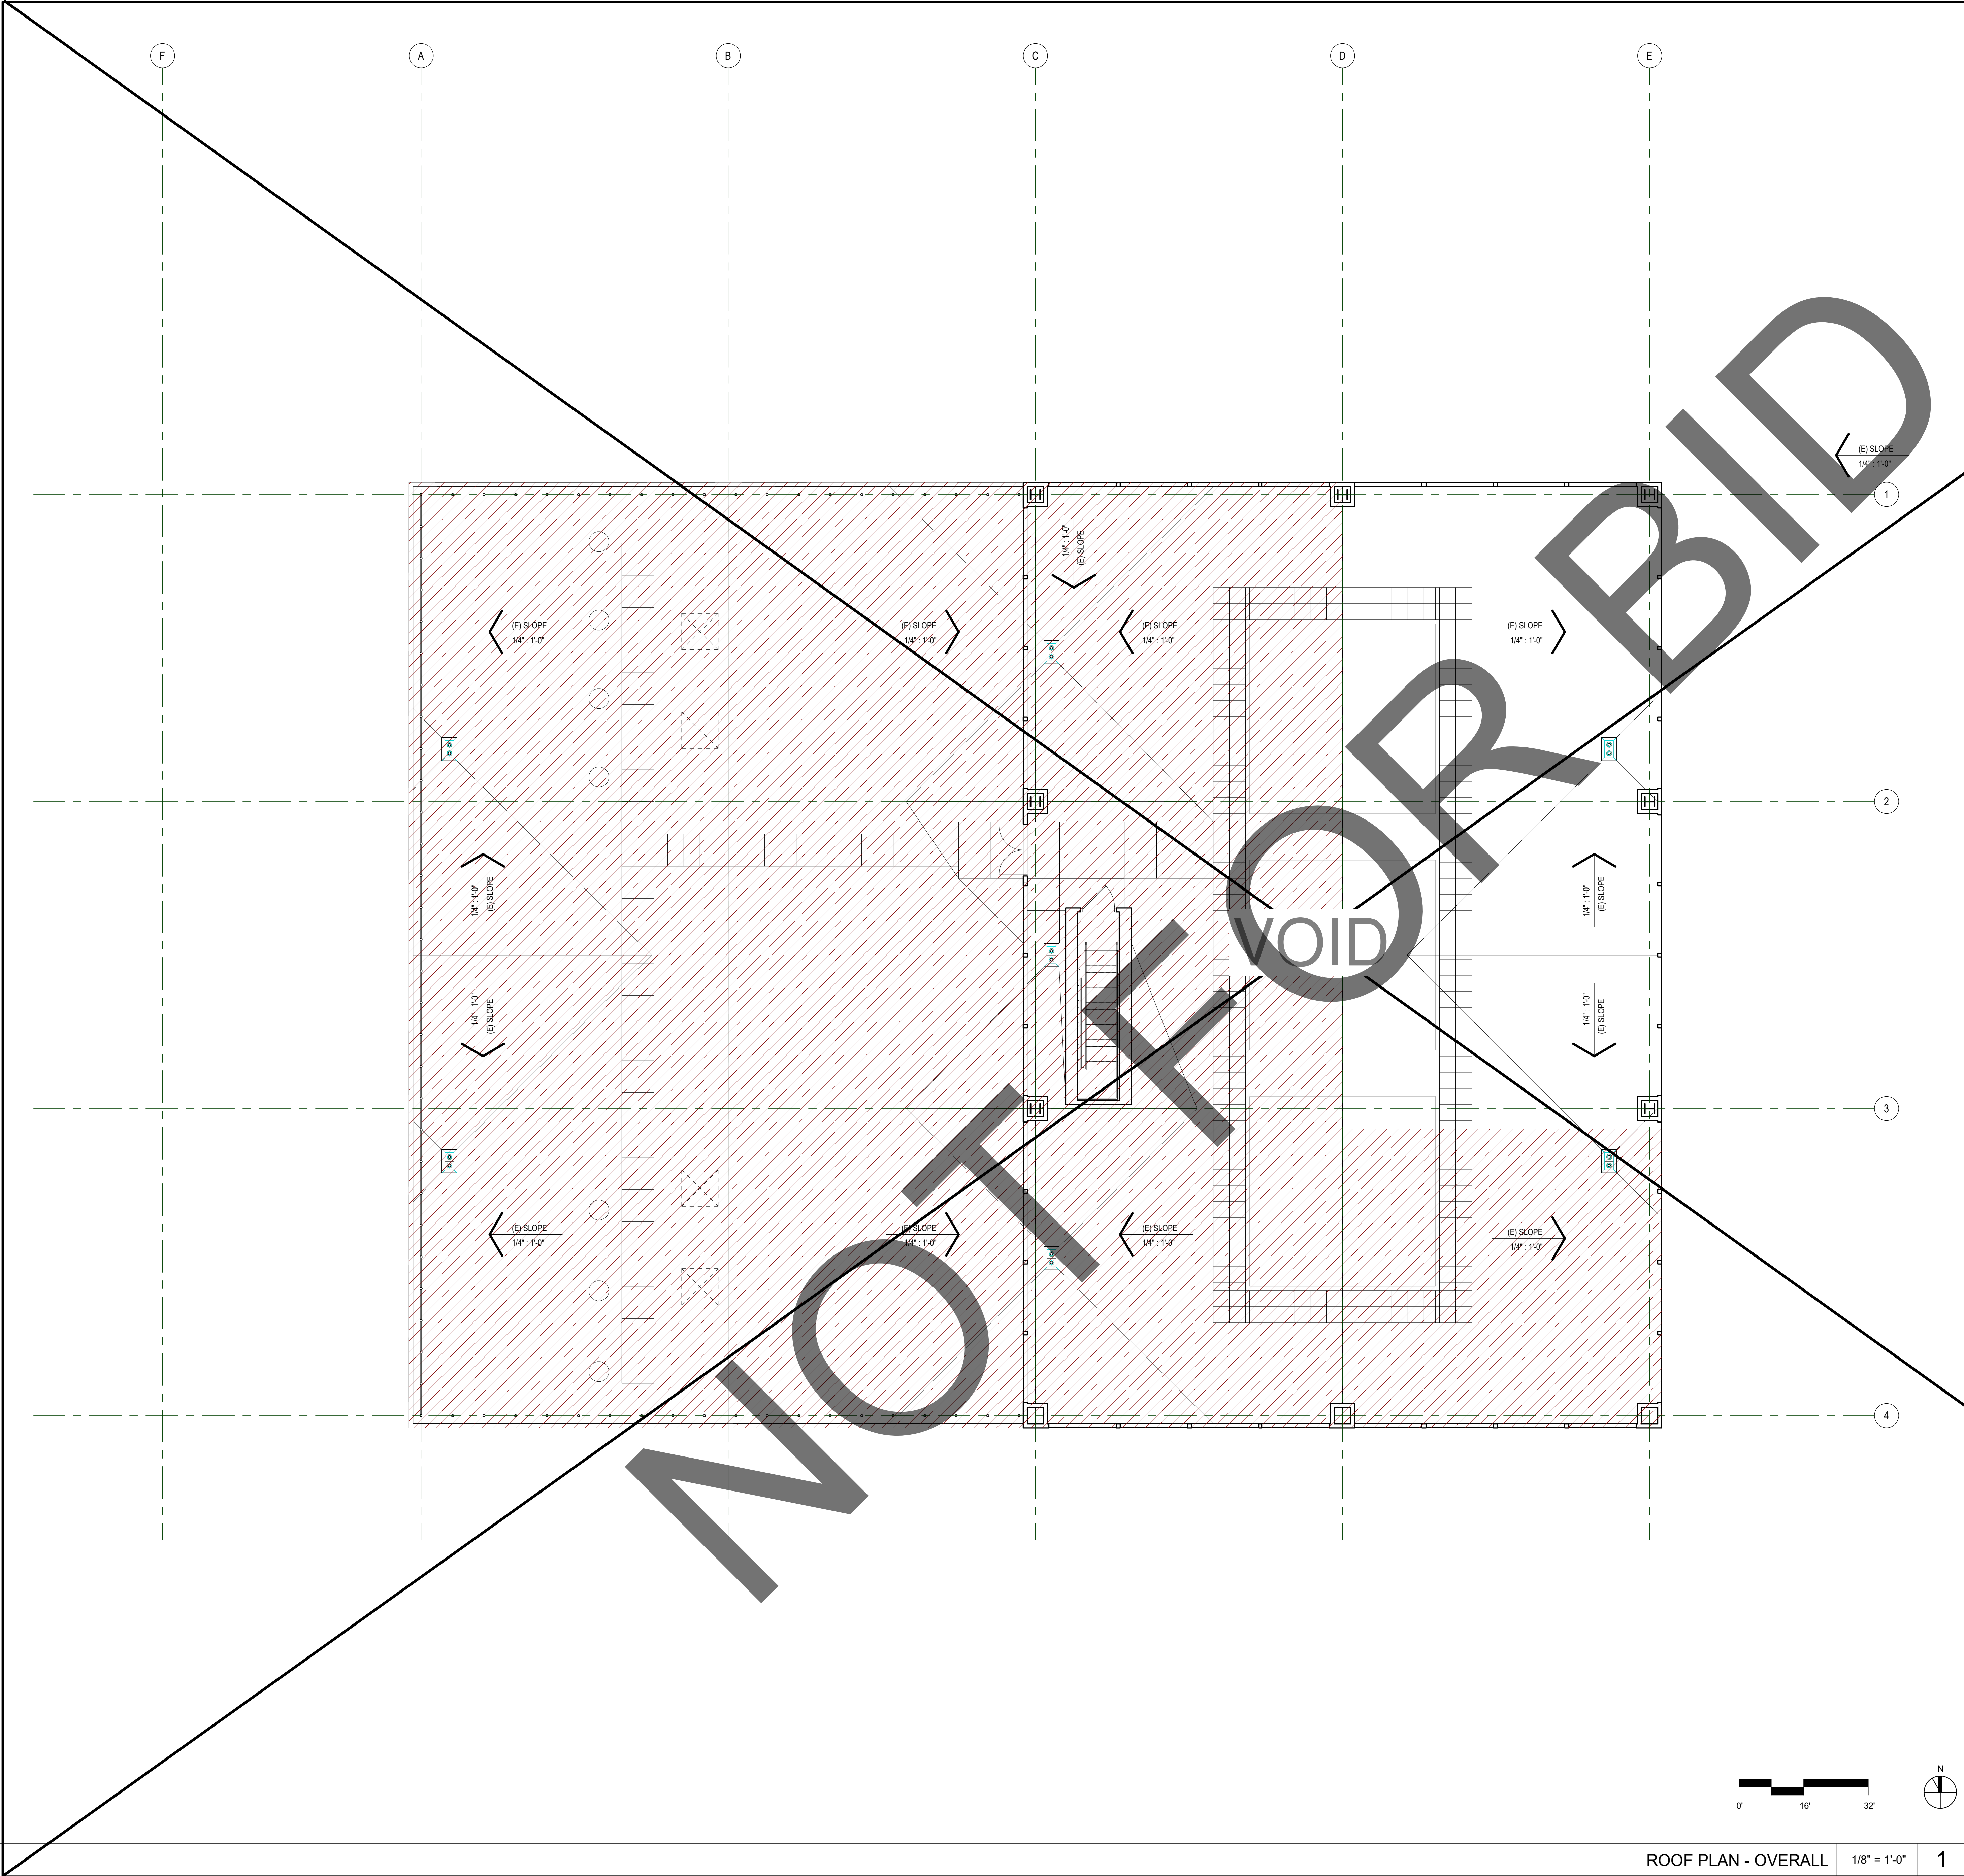

ROOF PLAN - OVERALL 1/8" = 1'-0" 1


GENERAL NOTES - ROOF PLAN

1. ROOF PLAN IS SHOWN FOR REFERENCE ONLY. NO ARCHITECTURAL SCOPE OF WORK.
2. FOR ANY NEW MECHANICAL/PLUMBING PENETRATIONS, THE CONTRACTOR SHALL PROVIDE PATCH & REPAIR AS REQUIRED.

GRAPHIC LEGEND - ROOF PLAN

- SLOPE
1/4" : 1'-0"
- SLOPE OF STRUCTURE
(AS INDICATED)
- SLOPE OF CRICKET (1/4" PER FOOT MIN.)
- RD
ROOF DRAIN
- RD
ROOF DRAIN & OVERFLOW DRAIN
- TAPERED INSULATION
- MEMBRANE ROOFING
- NOT IN CONTRACT

KEY PLAN

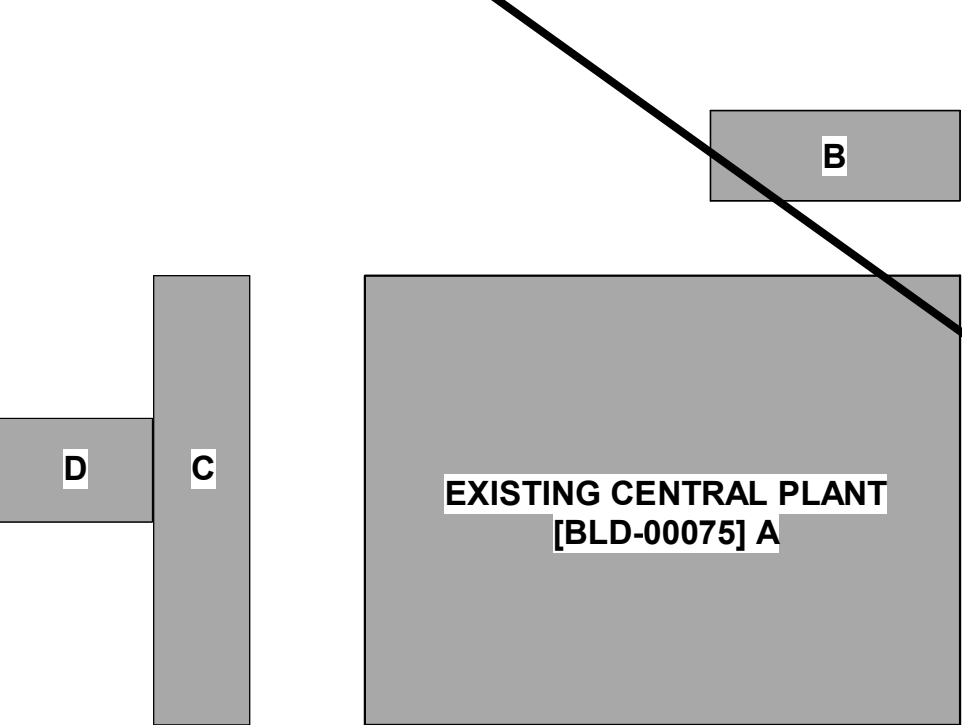

APPROVAL

CLIENT



SAN BERNARDINO COUNTY
PROJECT AND FACILITIES
MANAGEMENT DEPARTMENT

385 NORTH ARROWHEAD AVENUE, 3RD FLOOR SAN
BERNARDINO, CA 92415-0184

PROJECT NAME

REPLACEMENT DEEAERATOR


PROJECT ADDRESS
400 N PEPPER AVE, COLTON, CA 92324

PROJECT NO.
WBSE # 10.10.0847
CIP # 20-011
HCAI # S220562-36-00

FACILITY NO.

17282
BUILDING NO.
BLD-00075 CENTRAL PLANT

ENGINEER/ARCHITECT

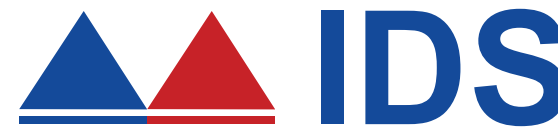

IDS GROUP

1 PETERS CANYON ROAD, SUITE 130
IRVINE, CA. 92606
TEL: 949-387-8500, FAX: 949-387-0800

STAMP



STAMP



ISSUE

REV.	DESCRIPTION	DATE
	HCAI SUBMITTAL	04/28/23

PROJECT IDENTIFICATION

THE ORIGINAL SIZE OF THIS SHEET IS 30" X 42"
THESE DRAWINGS AND SPECIFICATIONS ARE THE PROPERTY AND
COPYRIGHT OF IDS GROUP AND SHALL NOT BE USED ON ANY
OTHER PROJECT OR LOCATIONS EXCEPT AS DESCRIBED ON THE
DRAWINGS, WITHOUT THE WRITTEN AGREEMENT WITH IDS GROUP.

IDS PROJECT NO.	22X066.02
DRAWN BY	CKC
CHECKED BY	CKC
APPROVED BY	JHM


SHEET TITLE

OVERALL ROOF
PLAN

SHEET NUMBER

A-203

SHEET NO. XXX OF XXX

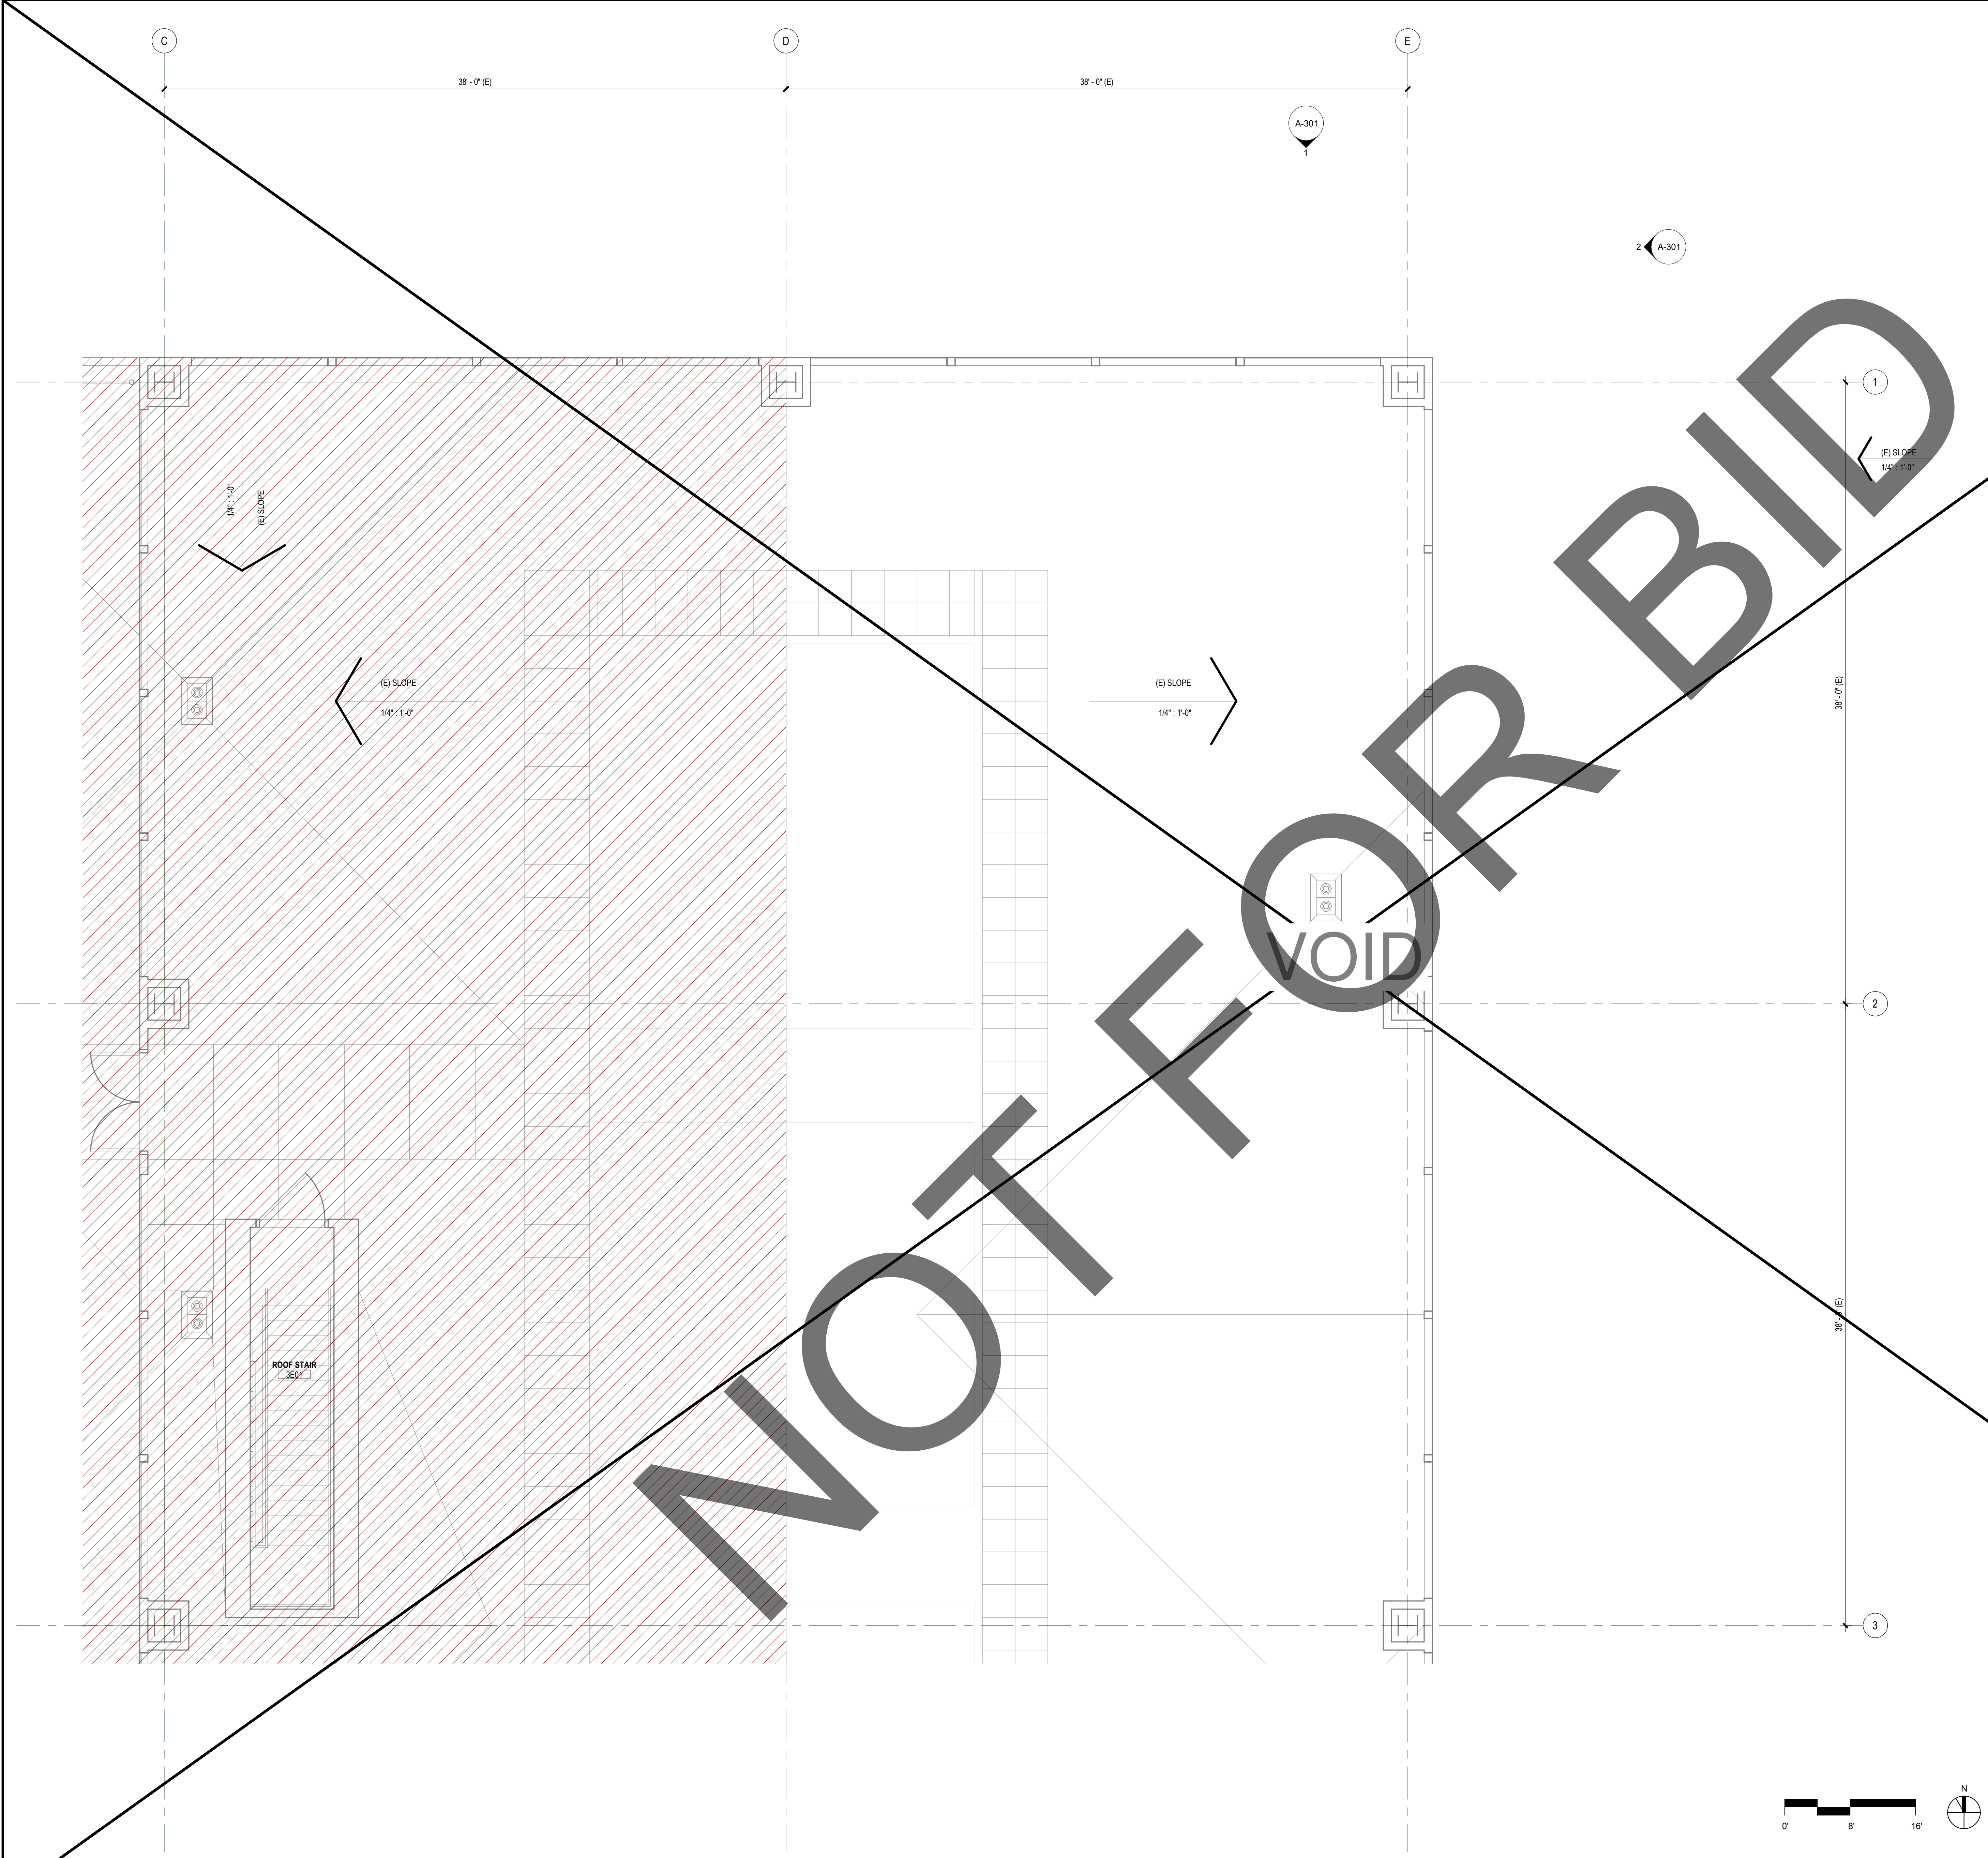


GENERAL NOTES - ROOF PLAN

1. ROOF PLAN IS SHOWN FOR REFERENCE ONLY. NO ARCHITECTURAL SCOPE OF WORK.
2. FOR ANY NEW MECHANICAL/PLUMBING PENETRATIONS, THE CONTRACTOR SHALL PROVIDE PATCH & REPAIR AS REQUIRED.

GRAPHIC LEGEND - ROOF PLAN

- SLOPE 1/4" : 1'-0" SLOPE OF STRUCTURE (AS INDICATED)
- SLOPE OF CRICKET (1/4" PER FOOT MIN.)
- RD ROOF DRAIN
- ROOF DRAIN & OVERFLOW DRAIN
- TAPERED INSULATION
- MEMBRANE ROOFING
- NOT IN CONTRACT

KEY PLAN

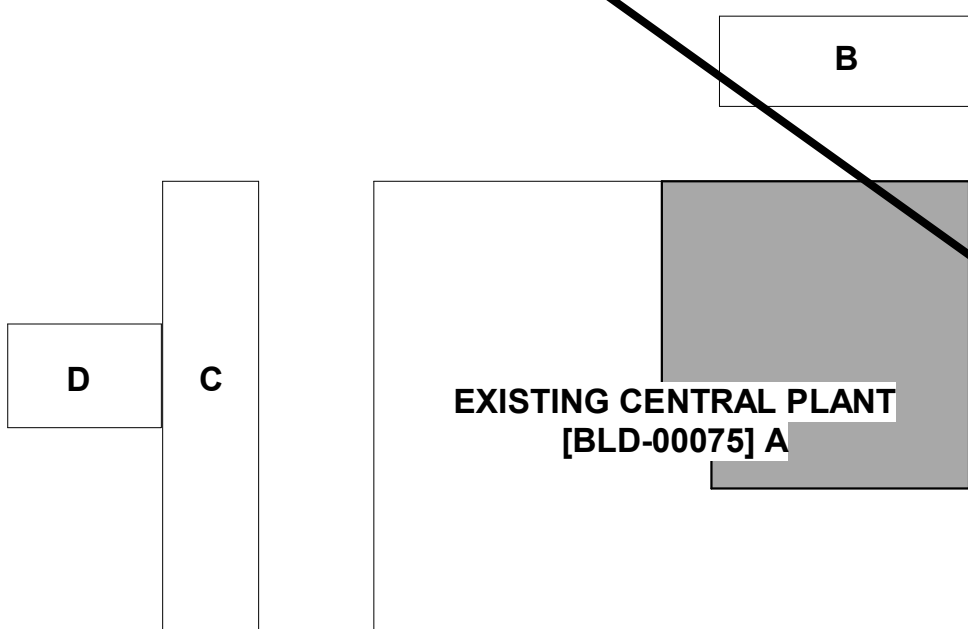

ROOF - PLAN PARTIAL 1/4" = 1'-0" 1

APPROVAL

CLIENT



SAN BERNARDINO COUNTY
PROJECT AND FACILITIES
MANAGEMENT DEPARTMENT

385 NORTH ARROWHEAD AVENUE, 3RD FLOOR SAN
BERNARDINO, CA 92415-0184

PROJECT NAME

REPLACEMENT DEEAERATOR


PROJECT ADDRESS
400 N PEPPER AVE, COLTON, CA 92324

PROJECT NO.
WBSE # 10.10.0847
CIP # 20-011
HCAI # S220562-36-00

FACILITY NO.
17262

BUILDING NO.
BLD-00075 CENTRAL PLANT

ENGINEER/ARCHITECT

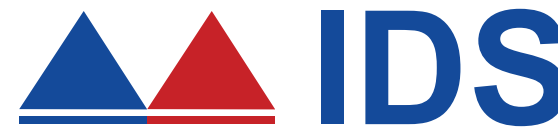

IDS GROUP

1 PETERS CANYON ROAD, SUITE 130
IRVINE, CA 92606
TEL: 949-387-8500, FAX: 949-387-0800

STAMP



STAMP



ISSUE

REV.	DESCRIPTION	DATE
	HCAI SUBMITTAL	04/28/23

PROJECT IDENTIFICATION

THE ORIGINAL SIZE OF THIS SHEET IS 30" X 42"
THESE DRAWINGS AND SPECIFICATIONS ARE THE PROPERTY AND
COPYRIGHT OF IDS GROUP AND SHALL NOT BE USED ON ANY
OTHER PROJECT OR LOCATIONS EXCEPT AS DESCRIBED ON THE
DRAWINGS, WITHOUT THE WRITTEN AGREEMENT WITH IDS GROUP.

IDS PROJECT NO.	22X66.02
DRAWN BY	CKC
CHECKED BY	CKC
APPROVED BY	JHM

SHEET TITLE

ROOF PLAN -
PARTIAL

SHEET NUMBER


A-203A

SHEET NO. XXX OF XXX

GENERAL NOTES - EXT. ELEVATIONS

1. ARCHITECTURAL SCOPE IS LIMITED TO THE TEMPORARY REMOVAL AND SUBSEQUENT REINSTALLATION OF EXISTING LOUVER PANELS AT THE FIRST FLOOR EAST ELEVATION, AS INDICATED.
2. ALL OTHER BUILDING ELEVATIONS ARE SHOWN FOR REFERENCE ONLY.

APPROVAL

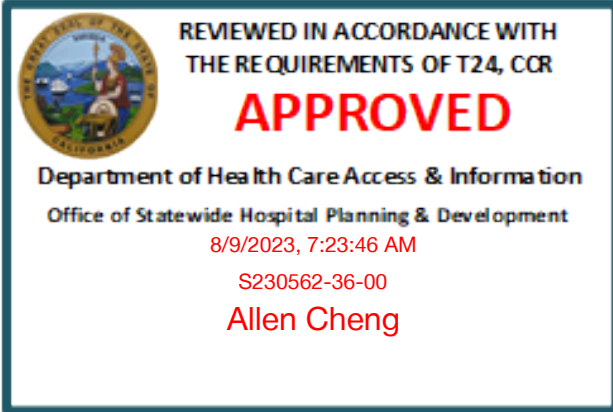

CLIENT



PROJECT NAME

**ARMC
DEAERATOR #1
REPLACEMENT**

PROJECT NO.
WBSE # 10.10.0847
CIP # 20-011
HCAI # 5230562-36-00

FACILITY NO.
17282

BUILDING NO.
BLD-00075 CENTRAL PLANT

400 N. PEPPER AVENUE
COLTON, CA 92324-1801

ENGINEER/ARCHITECT



STAMP



STAMP



ISSUE

REV.	DESCRIPTION	DATE
	HCAI SUBMITTAL	03/01/23
A	HCAI BC 1	06/13/23
B	HCAI BC 2	07/28/23

PROJECT IDENTIFICATION

THE ORIGINAL SIZE OF THIS SHEET IS 30" X 42"

THESE DRAWINGS AND SPECIFICATIONS ARE THE PROPERTY AND COPYRIGHT OF IDS GROUP AND SHALL NOT BE USED ON ANY OTHER PROJECT OR LOCATIONS EXCEPT AS DESCRIBED ON THE DRAWINGS, WITHOUT THE WRITTEN AGREEMENT WITH IDS GROUP.

IDS PROJECT NO.	22X66.02
DRAWN BY	CKC
CHECKED BY	CKC
APPROVED BY	JHM


SHEET TITLE

**EXTERIOR
ELEVATIONS**


SHEET NUMBER

A-301

SHEET NO. OF

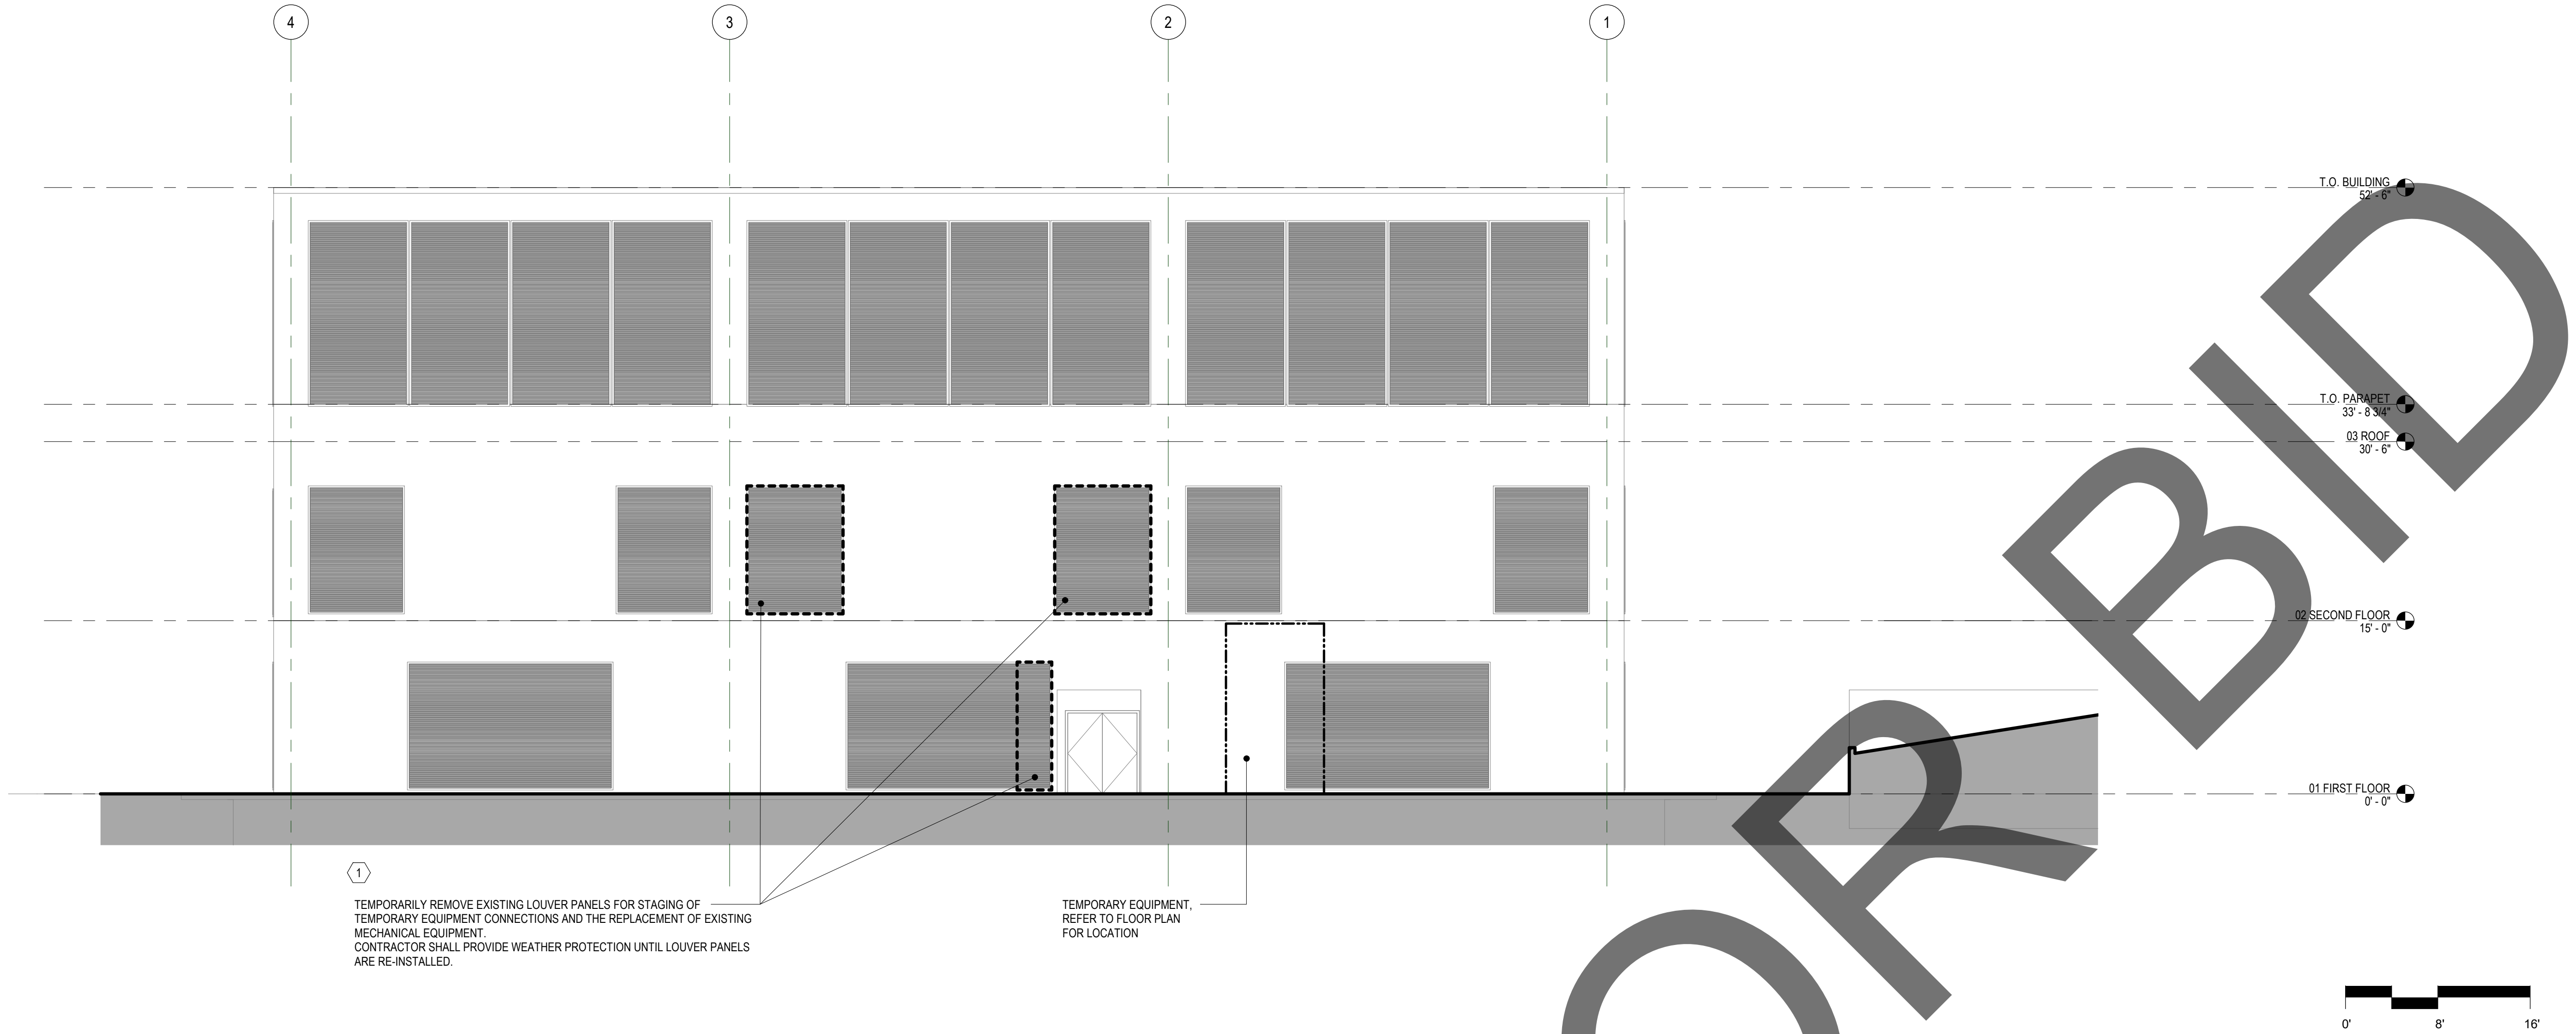


DEMOLITION EAST ELEVATION - OVERALL 1/8" = 1'-0" 2

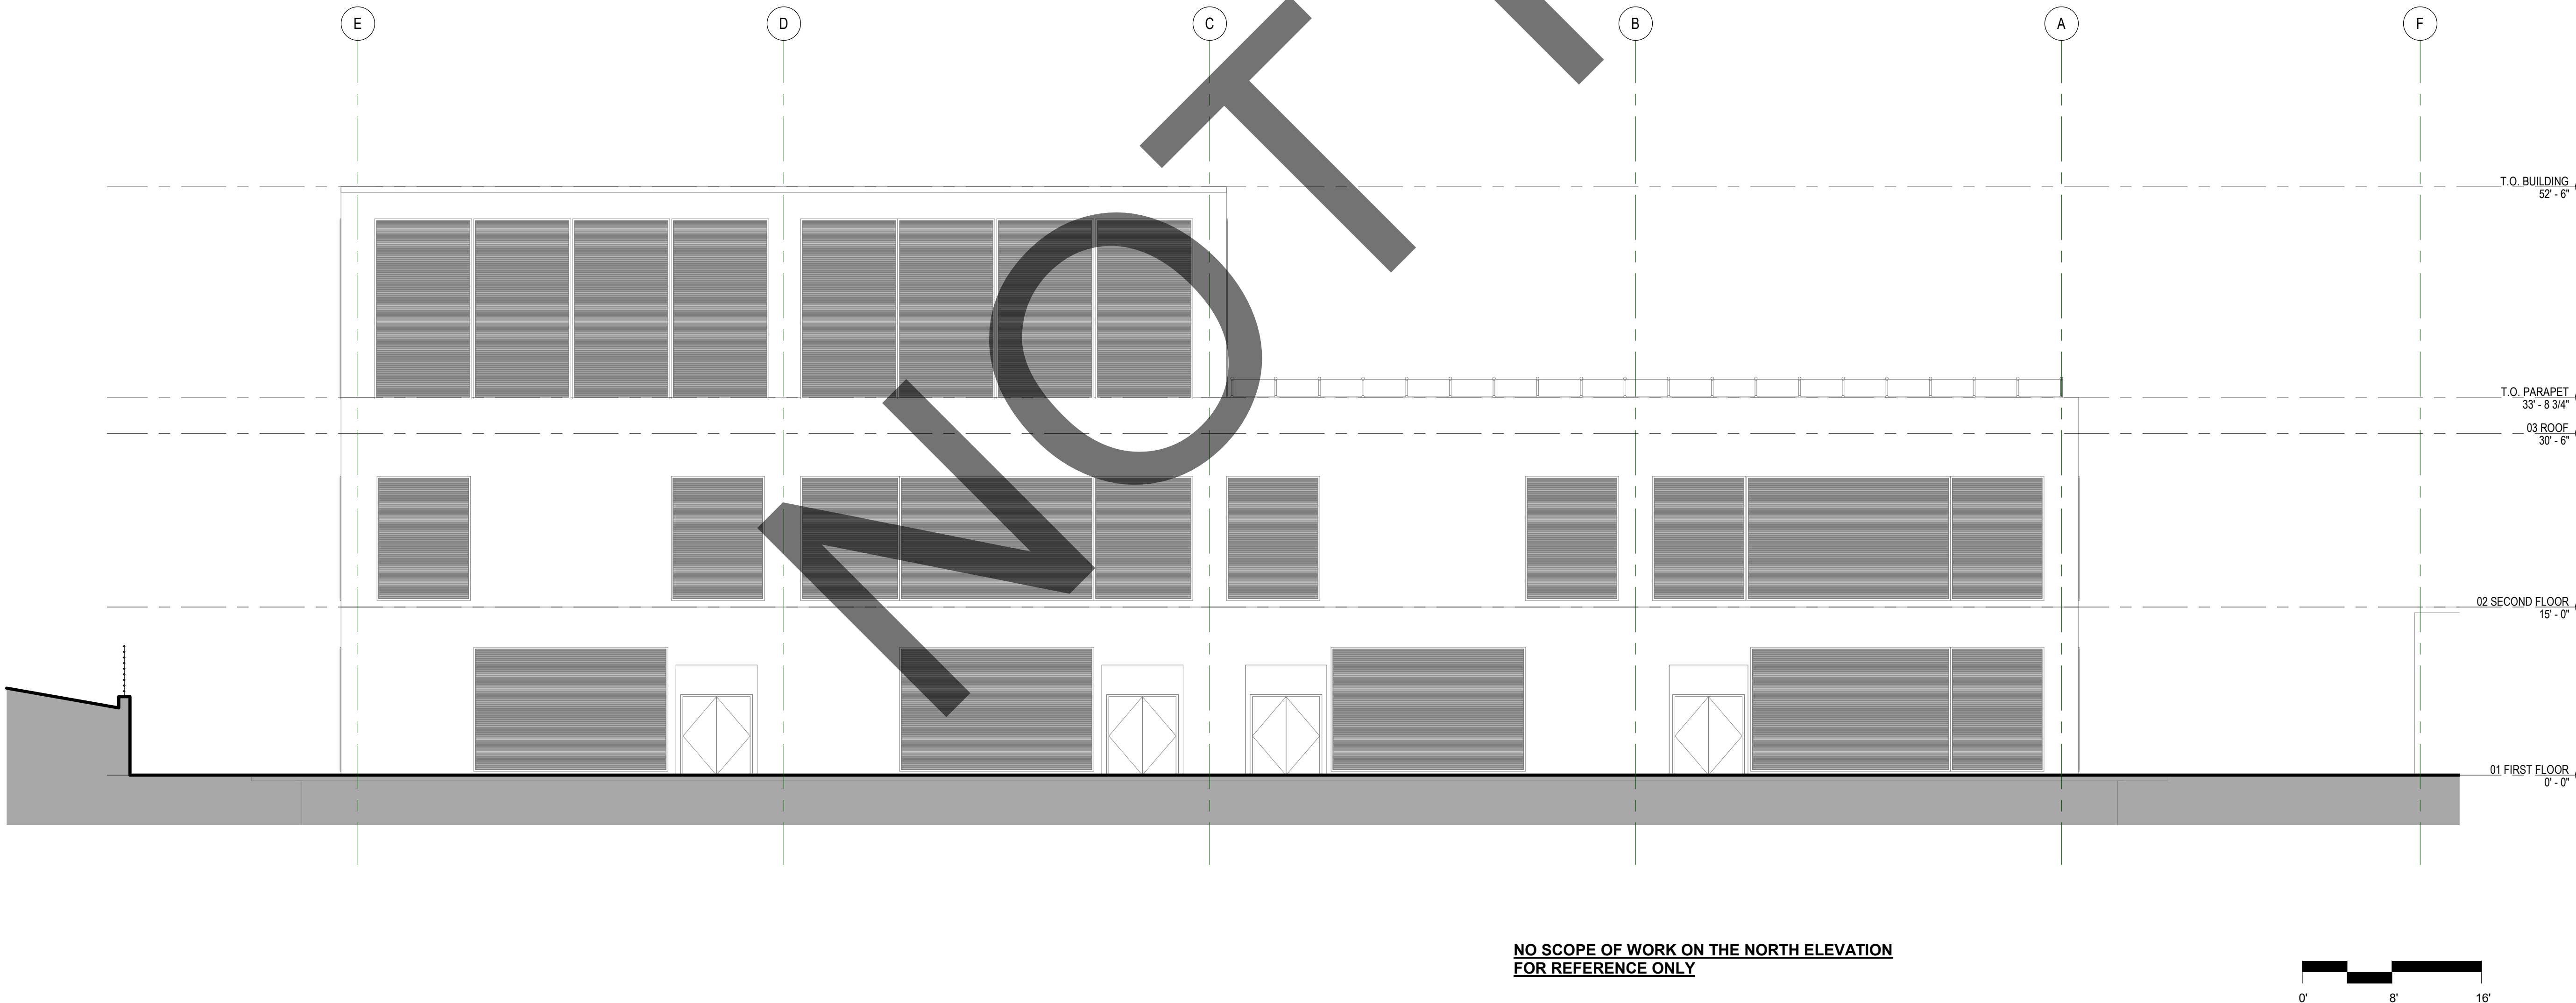


NORTH ELEVATION - OVERALL 1/8" = 1'-0" 1

IDS GROUP - FILE LOCATION: 2/24/2023 11:04:53 AM IDS-FS1\Shared\PROJECTS\2022\Shared\22X066.02 ARMC - Replacement Deaerator 104 BIM\01 Arc\22X066.02_ARCH\LR201.rvt

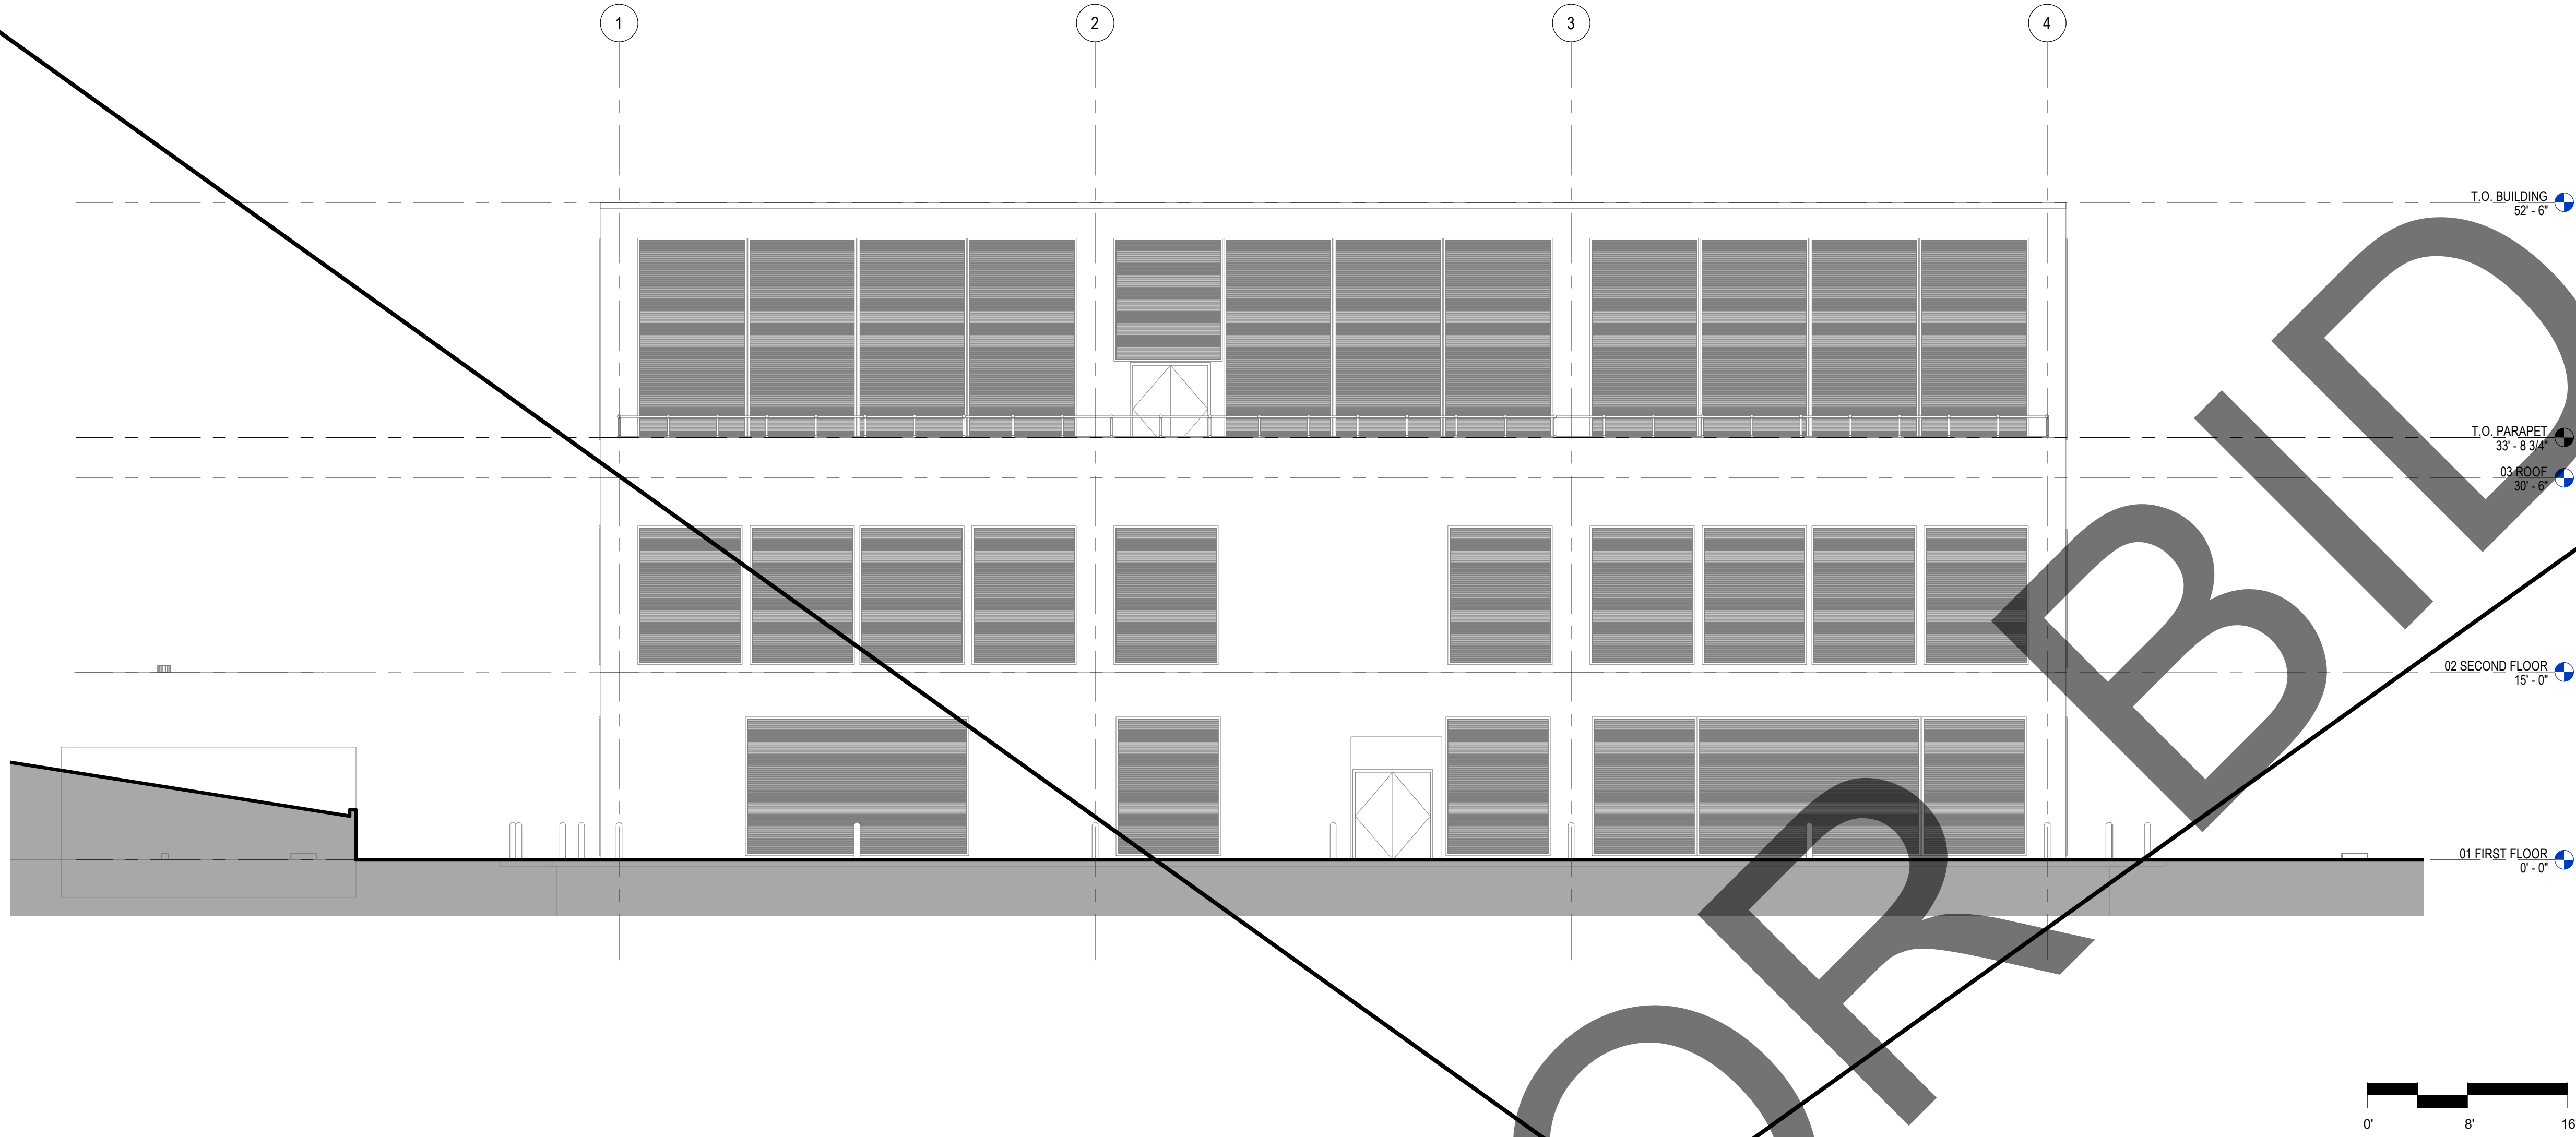

WEST ELEVATION - OVERALL 1/8" = 1'-0" 2

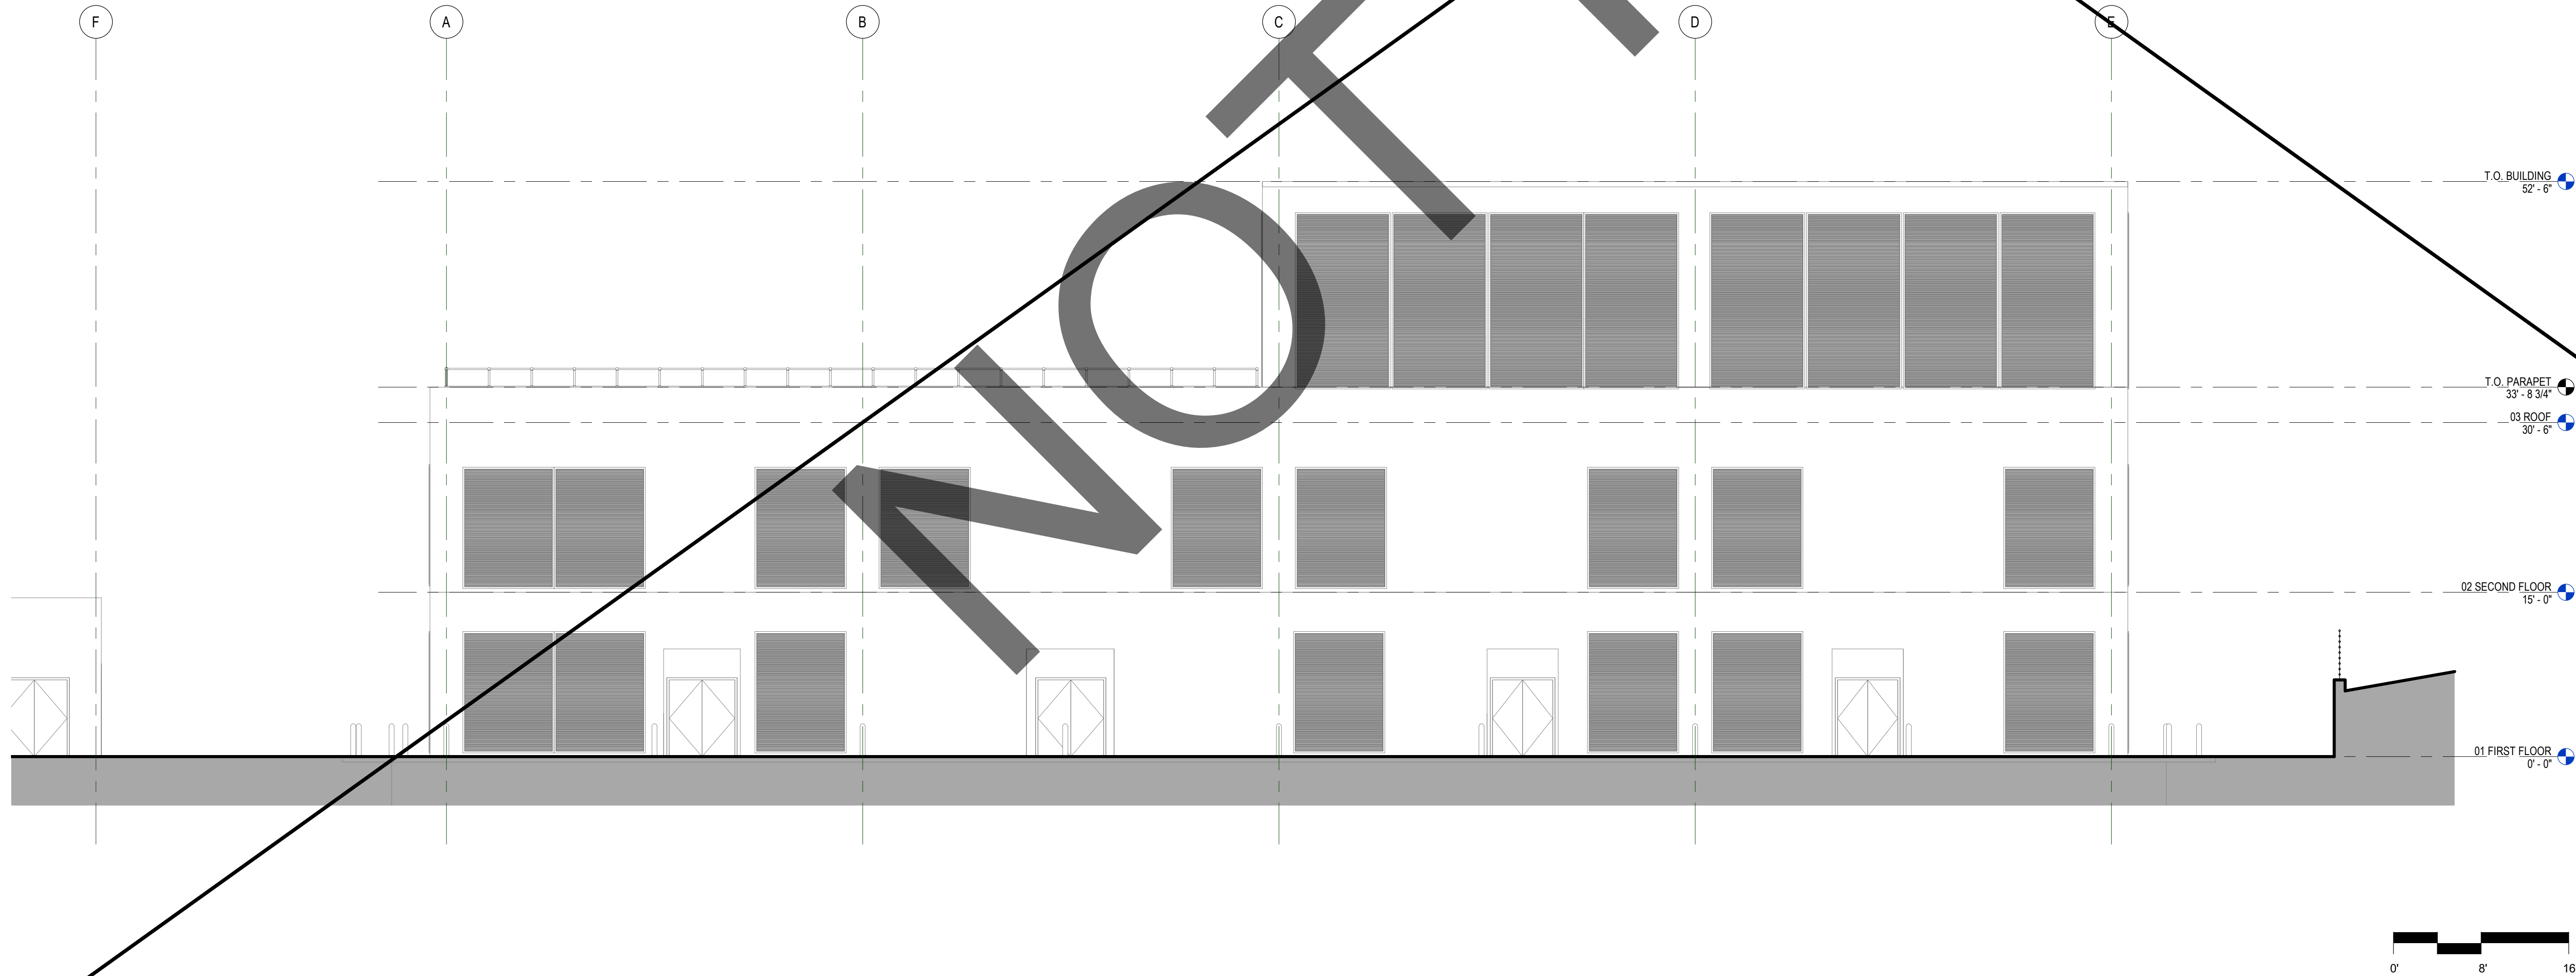

SOUTH ELEVATION - OVERALL 1/8" = 1'-0" 1

GENERAL NOTES - EXT. ELEVATIONS

1. ARCHITECTURAL SCOPE IS LIMITED TO THE TEMPORARY REMOVAL AND SUBSEQUENT REINSTALLATION OF EXISTING LOUVER PANELS AT THE FIRST FLOOR EAST ELEVATION, AS INDICATED.

APPROVAL

CLIENT



SAN BERNARDINO COUNTY
PROJECT AND FACILITIES
MANAGEMENT DEPARTMENT

385 NORTH ARROWHEAD AVENUE, 3RD FLOOR SAN
BERNARDINO, CA 92415-0184

PROJECT NAME


REPLACEMENT DEAEERATOR

PROJECT ADDRESS
400 N PEPPER AVE, COLTON, CA 92324

PROJECT NO.
WBSE # 10.10.0847
CIP # 20-011
HCAI # S220562-36-00

FACILITY NO.
17282
BUILDING NO.
BLD-00075 CENTRAL PLANT

ENGINEER/ARCHITECT

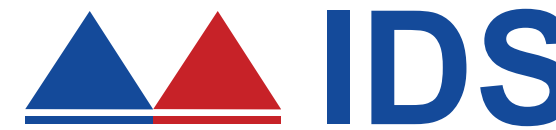


IDS GROUP

1 PETERS CANYON ROAD, SUITE 130
IRVINE, CA 92606
TEL: 949-387-8500, FAX: 949-387-0800

STAMP



STAMP

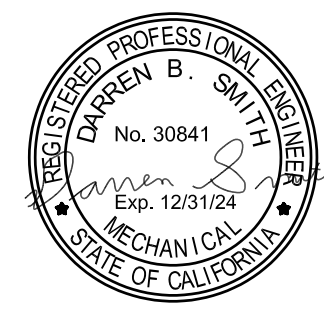

ISSUE

REV.	DESCRIPTION	DATE
	HCAI SUBMITTAL	04/28/23

PROJECT IDENTIFICATION

THE ORIGINAL SIZE OF THIS SHEET IS 30" X 42"
THESE DRAWINGS AND SPECIFICATIONS ARE THE PROPERTY AND
COPYRIGHT OF IDS GROUP AND SHALL NOT BE USED ON ANY
OTHER PROJECT OR LOCATIONS EXCEPT AS DESCRIBED ON THE
DRAWINGS, WITHOUT THE WRITTEN AGREEMENT WITH IDS GROUP.

IDS PROJECT NO.	22X66.02
DRAWN BY	CKC
CHECKED BY	CKC
APPROVED BY	JHM


SHEET TITLE

EXTERIOR
ELEVATIONS

SHEET NUMBER

A-302


SHEET NO. XXX OF XXX

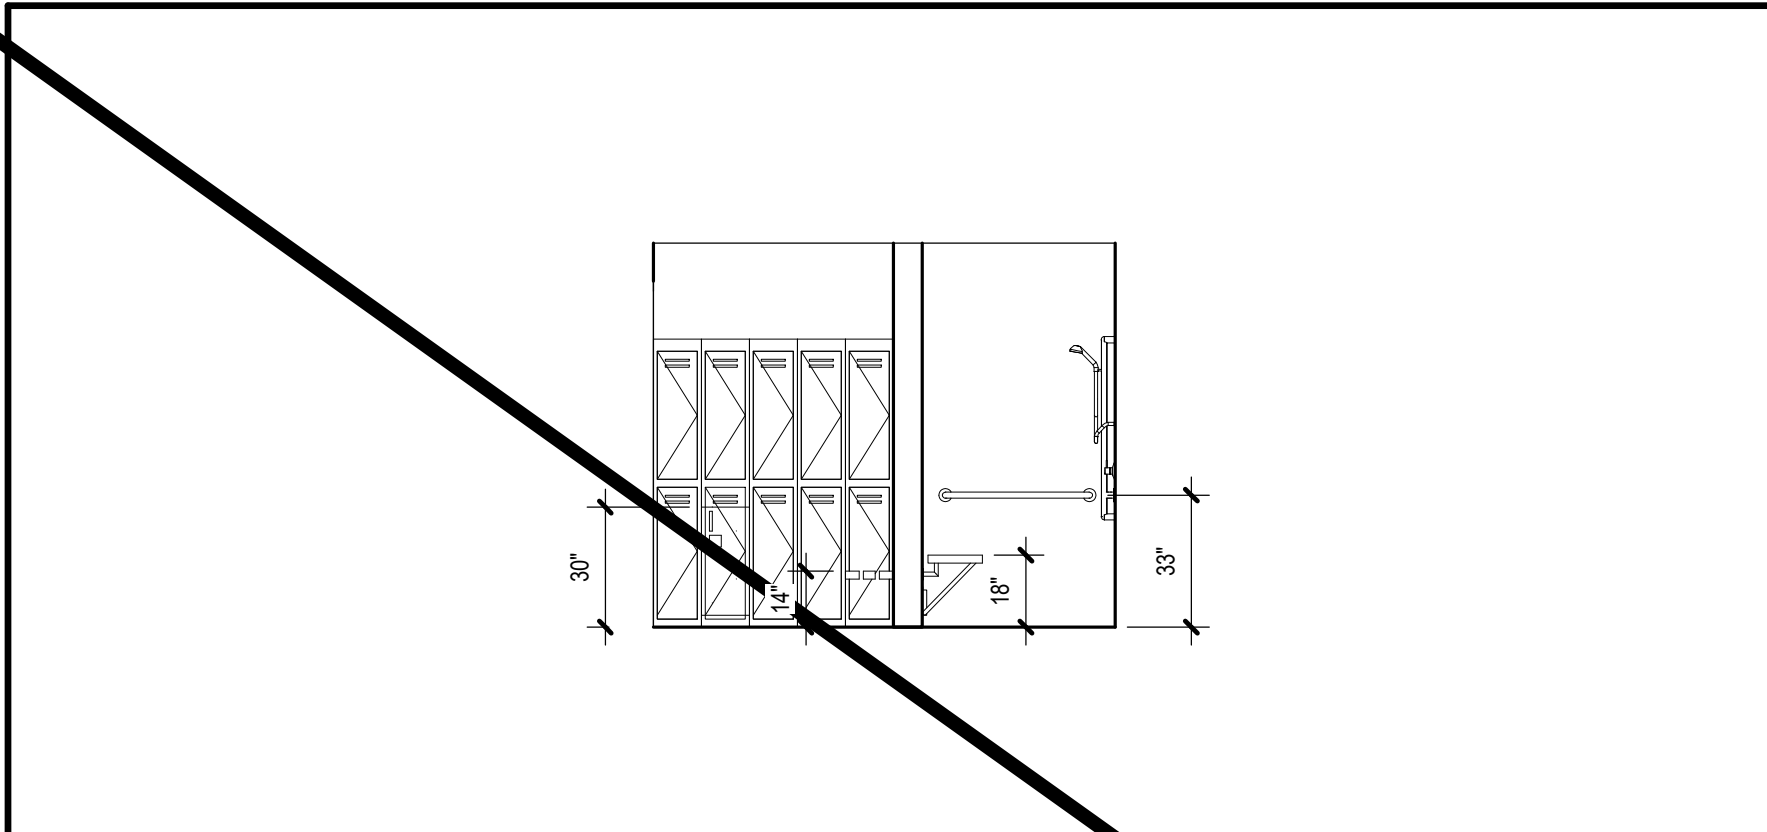

INTERIOR ELEVATION 1E02 - LOCKER SHOWER - EAST

1/4" = 1'-0"


12

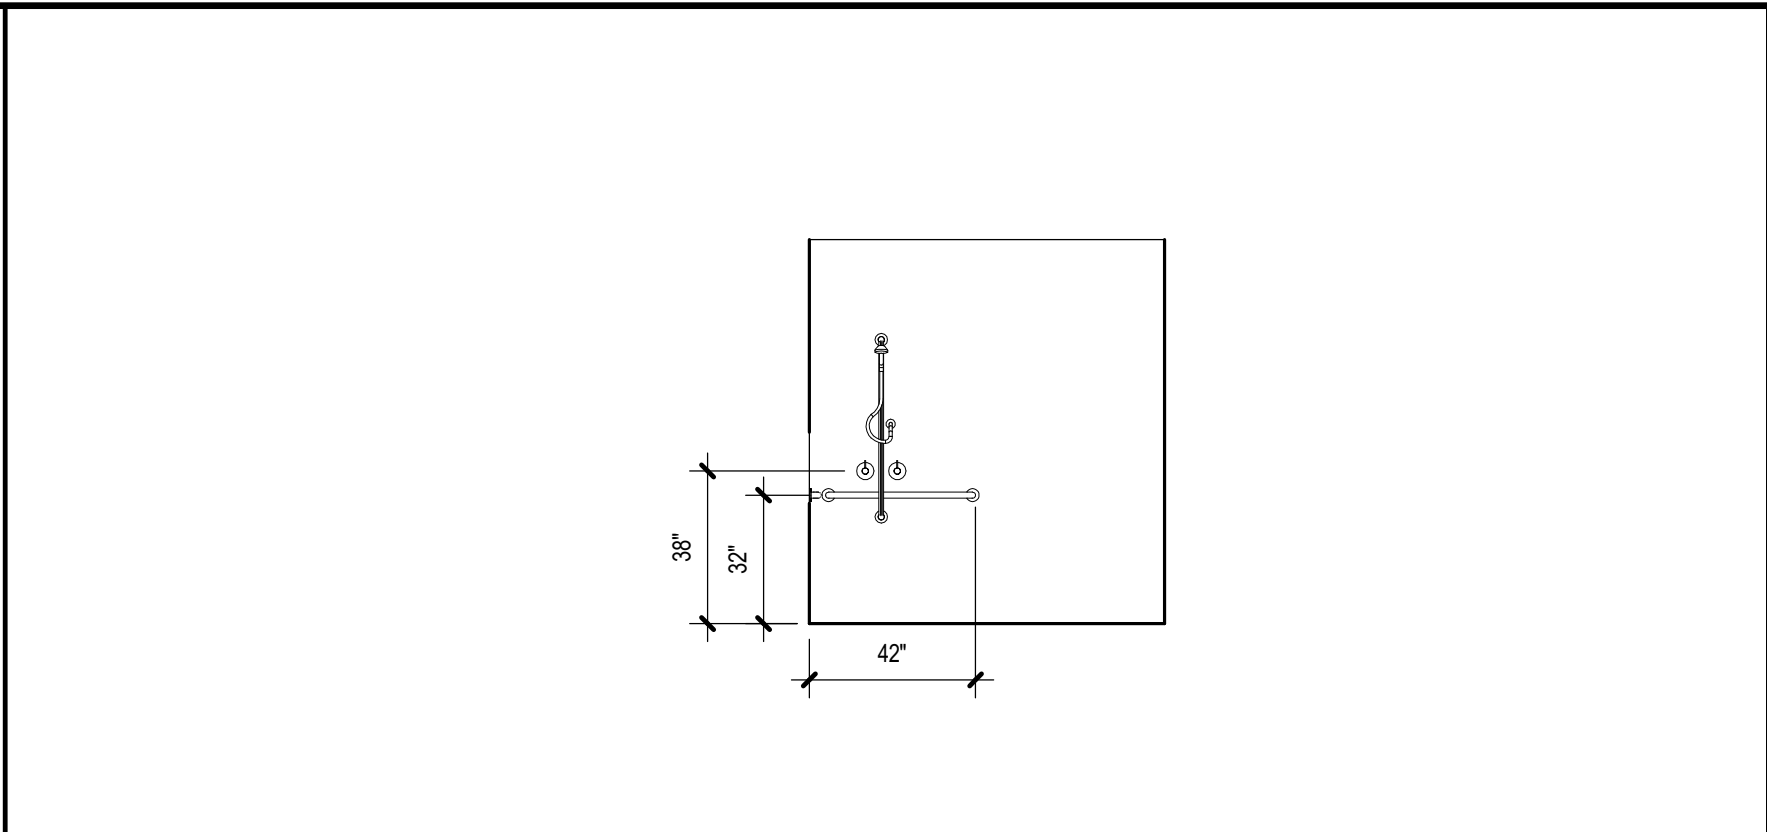

INTERIOR ELEVATION 1E02 - LOCKER SHOWER - SOUTH

1/4" = 1'-0"


11

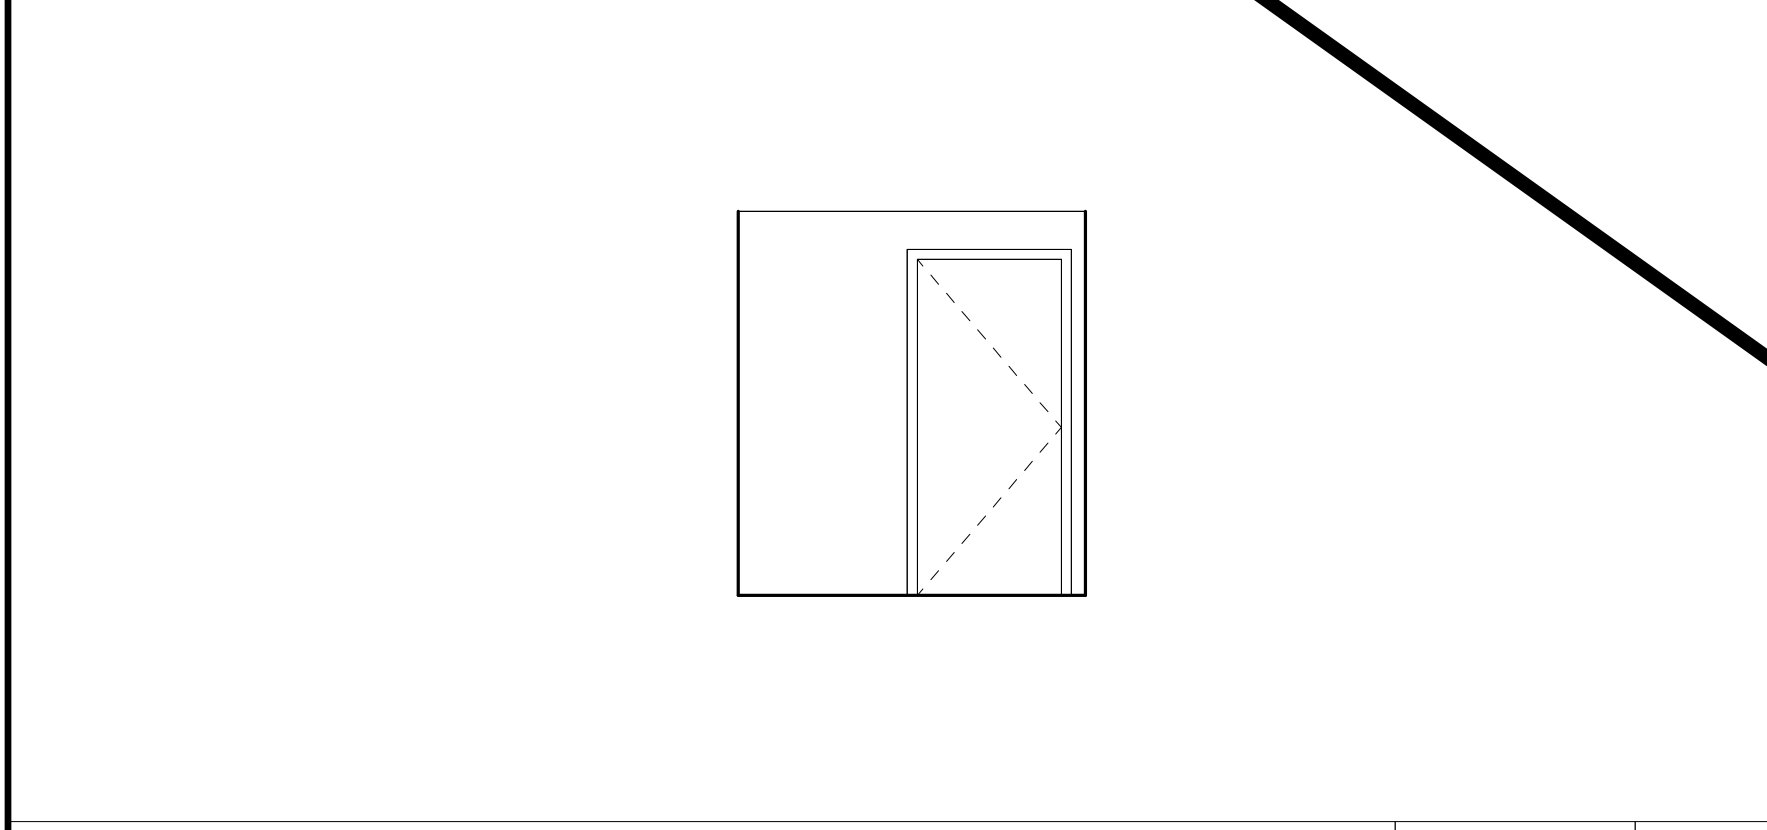

INTERIOR ELEVATION 2E03 - TOILET - NORTH

1/4" = 1'-0"


10

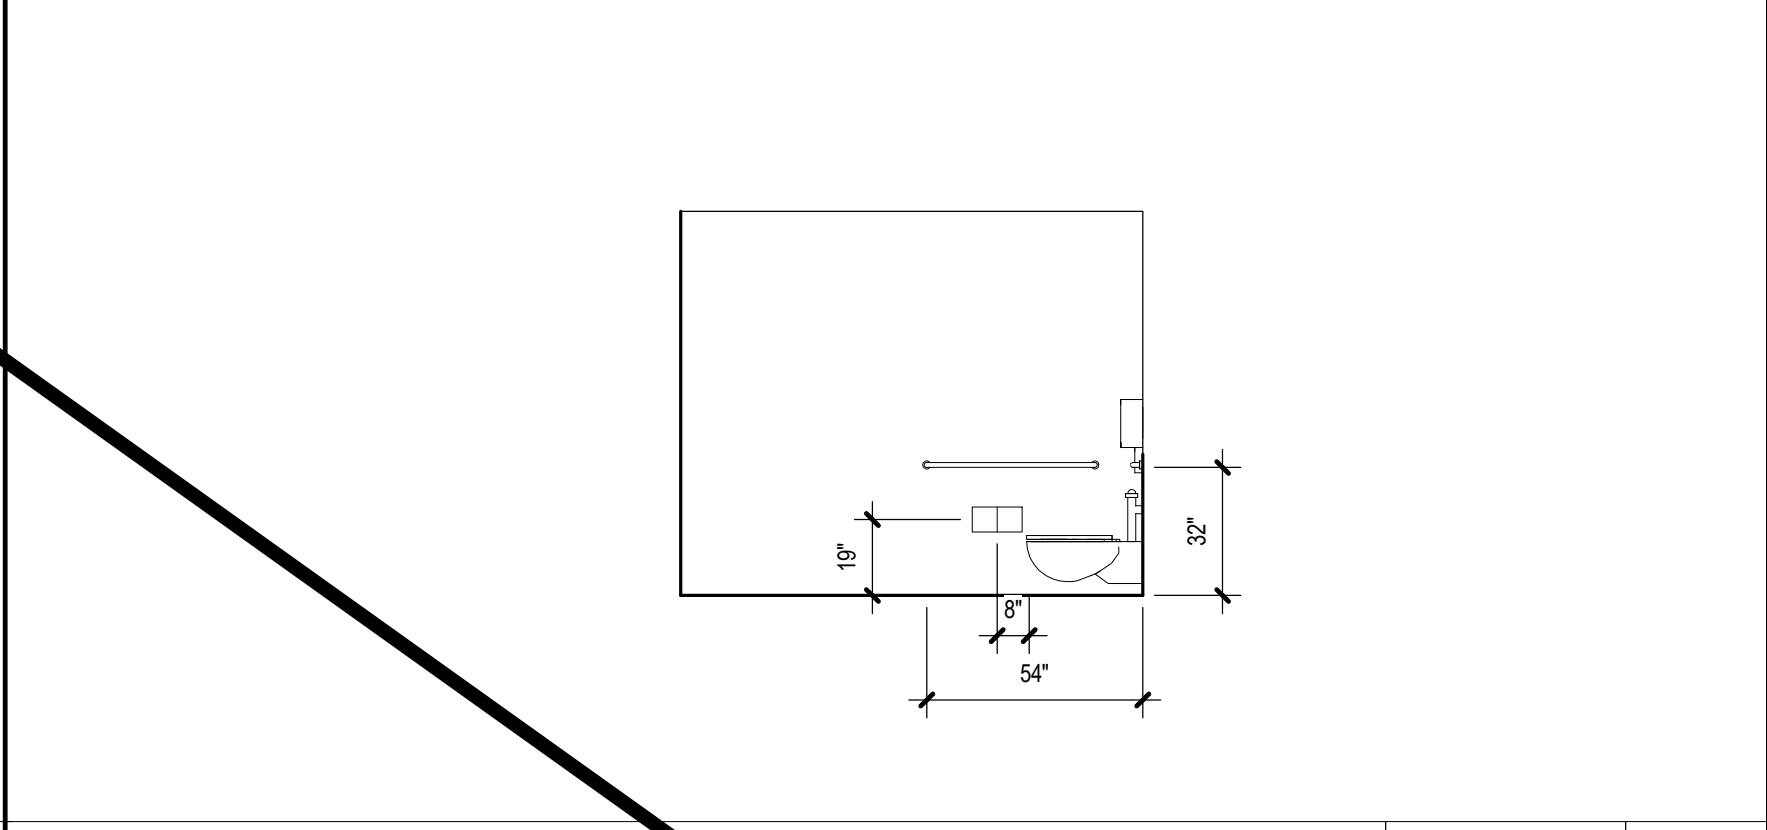

INTERIOR ELEVATION 2E03 - TOILET - EAST

1/4" = 1'-0"

 
9



INTERIOR ELEVATION 2E03 - TOILET - WEST

1/4" = 1'-0"


8

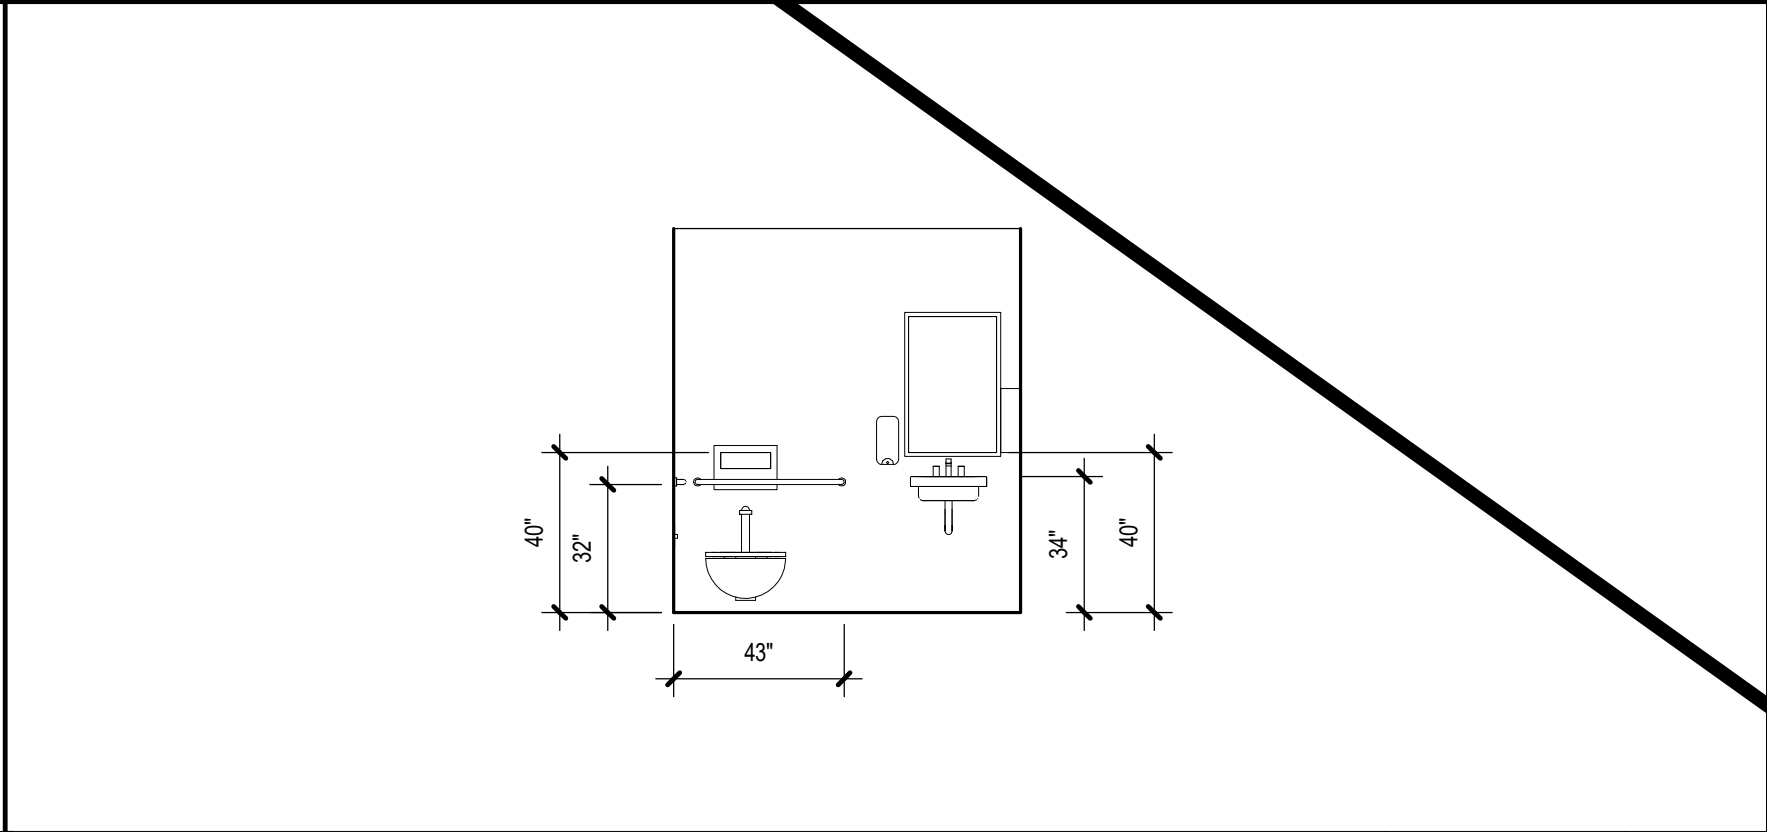

INTERIOR ELEVATION 2E03 - TOILET - SOUTH

1/4" = 1'-0"

 
7



INTERIOR ELEVATION 1H02A - NORTH

1/4" = 1'-0"


5

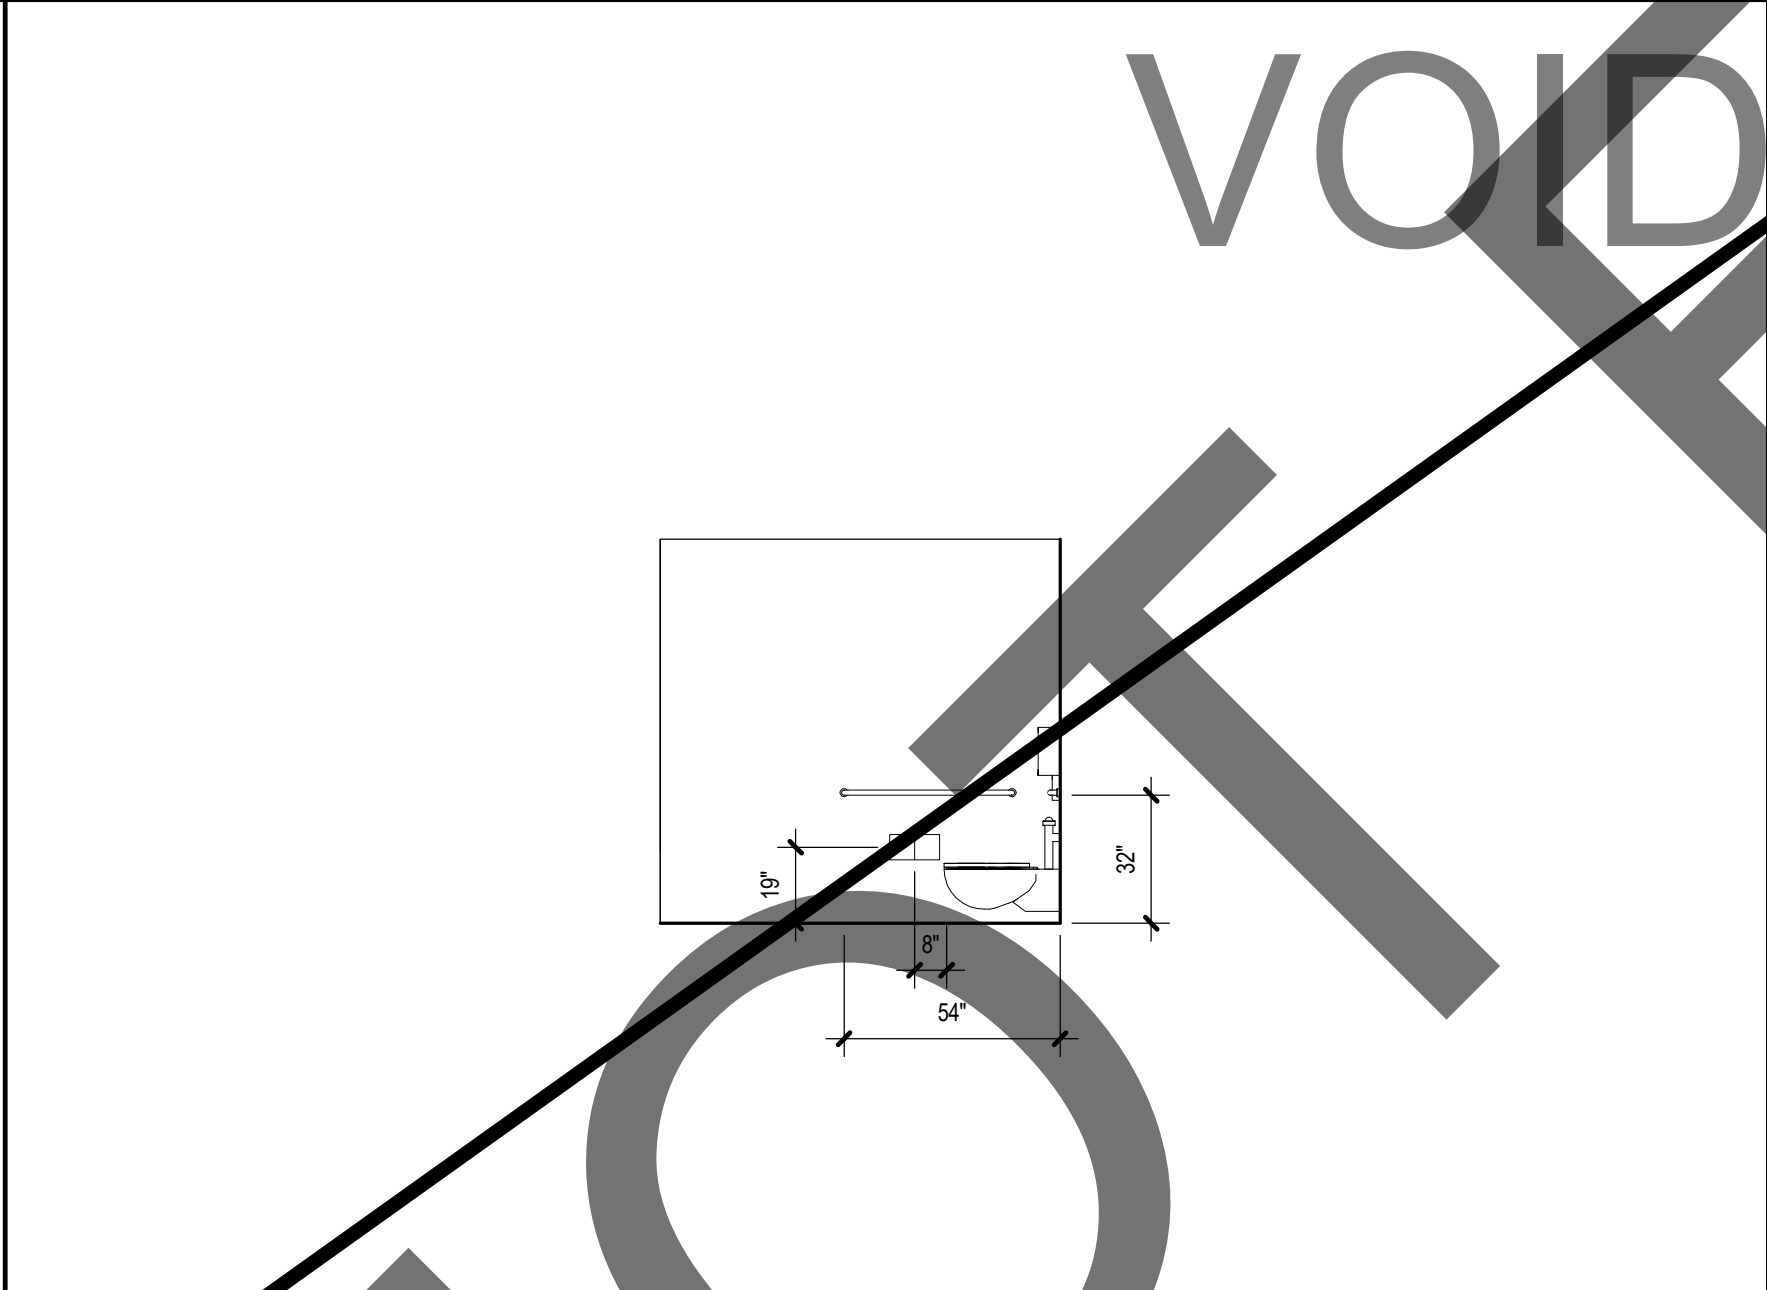

INTERIOR ELEVATION 1H02A - EAST

1/4" = 1'-0"


4

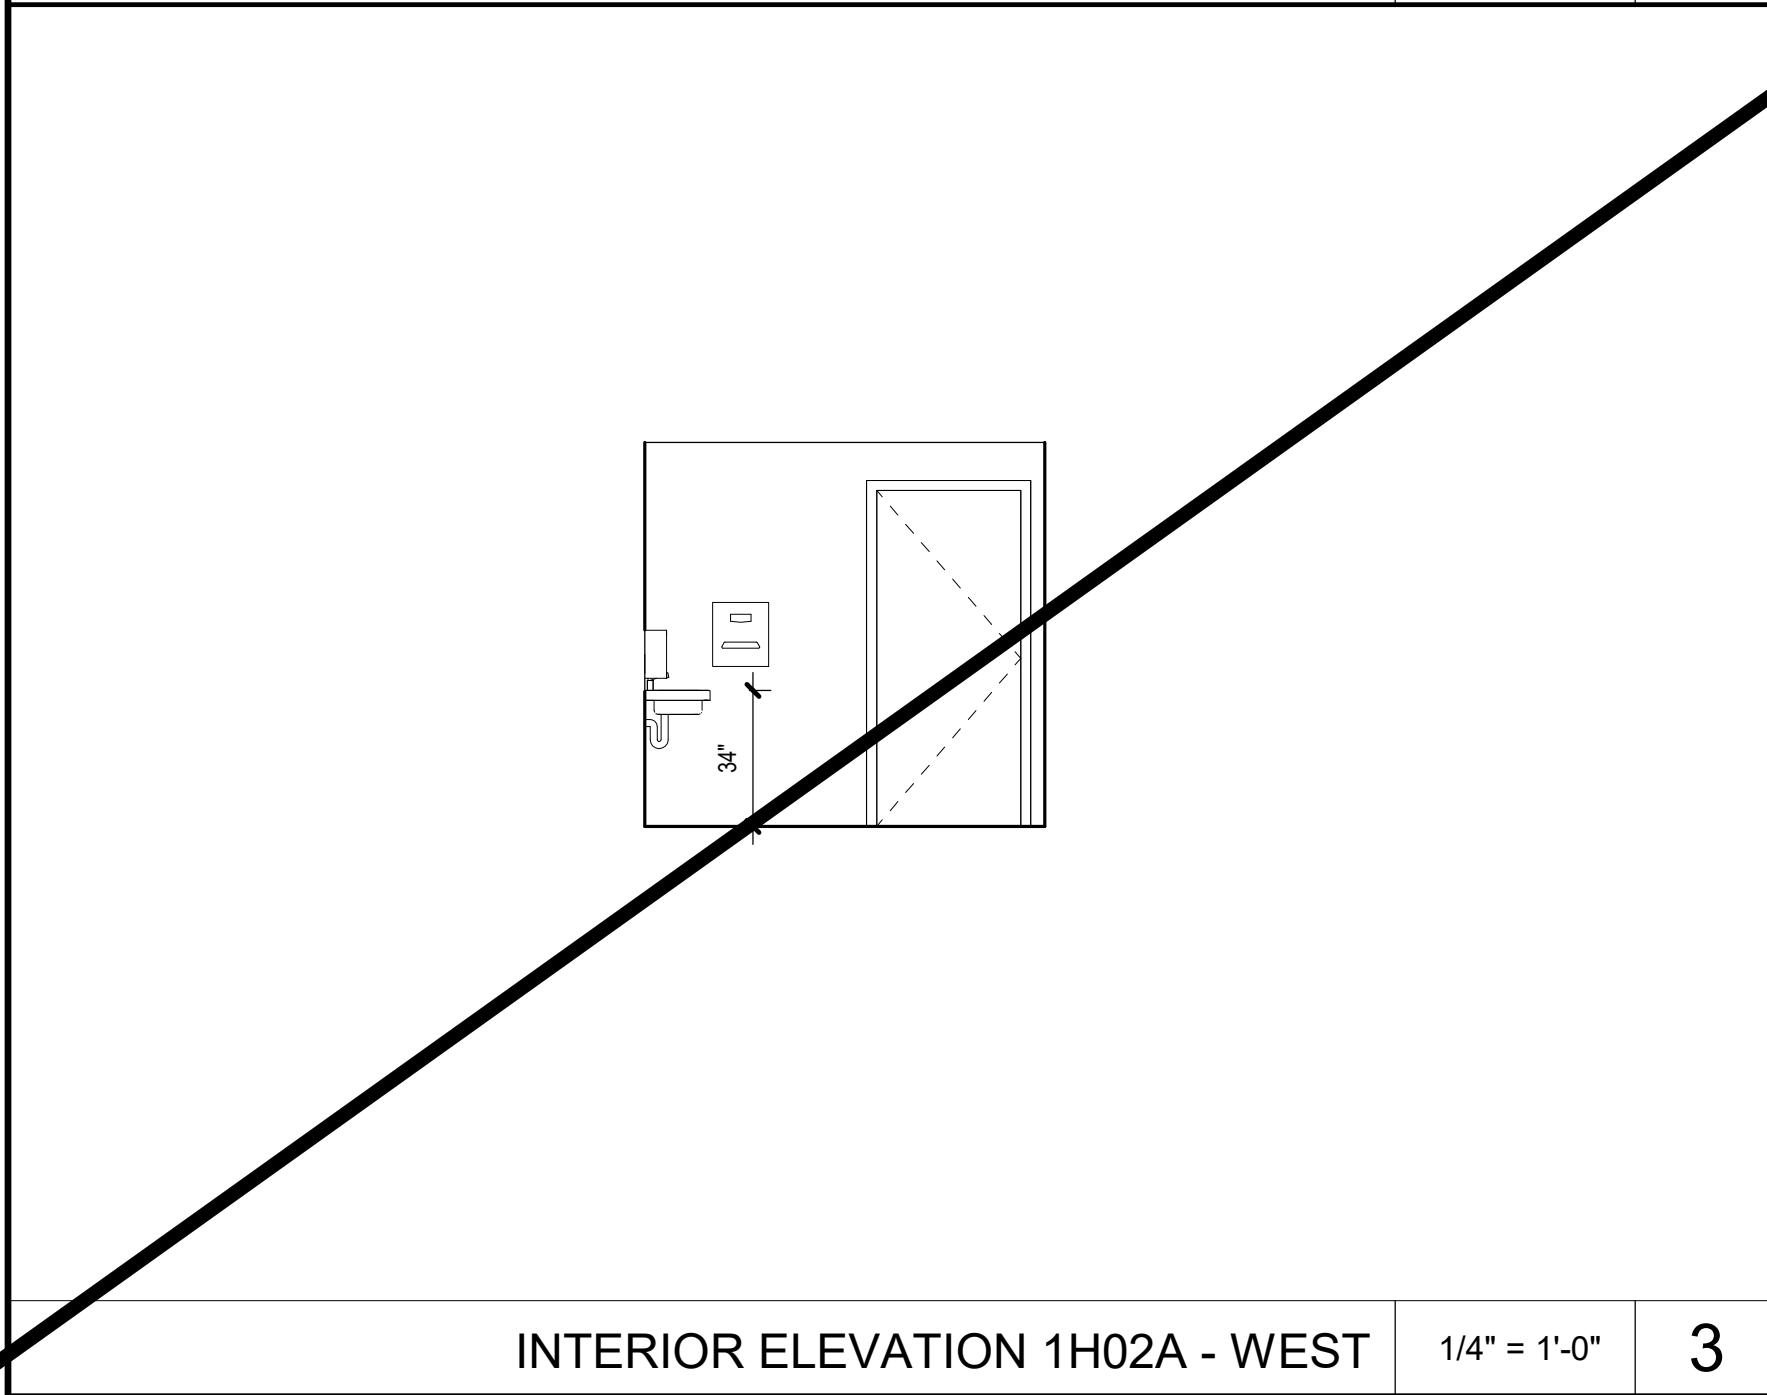

INTERIOR ELEVATION 1H02A - WEST

1/4" = 1'-0"


3

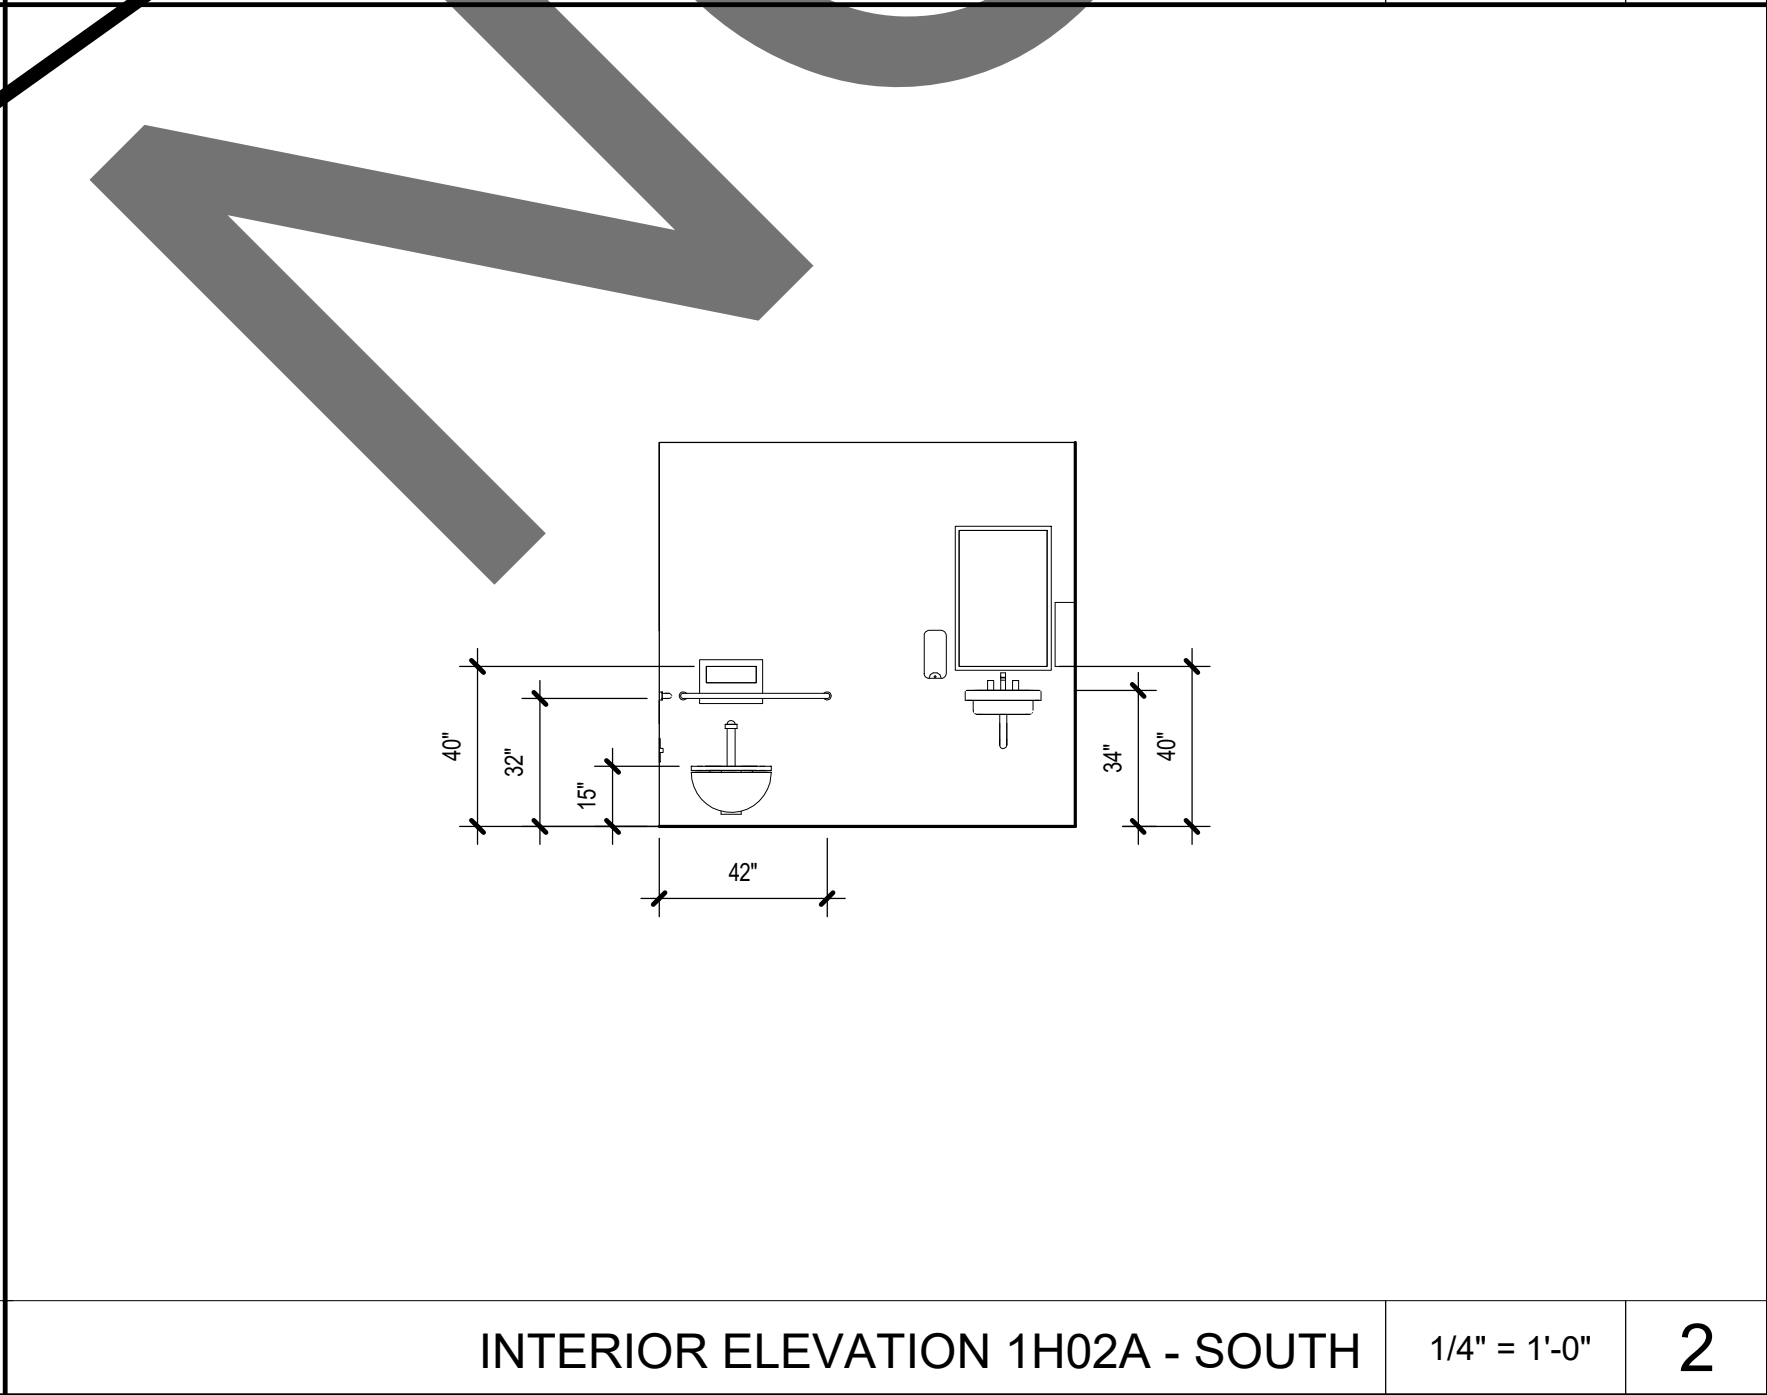

INTERIOR ELEVATION 1H02A - SOUTH

1/4" = 1'-0"


2

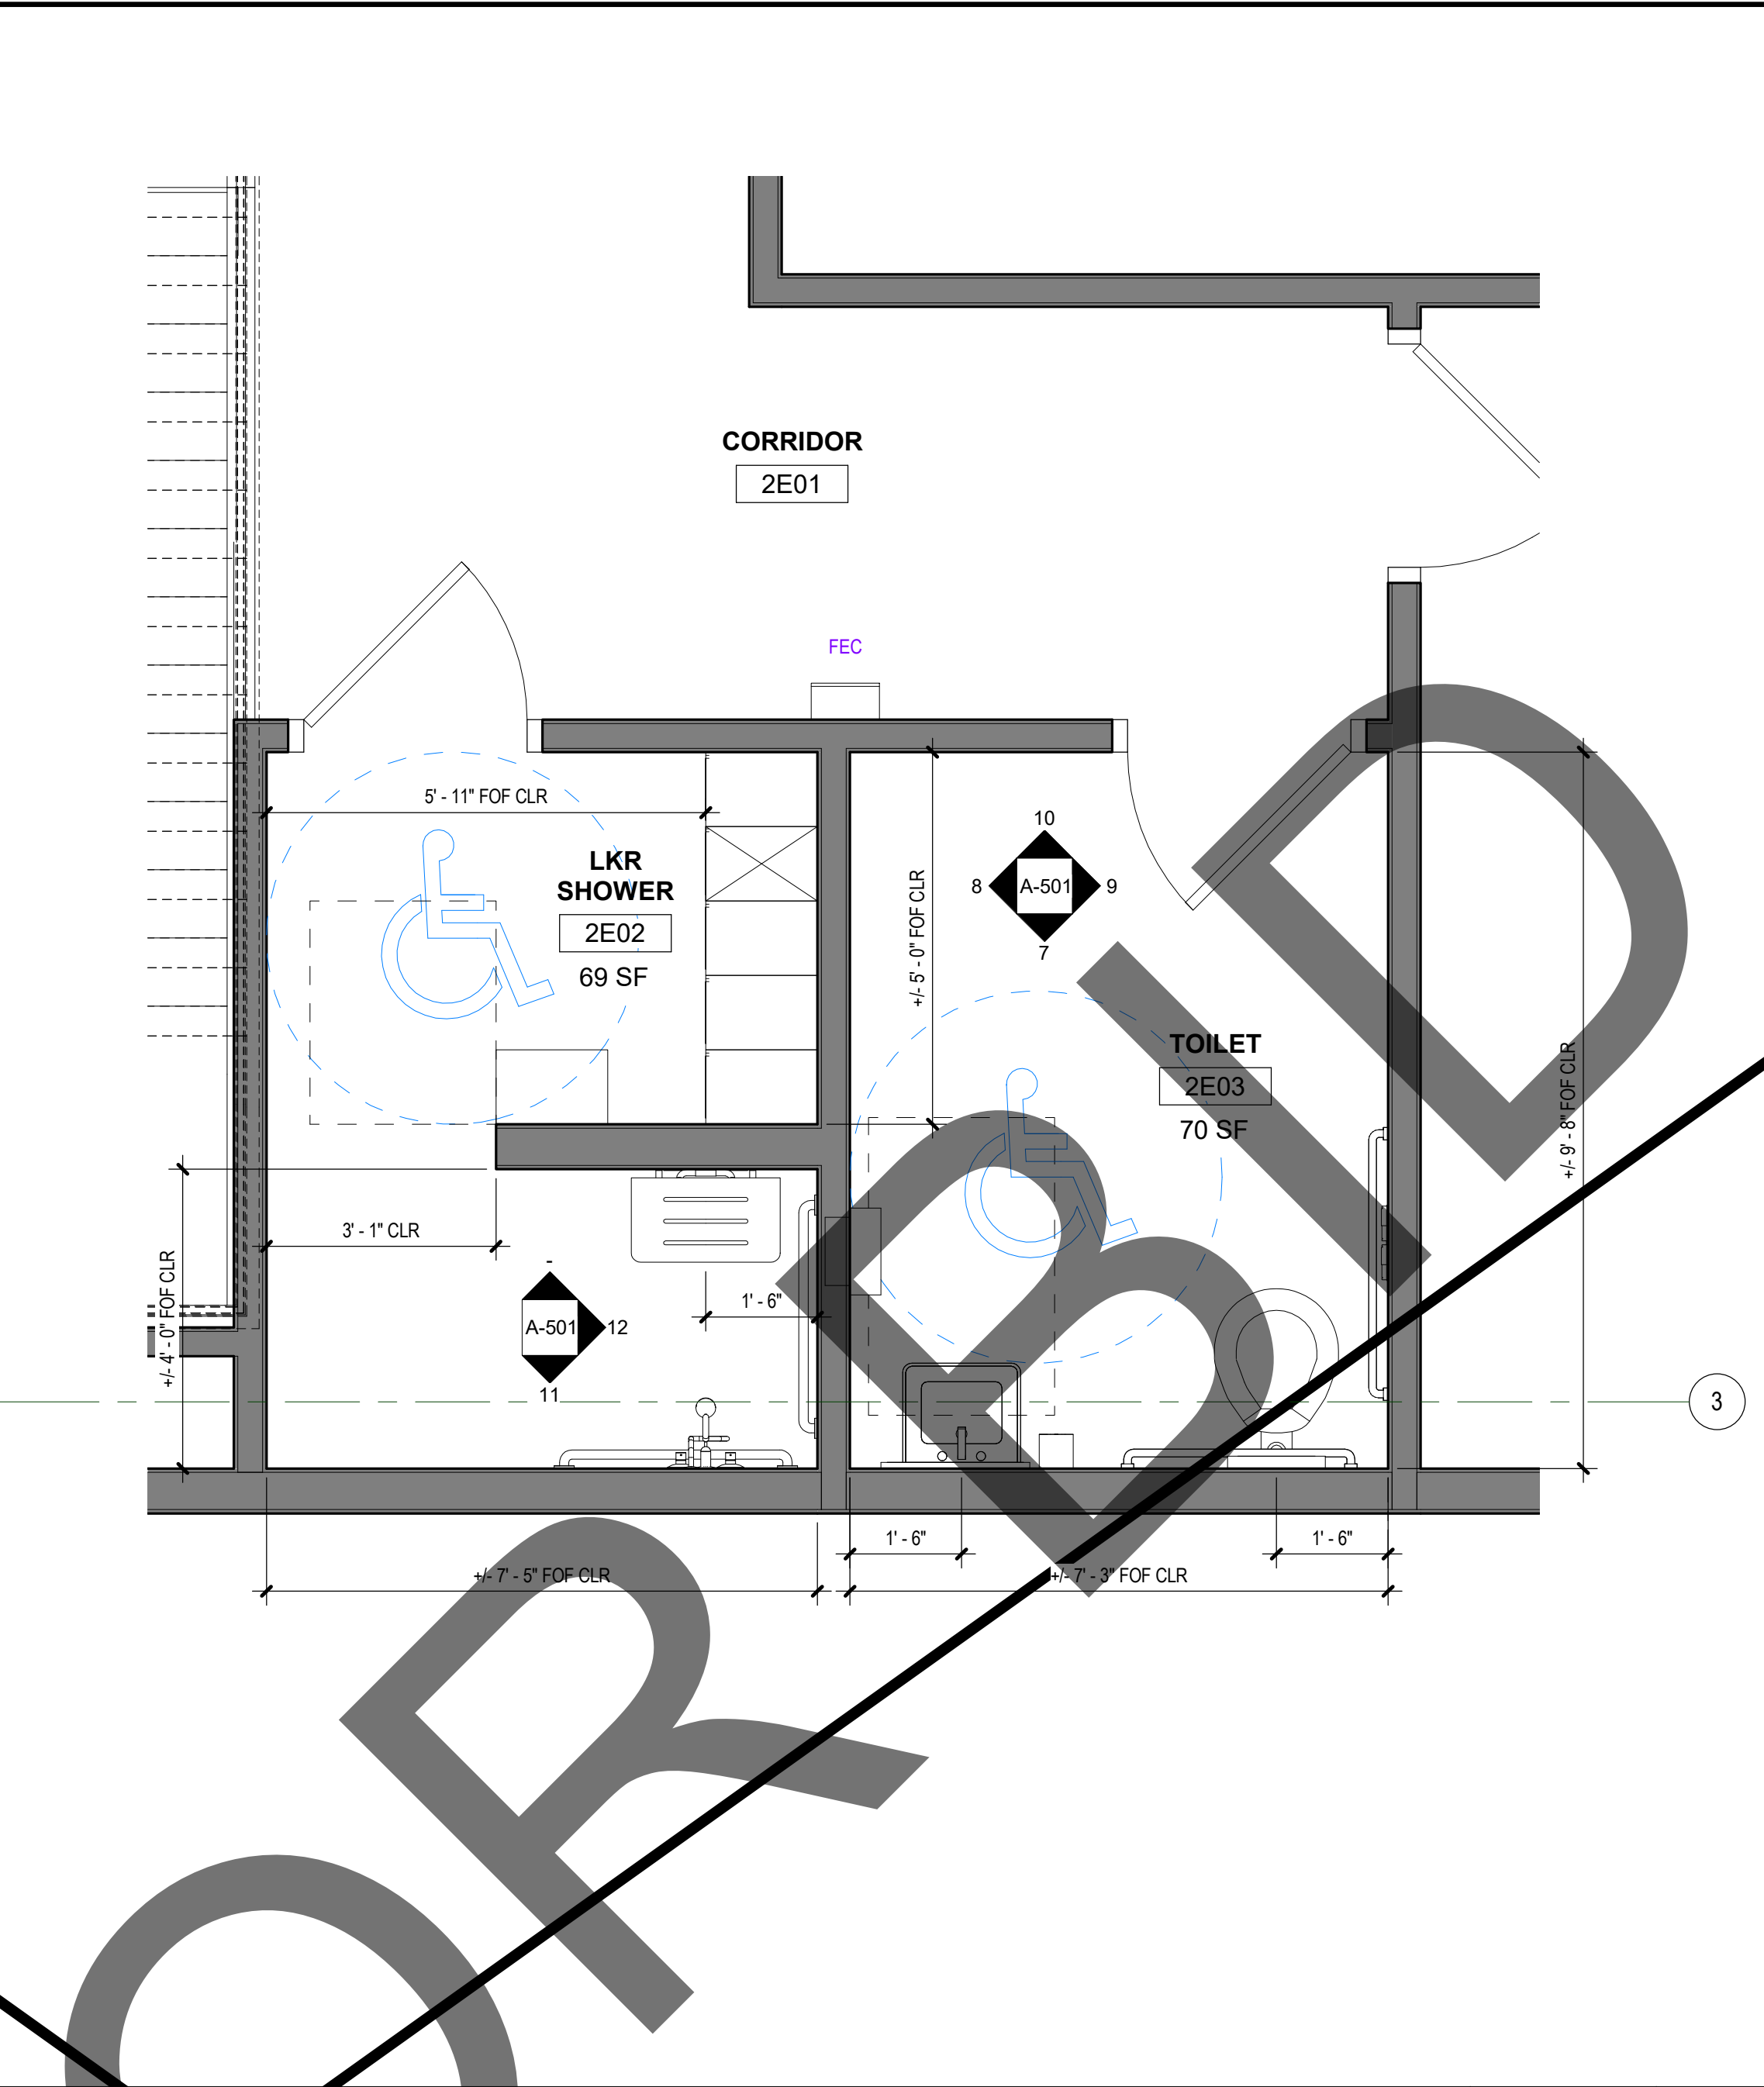

ENLARGED AT EXISTING SECOND FLOOR TOILET & SHOWER/LOCKER

1/2" = 1'-0"

6

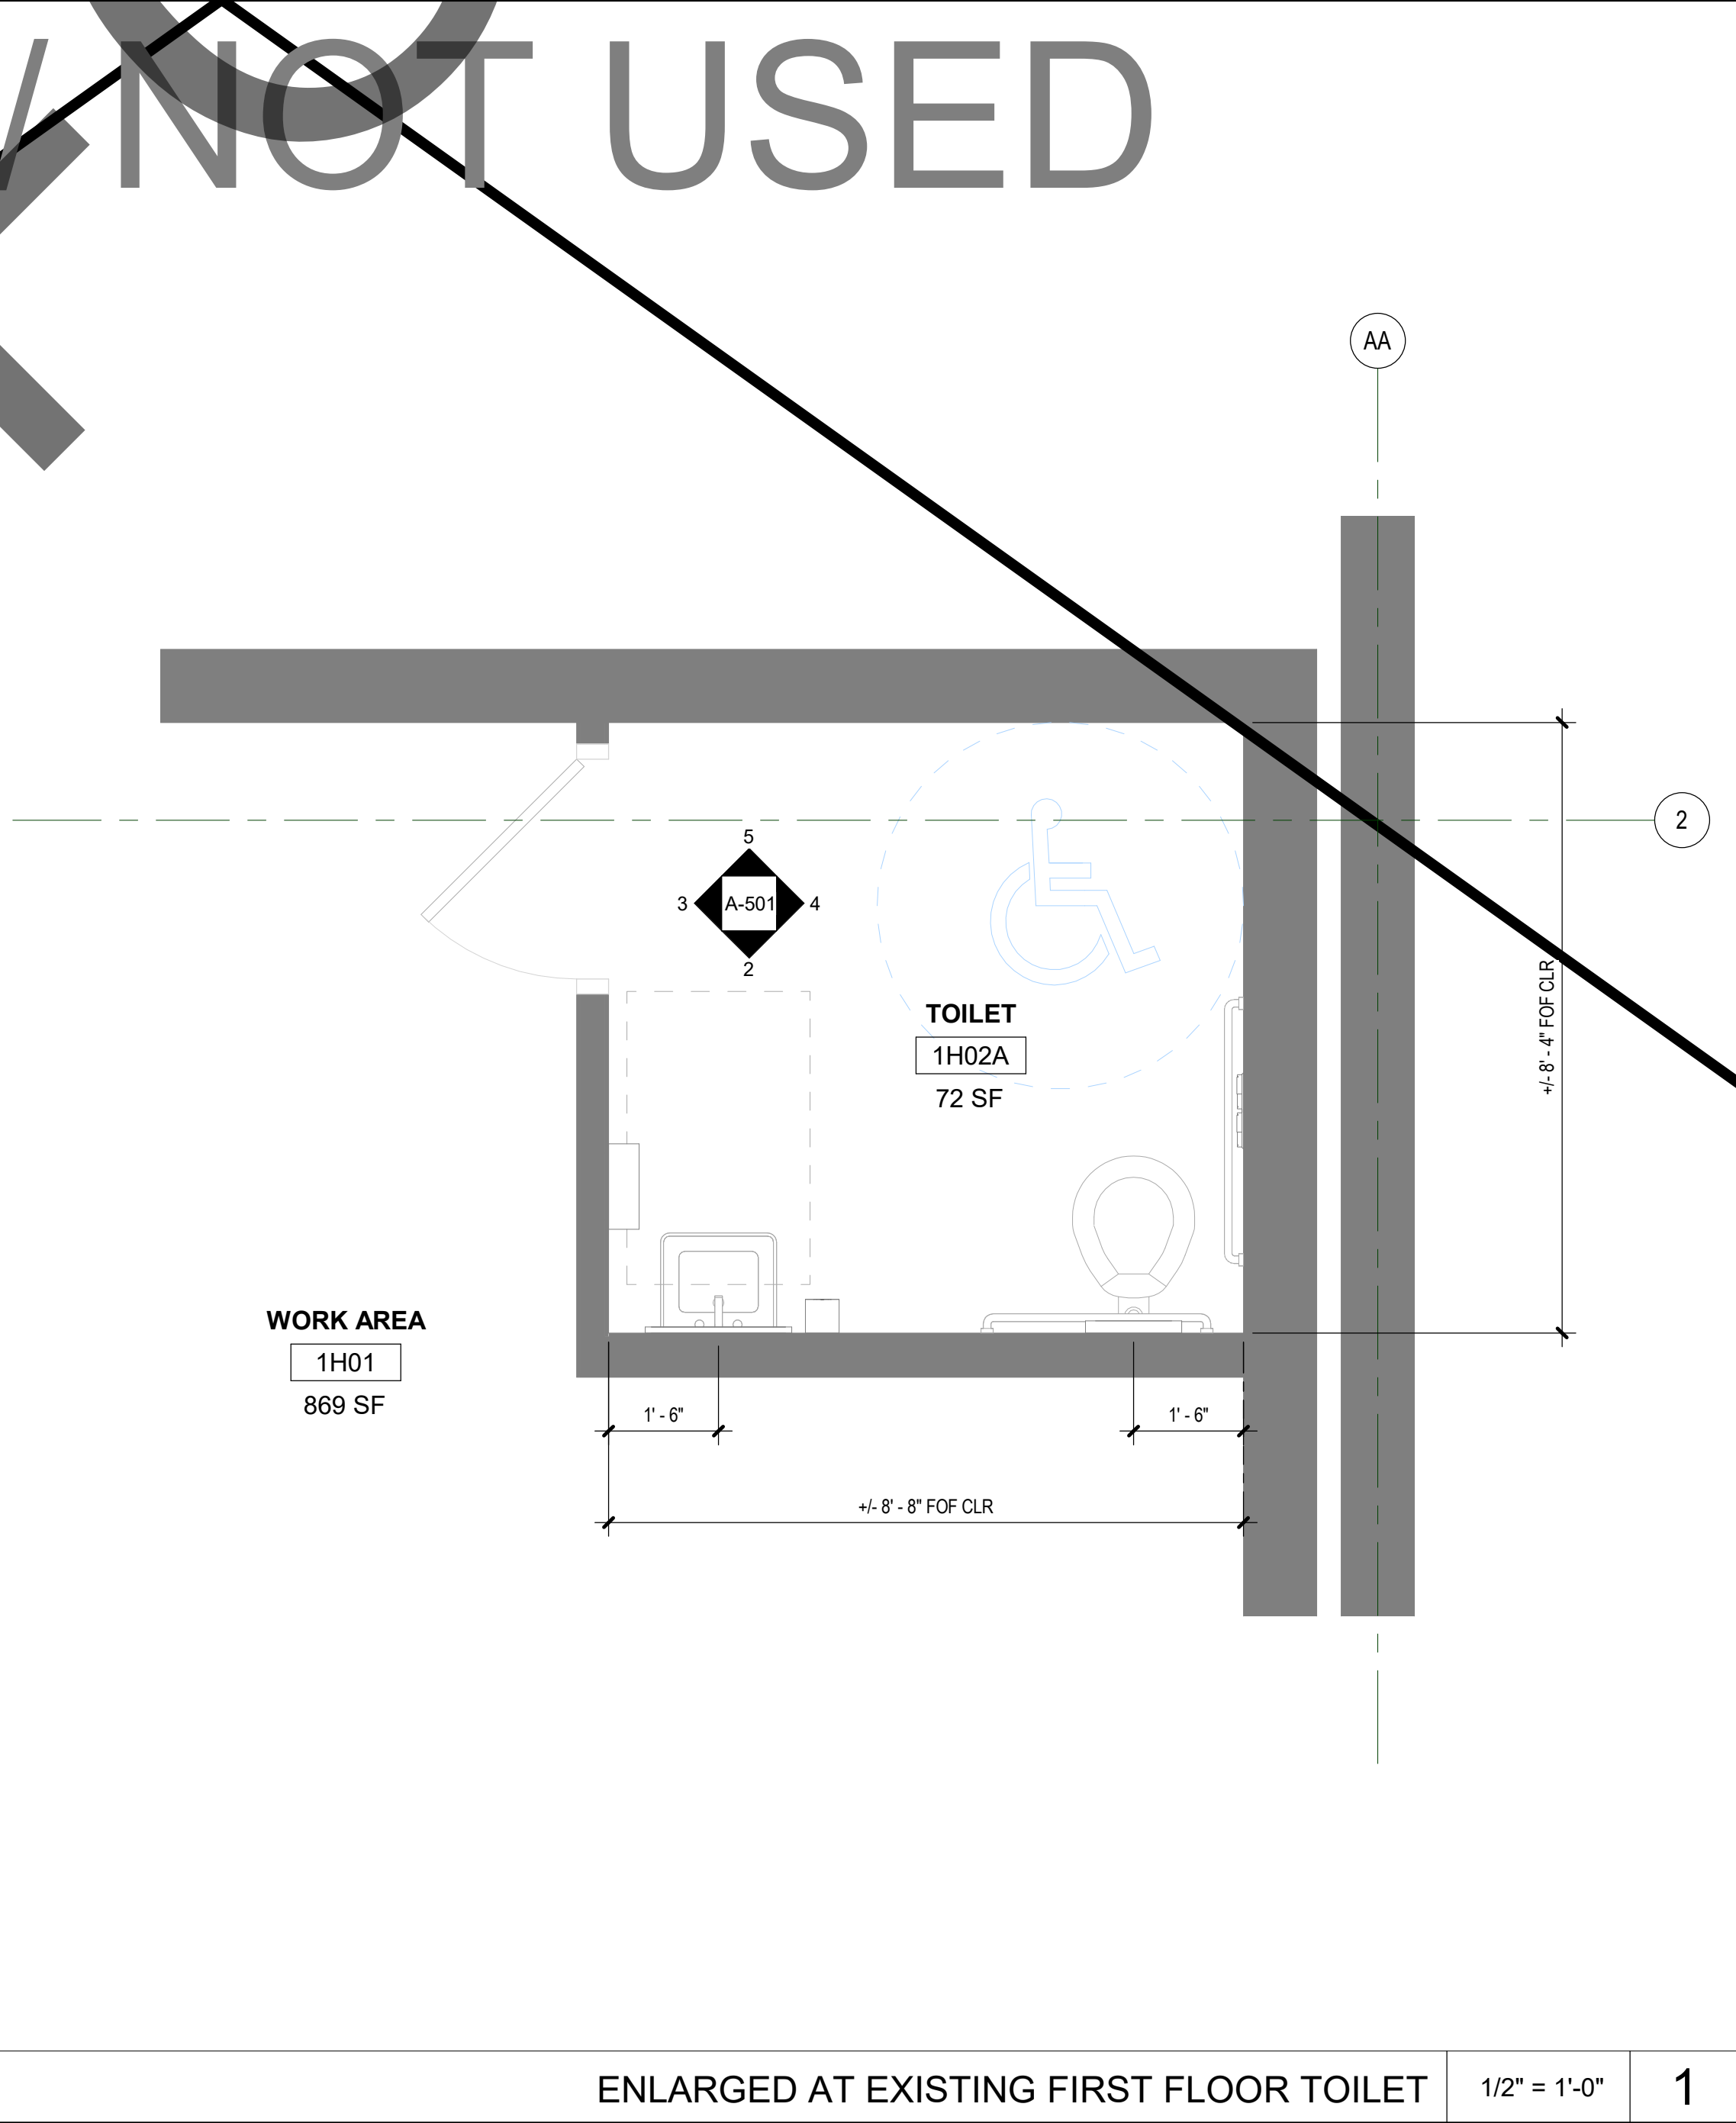

ENLARGED AT EXISTING FIRST FLOOR TOILET

1/2" = 1'-0"

1

GENERAL NOTES

1. FOR REFERENCE ONLY. THE PURPOSE OF THIS DRAWING IS TO ILLUSTRATE THE EXISTING ACCESSIBLE TOILET FACILITIES AS SHOWN IN THE CENTRAL PLANT BUILDING. THESE AREAS ARE NOT IN CONTRACT AS PART OF THE MECHANICAL EQUIPMENT REPLACEMENT.
2. REFER TO G-011 FOR ACCESSIBLE FIXTURES AND SIGNAGE.

KEY PLAN

APPROVAL

CLIENT

SAN BERNARDINO COUNTY

SAN BERNARDINO COUNTY
PROJECT AND FACILITIES
MANAGEMENT DEPARTMENT

385 NORTH ARROWHEAD AVENUE, 3RD FLOOR SAN
BERNARDINO, CA 92415-0184

PROJECT NAME

REPLACEMENT DEAEARATOR

PROJECT ADDRESS

400 N PEPPER AVE, COLTON, CA 92324

OSHDP/HCAI PROJECT NO.

S230562-36-00

FACILITY NO.

17282

BUILDING NO.

BLD-00075 CENTRAL PLANT

ENGINEER/ARCHITECT

IDS

IDS GROUP

1 PETERS CANYON ROAD, SUITE 130
IRVINE, CA 92606
TEL: 949-387-8500, FAX: 949-387-0800

STAMP

NOT USED

STAMP

NOT USED

ISSUE		
REV.	DESCRIPTION	DATE
	HCAI SUBMITTAL	03/01/23
	HCAI BC 1	06/13/23
	HCAI BC 2	07/28/23

PROJECT IDENTIFICATION

THE ORIGINAL SIZE OF THIS SHEET IS 30" X 42"

THESE DRAWINGS AND SPECIFICATIONS ARE THE PROPERTY AND
COPYRIGHT OF IDS GROUP AND SHALL NOT BE USED ON ANY
OTHER PROJECT OR LOCATIONS EXCEPT AS DESCRIBED ON THE
DRAWINGS, WITHOUT THE WRITTEN AGREEMENT WITH IDS GROUP.

IDS PROJECT NO.

22X66.02

DRAWN BY

CKC

CHECKED BY

CKC

APPROVED BY

JHM

SHEET TITLE

**ENLARGED PLANS
AT EXISTING
TOILETS NOT
USED**


SHEET NUMBER

A-501




SHEET NO.

OF



IDS GROUP - FILE LOCATION: S:\PROJECTS\2022\SHARED\22X066.02 ARMC - REPLACEMENT DEAERATOR 105 CAD\03 STRUCS-500 - DETAILS - PLOT DATE: 6/6/2023 5:10:31 PM USER: MATTHEW.MICHNEWICH

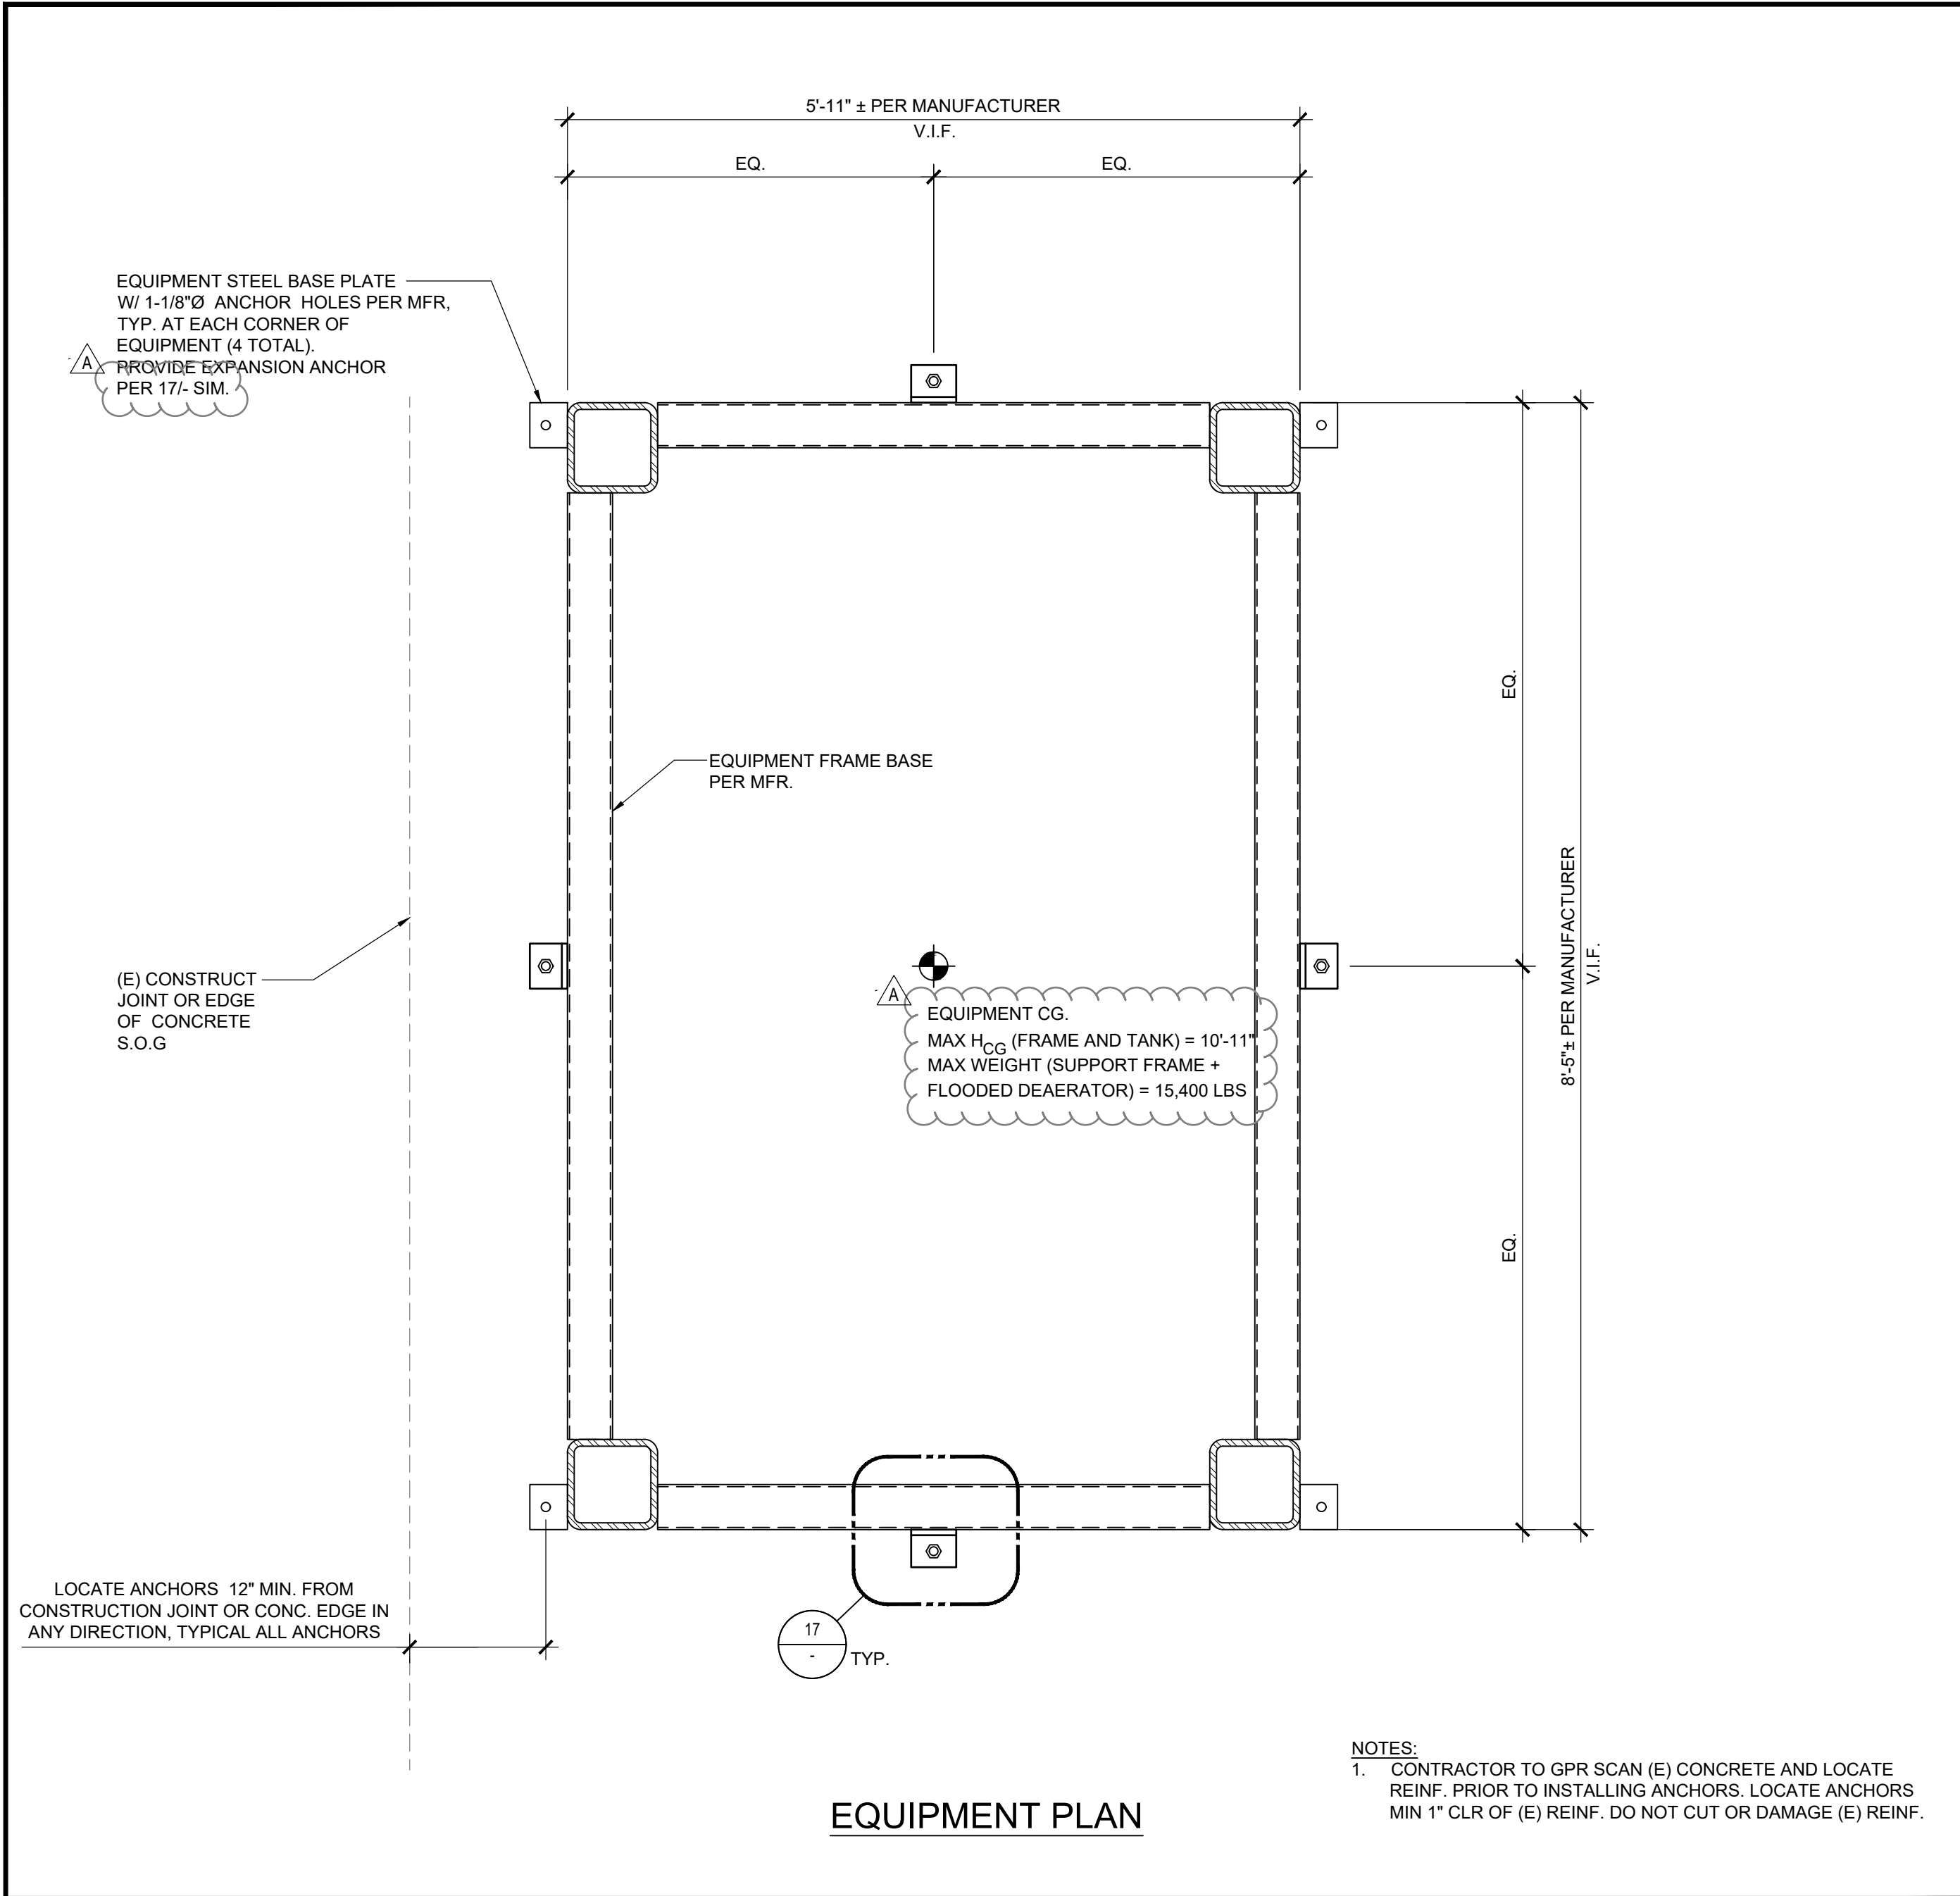

TEMPORARY DEAERATOR PLAN 1"=1'-0" 15

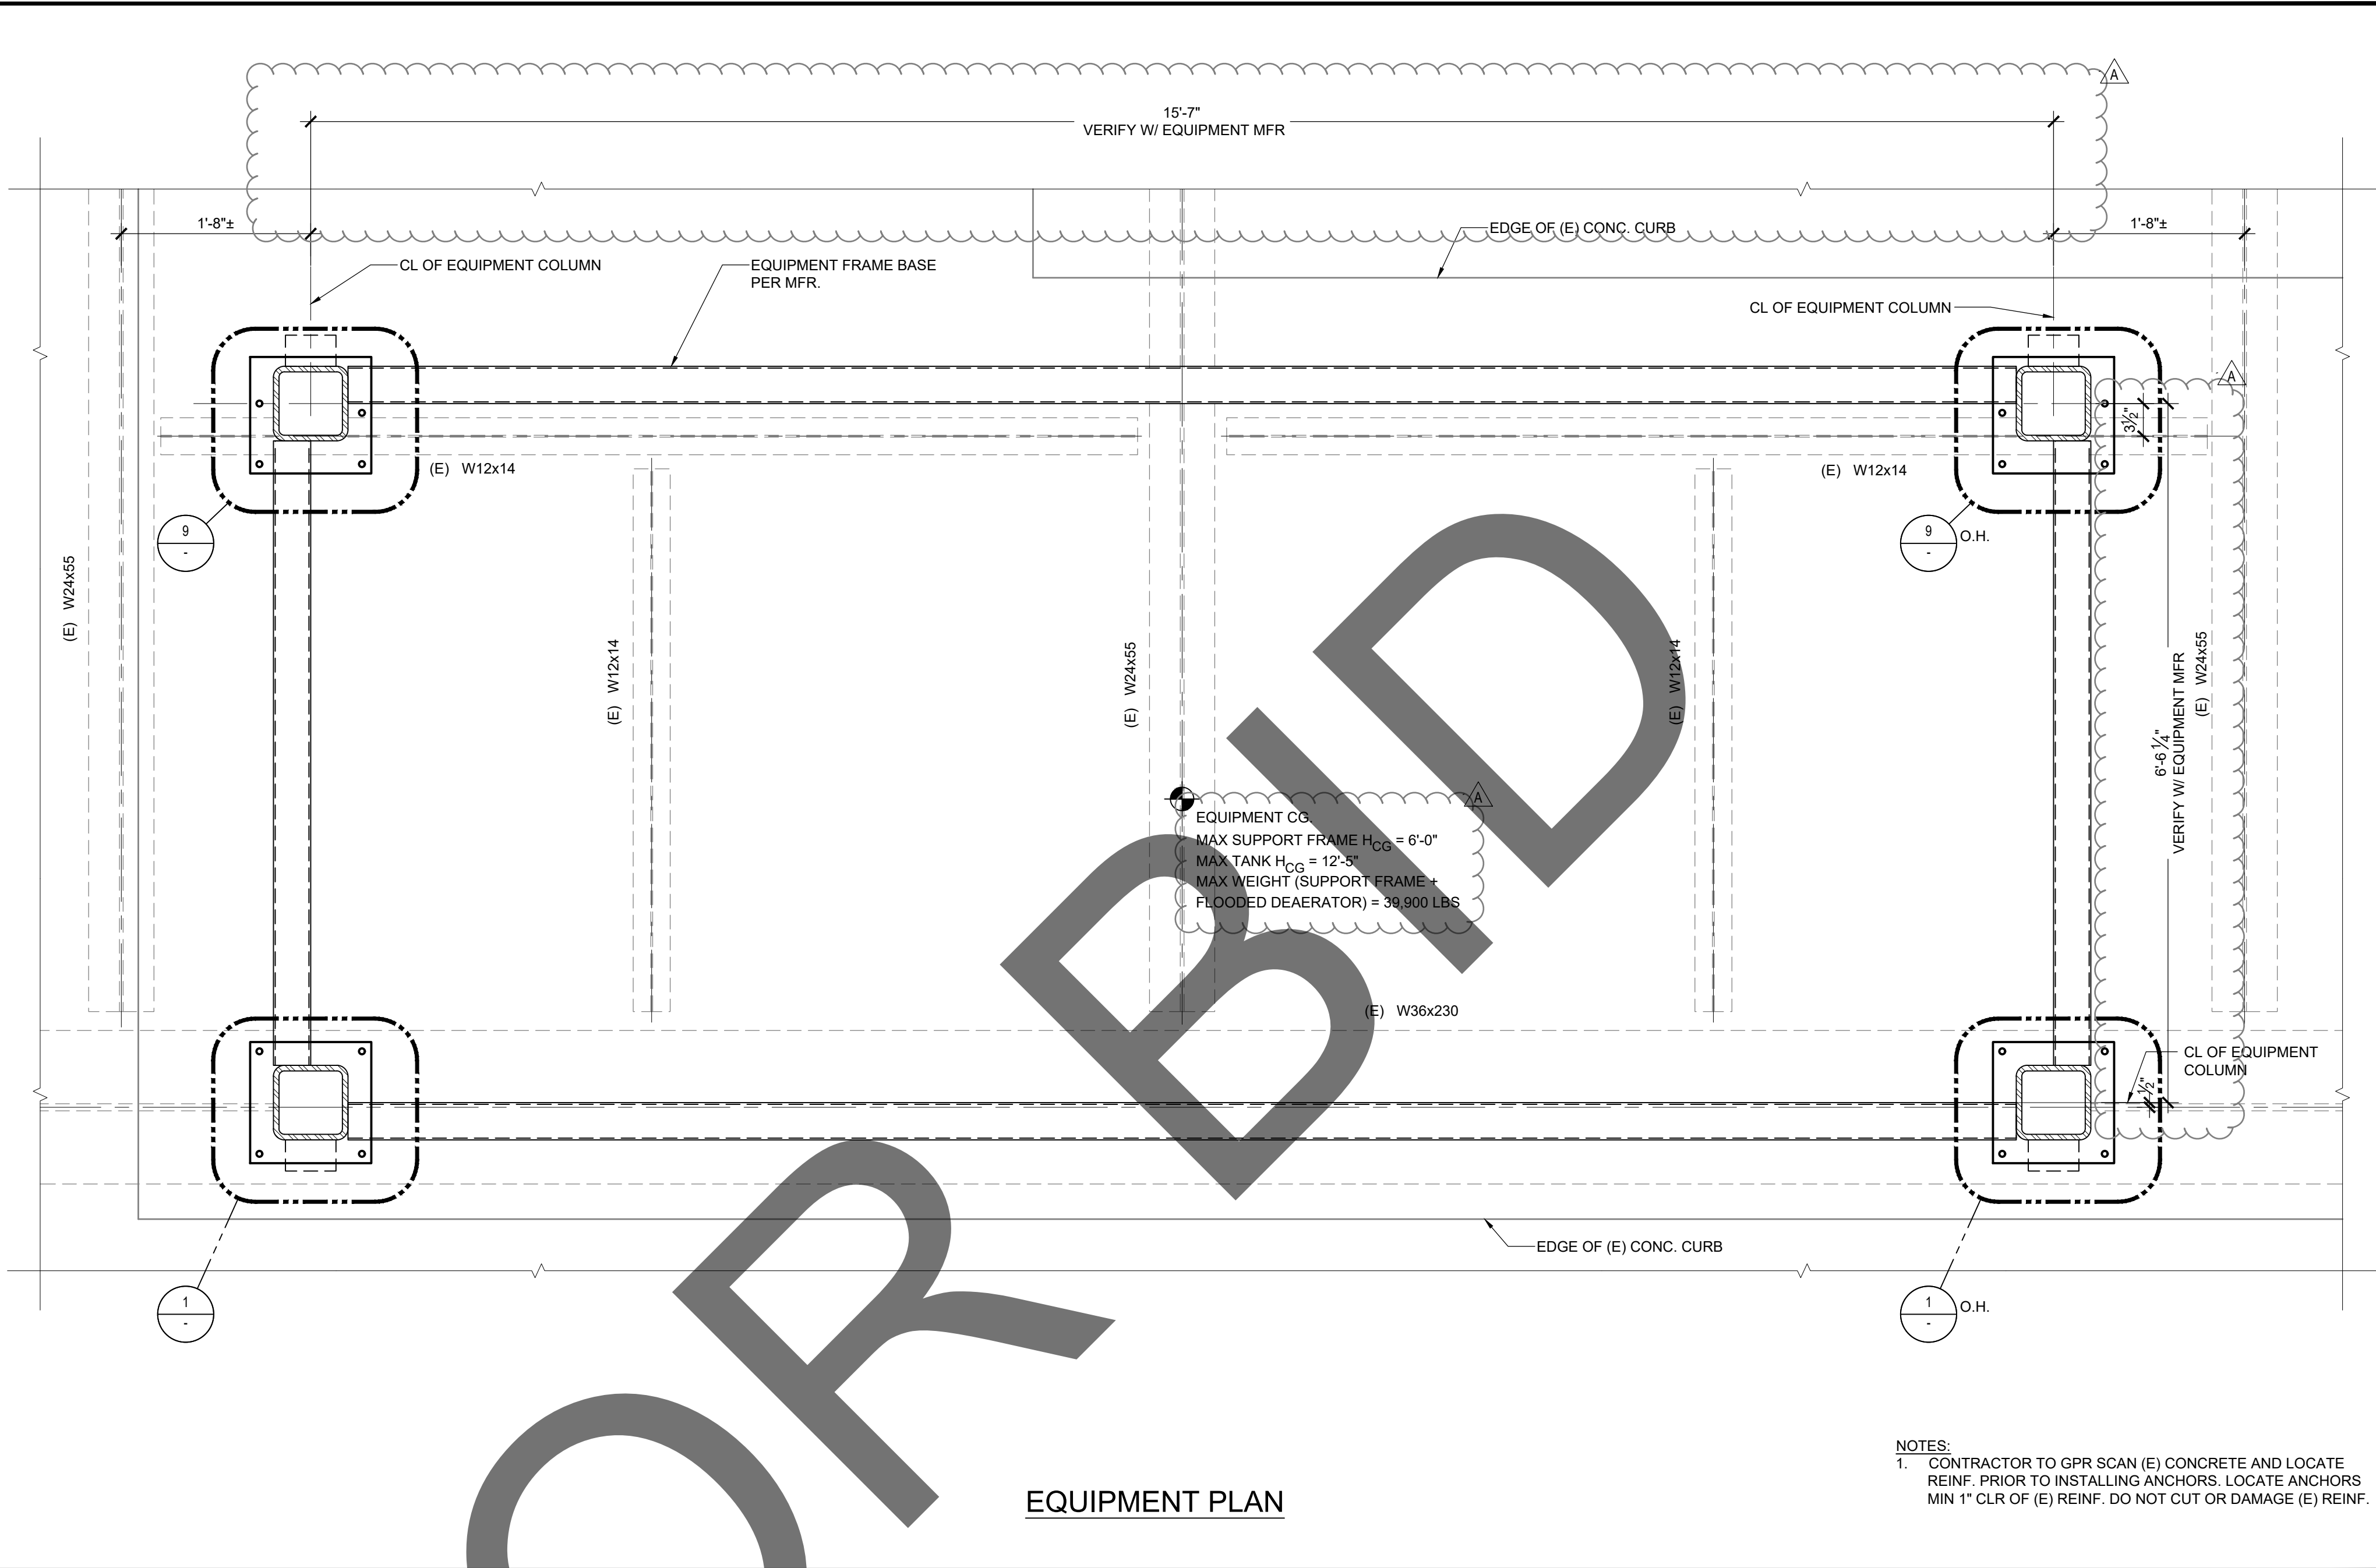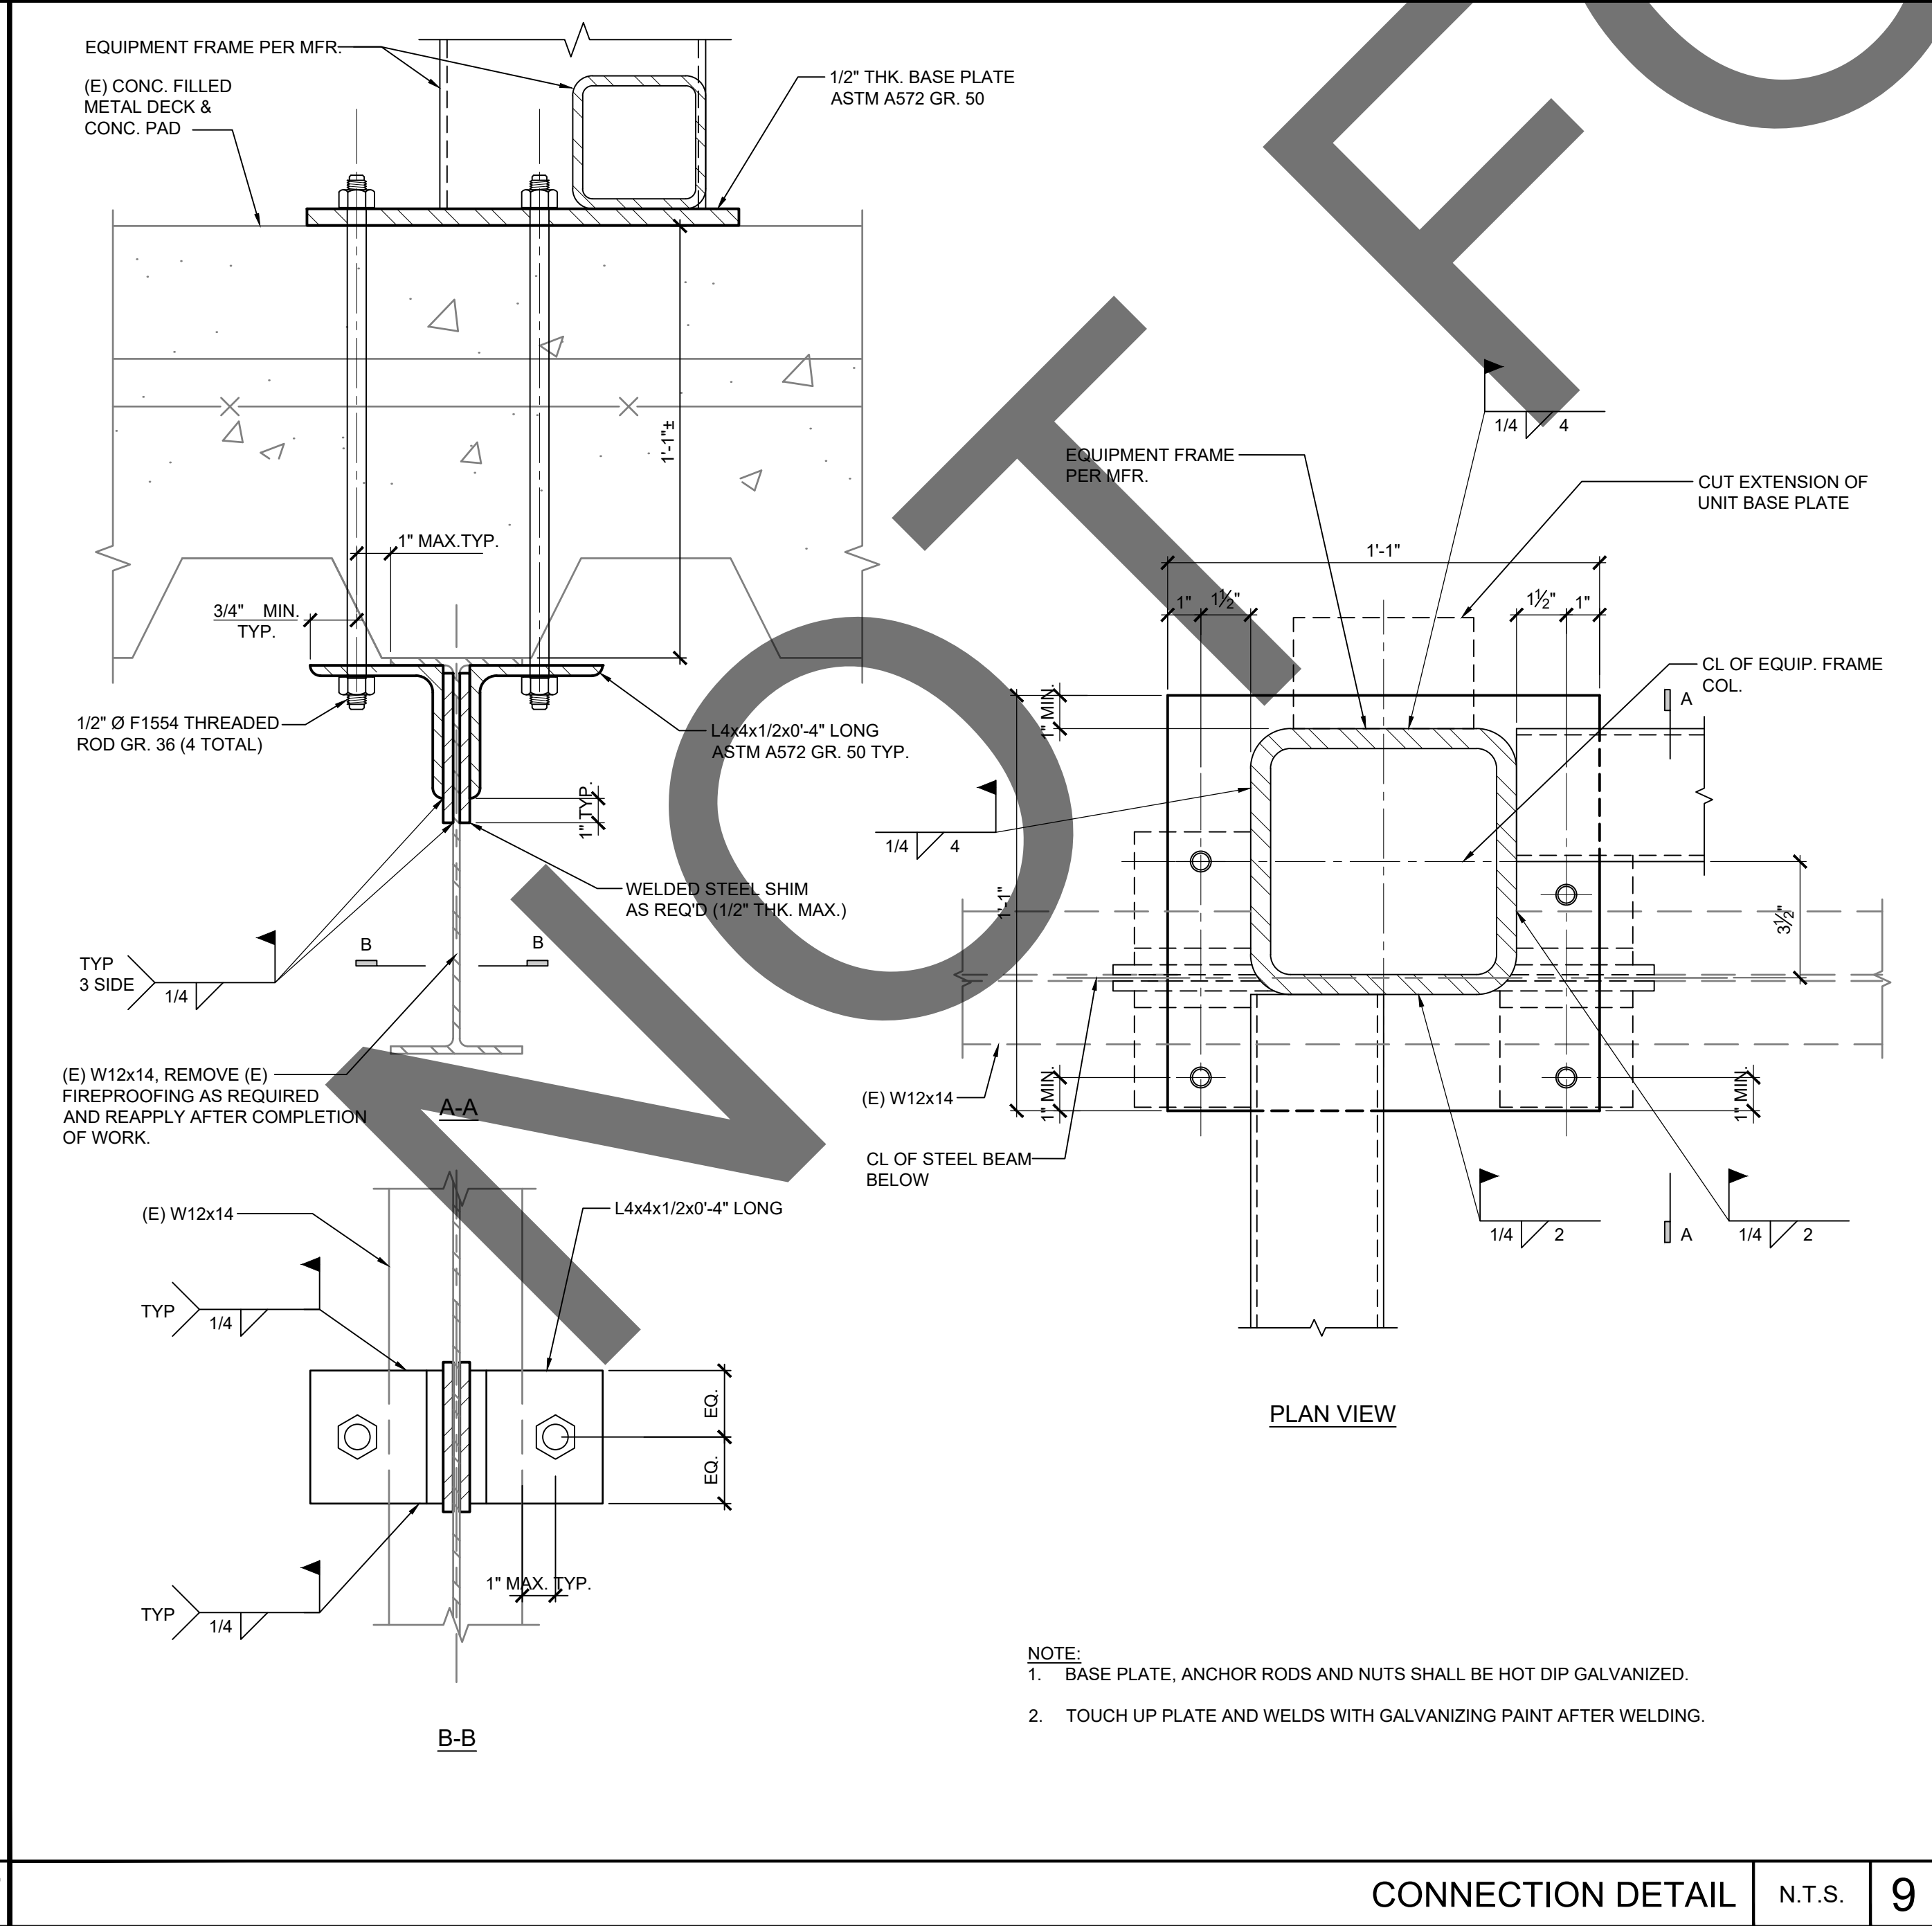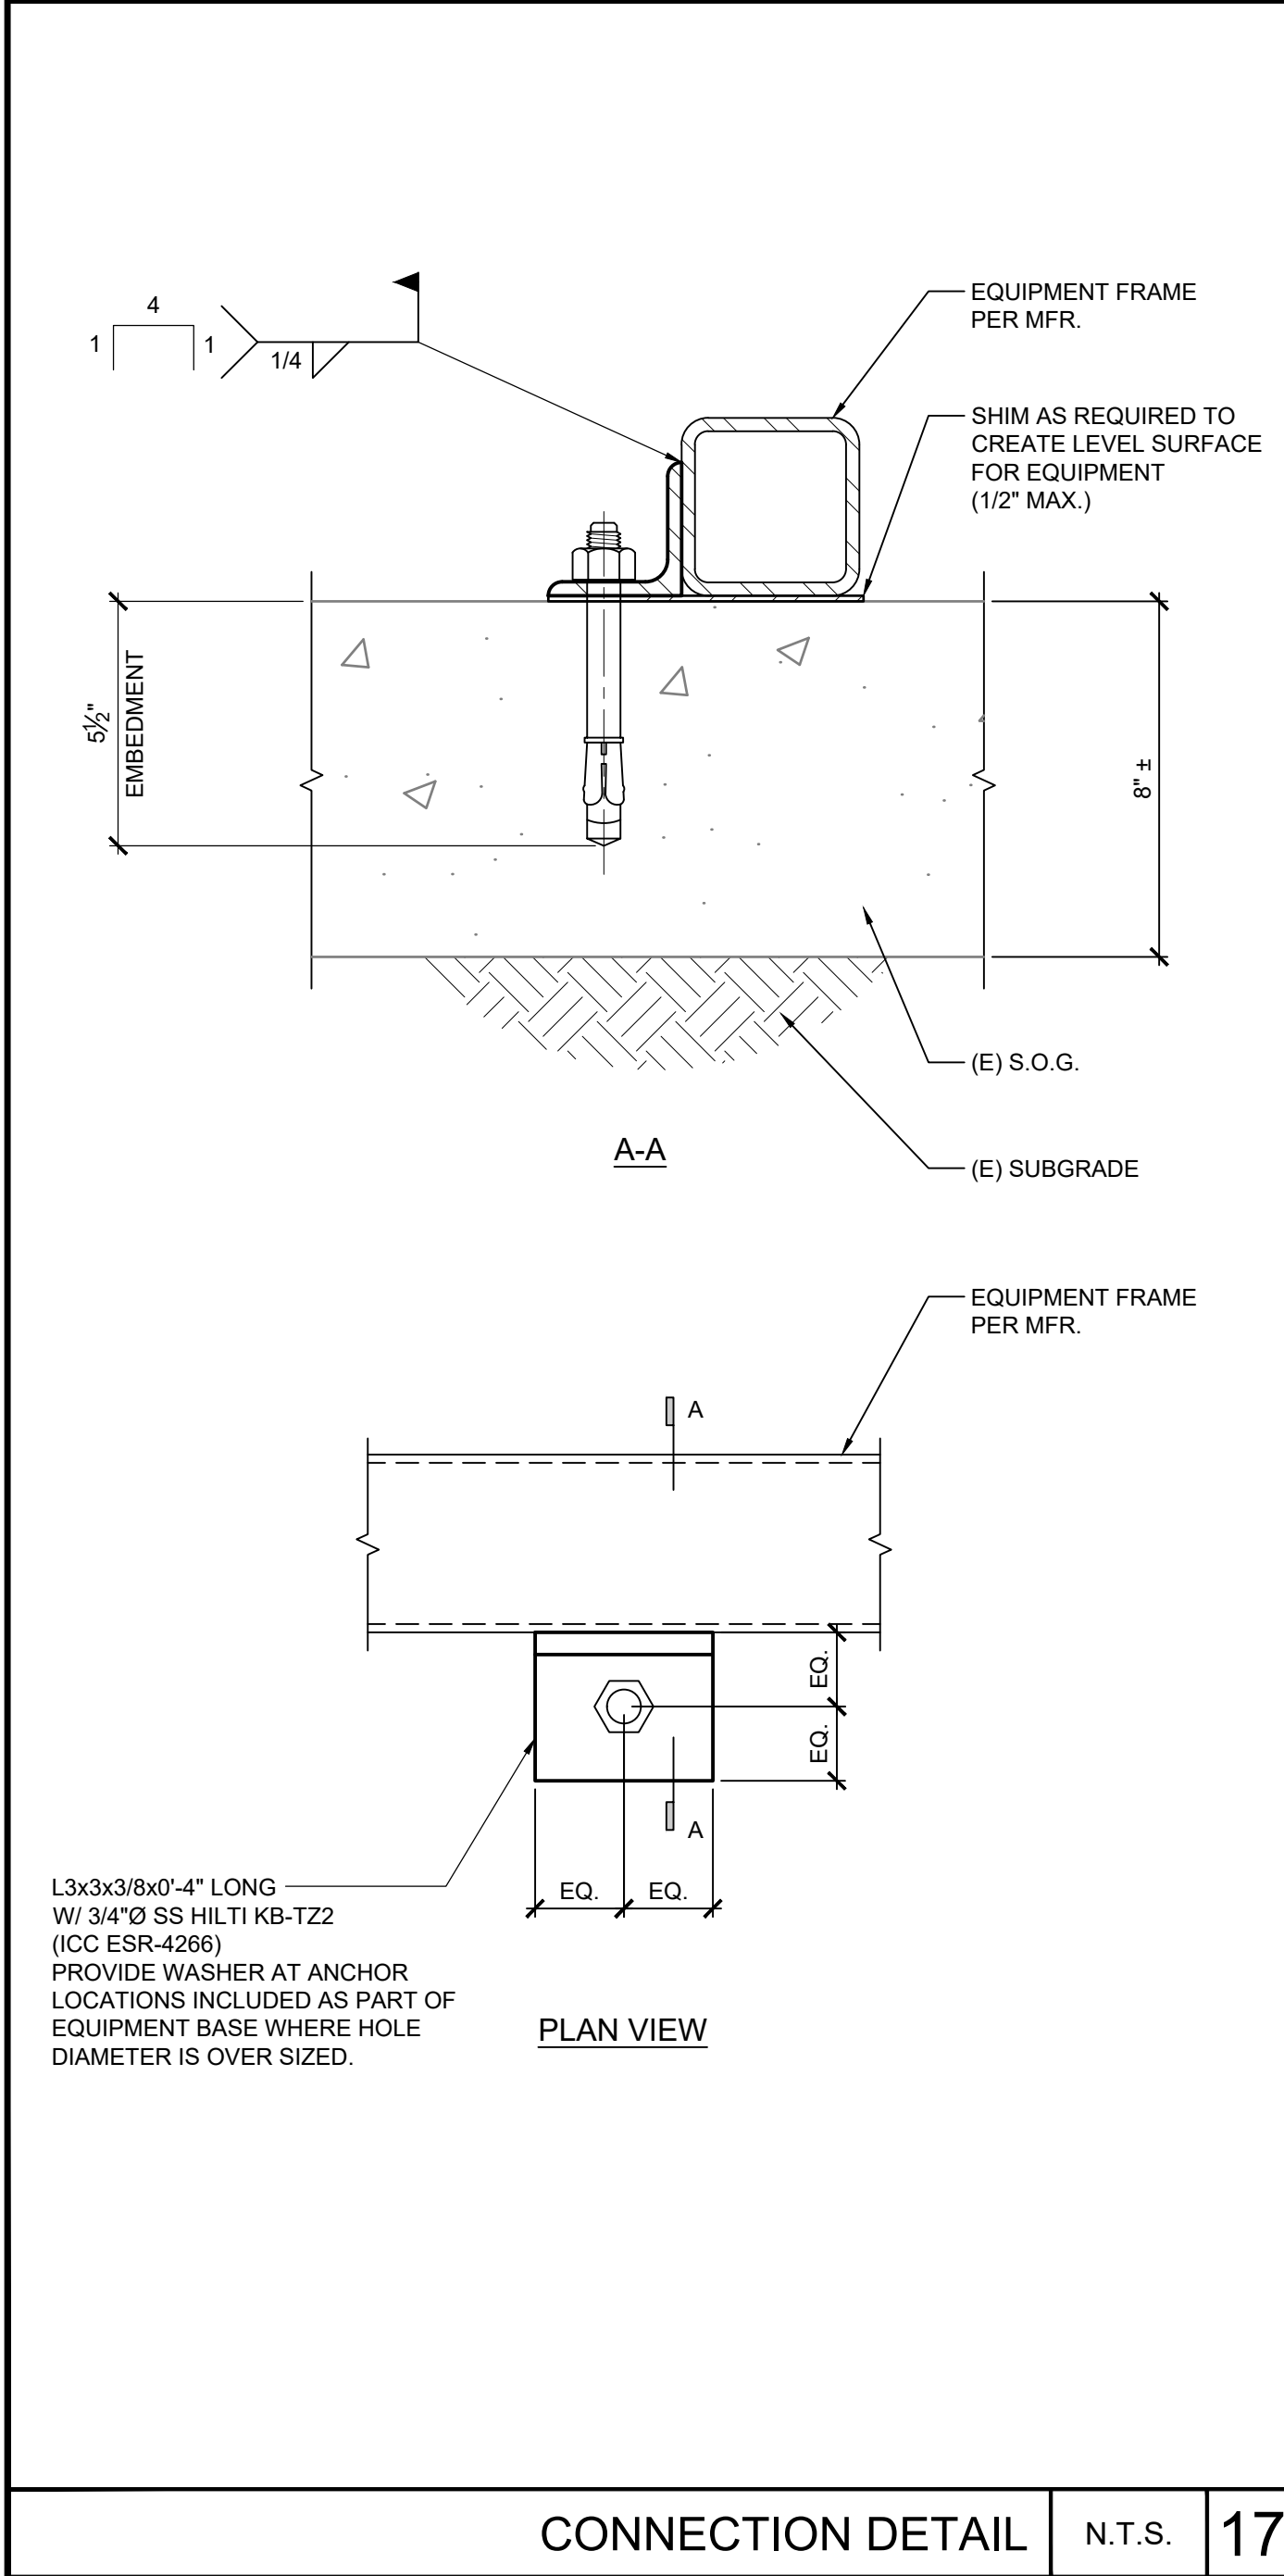

PERMANENT DEAERATOR PLAN 1"=1'-0" 3

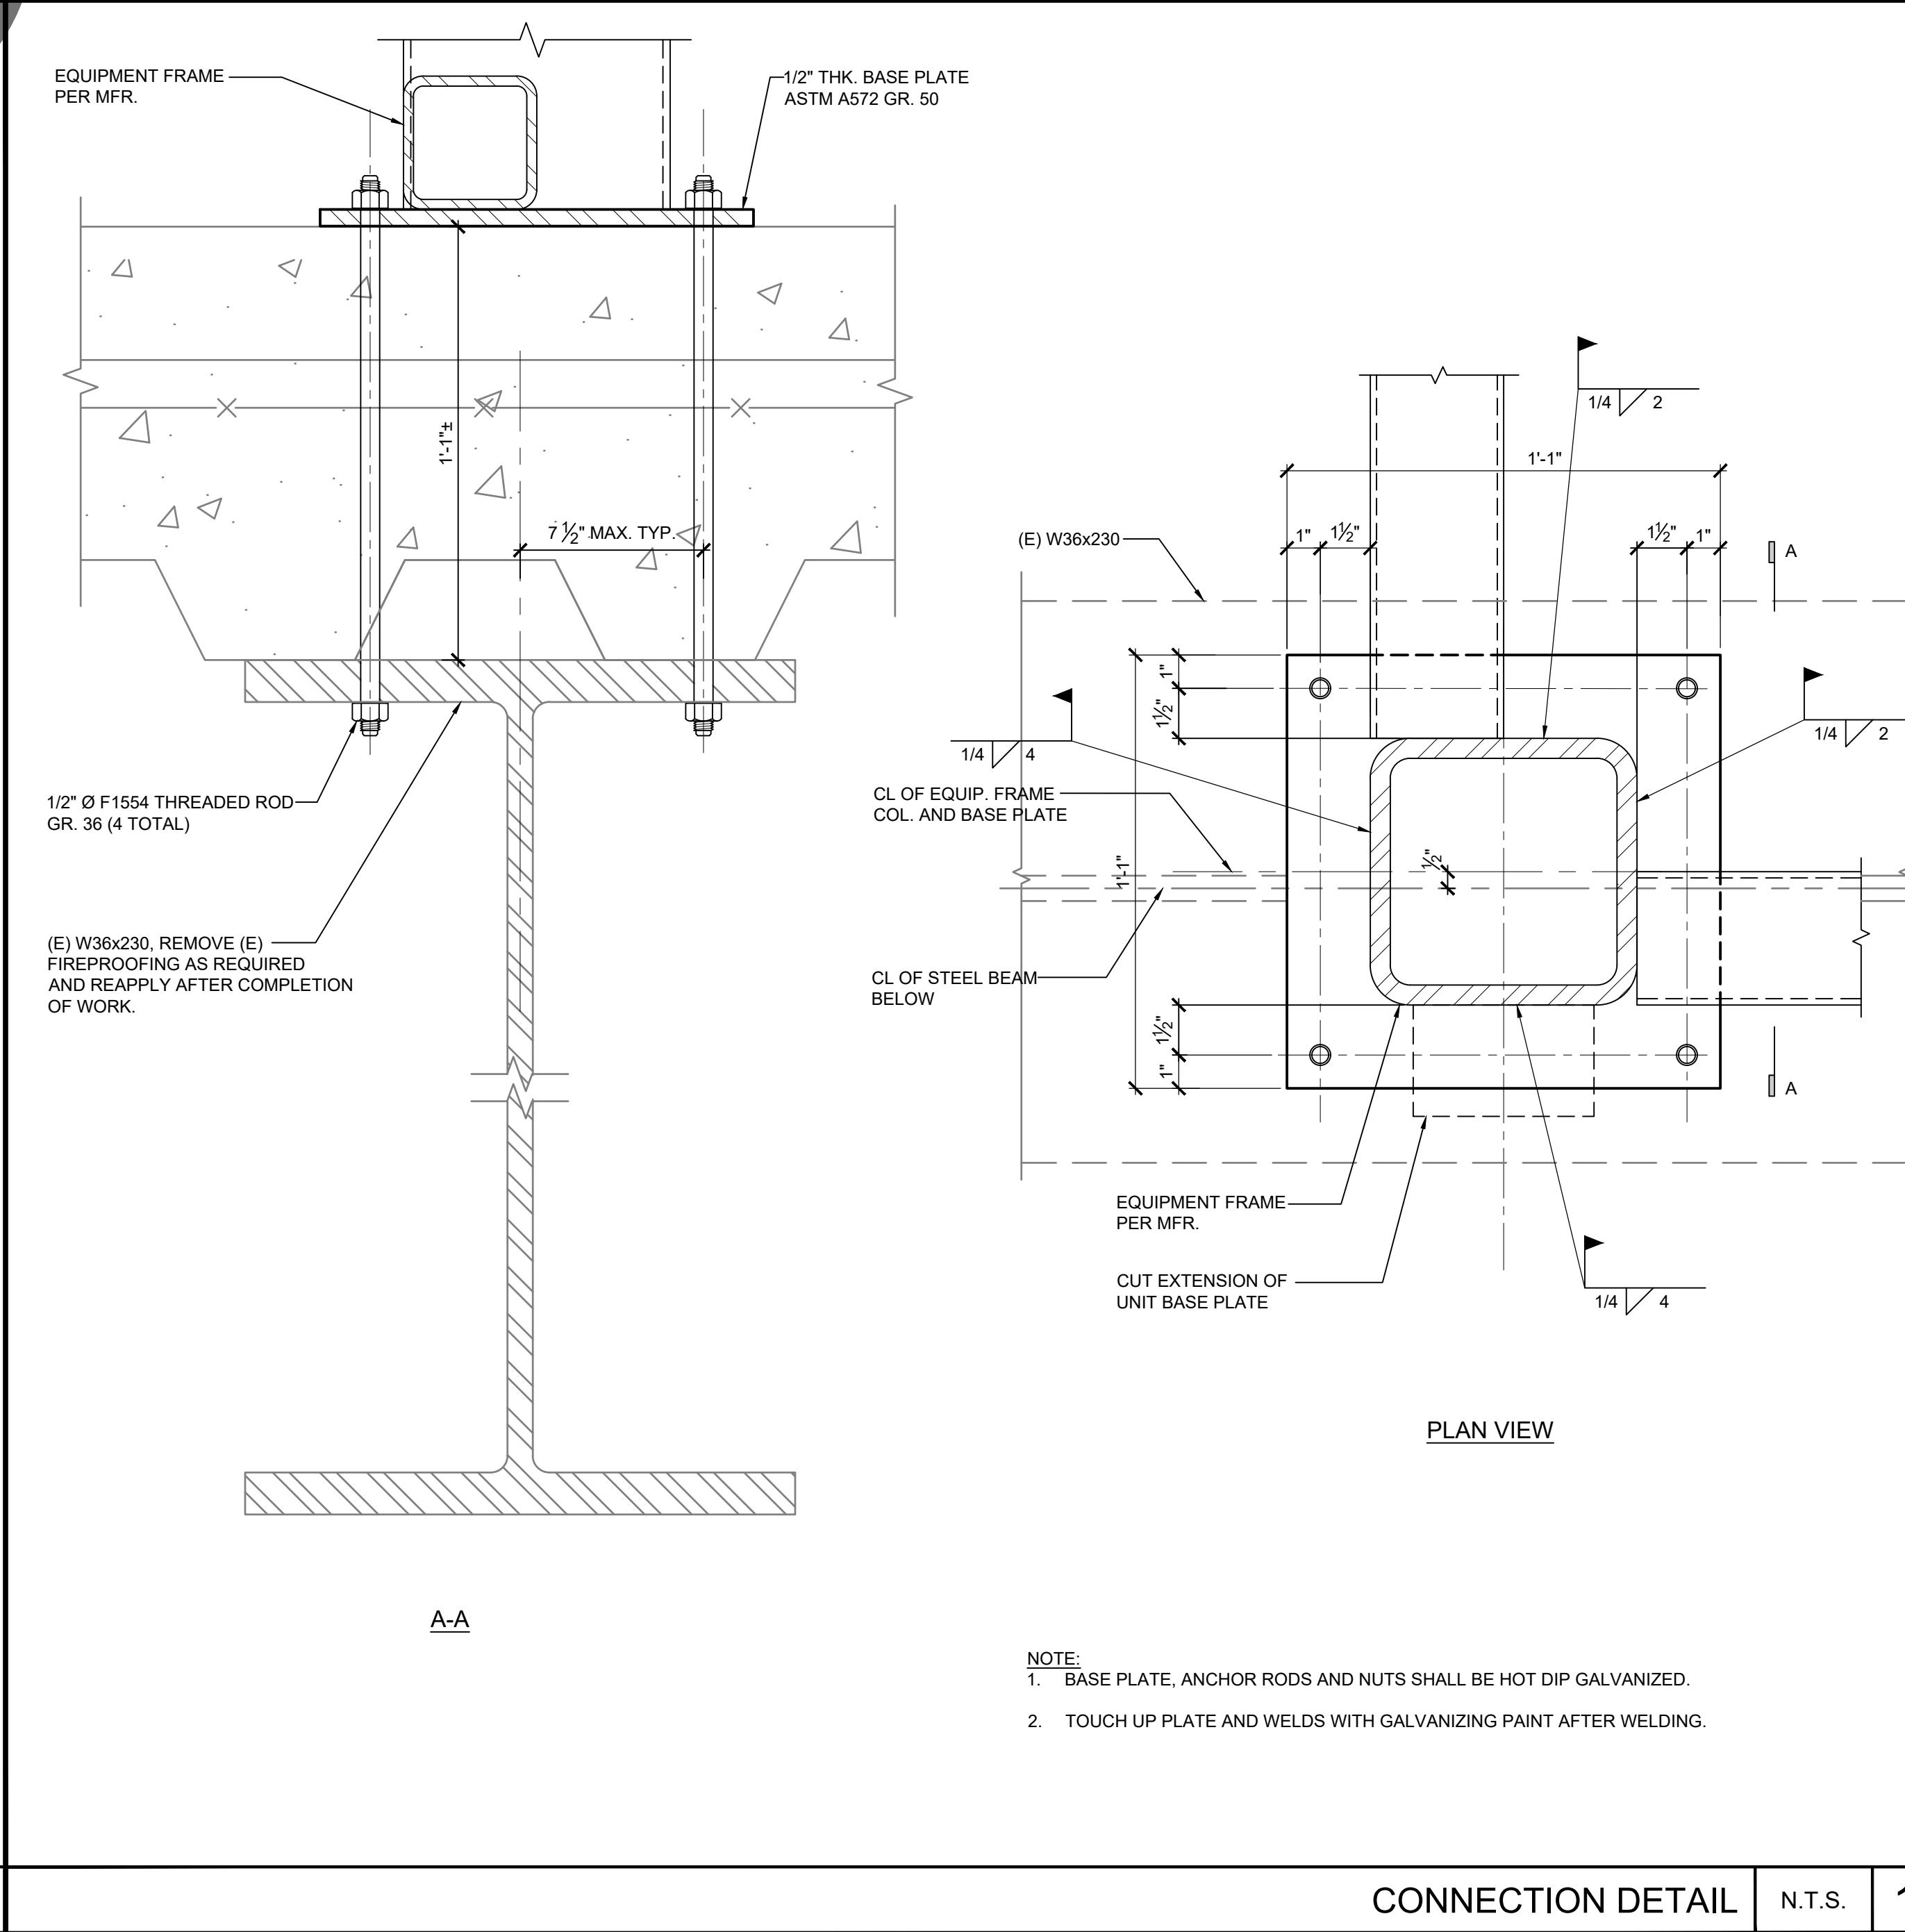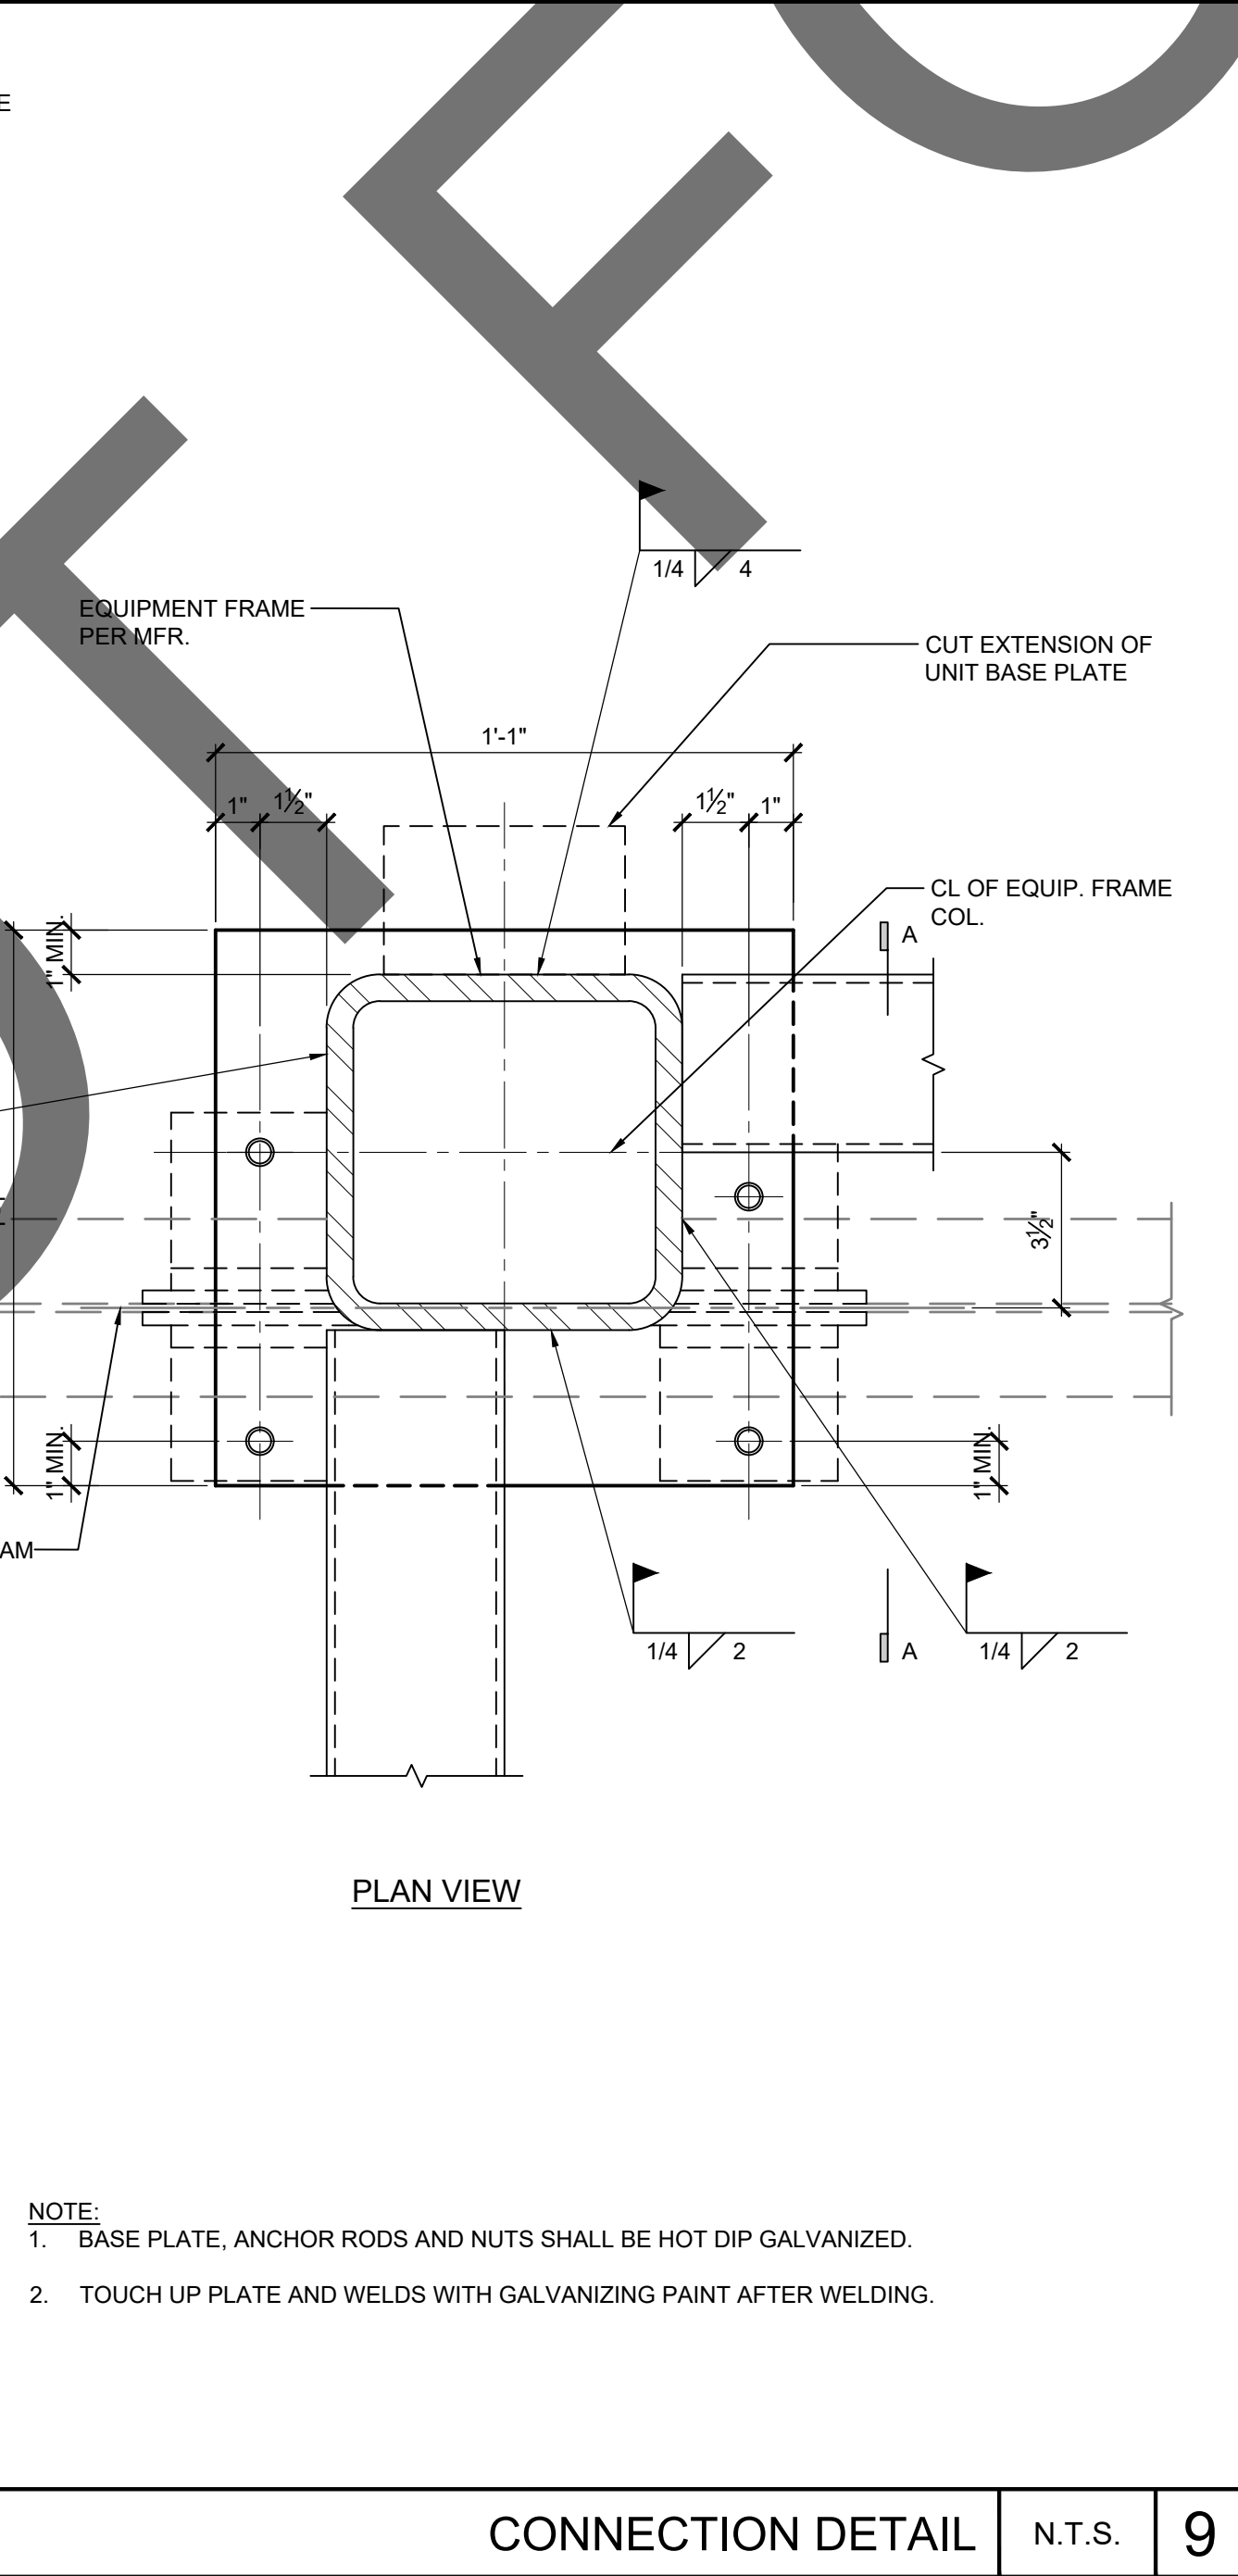

APPROVAL

REVIEWED IN ACCORDANCE WITH THE REQUIREMENTS OF T24, COR

APPROVED

Department of Health Care Access & Information
Office of Statewide Hospital Planning & Development
6/9/2023, 7:23:46 AM
S230562-36-00
Allen Cheng

CLIENT

SAN BERNARDINO COUNTY

SAN BERNARDINO COUNTY
PROJECT AND FACILITIES
MANAGEMENT DEPARTMENT

385 NORTH ARROWHEAD AVENUE, 3RD FLOOR
SAN BERNARDINO, CA 92415-0184

PROJECT NAME

ARMC
DEAERATOR #1
REPLACEMENT

PROJECT NO.
WBSE # 10.10.0847
CIP # 20-011
HCAI # S230562-36-00
FACILITY NO.
17282
BUILDING NO.
BLD-00075 CENTRAL PLANT
400 N. PEPPER AVENUE
COLTON, CA 92324-1801

ENGINEER/ARCHITECT

IDS

IDS GROUP

1 PETERS CANYON ROAD, SUITE 130
IRVINE, CA, 92606
TEL: 949-387-6500, FAX: 949-387-0800

STAMP

REGISTERED PROFESSIONAL ENGINEER
No. 3850
STRUCTURAL
STATE OF CALIFORNIA
DATE SIGNED: 02-17-2023

STAMP

REGISTERED PROFESSIONAL ENGINEER
No. 3850
STRUCTURAL
STATE OF CALIFORNIA
DATE SIGNED: 02-17-2023

ISSUE

REV.	DESCRIPTION	DATE
	HCAI SUBMITTAL	04/28/23
A	BACK CHECK #1	06/16/23
B	BACK CHECK #2	07/28/23

PROJECT IDENTIFICATION

THIS DRAWING WAS CREATED IN AUTODESK AUTOCAD V. 2021 UNLESS OTHERWISE NOTED.

THE ORIGINAL SIZE OF THIS SHEET IS 30" X 42"

THESE DRAWINGS AND SPECIFICATIONS ARE THE PROPERTY AND COPYRIGHT OF IDS GROUP AND SHALL NOT BE USED ON ANY OTHER PROJECT OR LOCATIONS EXCEPT AS DESCRIBED ON THE DRAWINGS, WITHOUT THE WRITTEN AGREEMENT WITH IDS GROUP.

IDS PROJECT NO.

22X066.02

DRAWN BY

XX

CHECKED BY

XX

APPROVED BY

XX

SHEET TITLE

PLANS & DETAILS

SHEET NUMBER

S-500

SHEET NO. 16 OF 29

PLAN CHECK - NOT FOR CONSTRUCTION

HCAI REQUIREMENTS

1. THE INTENT OF THE DRAWINGS IS TO RECONSTRUCT THE HOSPITAL BUILDING IN ACCORDANCE WITH TITLE 24, CALIFORNIA CODE OF REGULATIONS AND THE LIFE SAFETY CODE. SHOULD ANY CONDITIONS DEVELOP NOT COVERED BY THE CONTRACT DOCUMENTS WHEREIN THE FINISHED WORK WILL NOT COMPLY WITH SAID TITLE 24, CALIFORNIA CODE OF REGULATIONS. A CHANGE ORDER DETAILING AND SPECIFYING THE REQUIRED WORK SHALL BE SUBMITTED TO AND APPROVED BY HCAI BEFORE PROCEEDING WITH THE WORK.
2. ALL WORK SHALL BE IN ACCORDANCE WITH THE REQUIREMENTS OF TITLE 22, CALIFORNIA CODE OF REGULATIONS AND TITLE 24—ALL APPLICABLE PARTS OF LATEST EFFECTIVE EDITIONS.
3. ALL ADDENDA AND CHANGE ORDERS SHALL BE SIGNED BY THE ARCHITECT/ENGINEER OF RECORD. APPROVAL TO HCAI (OFFICE OF STATEWIDE HEALTH PLANNING AND DEVELOPMENT), RESPONSIBILITIES OF ARCHITECT/ENGINEER OF RECORD AND CONSULTANTS, PROJECT INSPECTOR, AND GENERAL CONTRACTOR SHALL BE IN ACCORDANCE WITH C.C.R. TITLE 24, PART 1, SECTION 7-141, 7-145, 7-143. VERIFIED REPORTS OF CONSTRUCTION ARE REQUIRED BY C.C.R. TITLE 24, PART 1, SECTION 7-151.
4. NO WORK SHALL COMMENCE AT THE PROJECT SITE BEFORE THE BUILDING PERMIT IS FULLY EXECUTED WITH THE START DATE ENTERED AND SIGNED BY THE OWNER. HCAI AND GENERAL CONTRACTOR AND AVAILABLE FOR POSTING AT JOBSITE.
5. CONSTRUCTION SHALL CONFORM TO ALL GOVERNMENTAL AGENCIES AND CODES HAVING JURISDICTION INCLUDING BUT NOT LIMITED TO:

2022 CALIFORNIA BUILDING CODE (CBC) PART 2, TITLE 24, CCR

2022 CALIFORNIA ELECTRICAL CODE (CEC) PART 3, TITLE 24, CCR

2022 CALIFORNIA MECHANICAL CODE (CMC) PART 4, TITLE 24, (CCR)

2022 CALIFORNIA PLUMBING CODE (CPC) PART 5, TITLE 24, (CCR)

2022 CALIFORNIA FIRE CODE (CFC) PART 9, TITLE 24, (CCR)

GENERAL CONSTRUCTION NOTES

1. PROVIDE SHOP DRAWINGS AND EQUIPMENT SUBMITTALS TO THE COUNTY PROJECT MANAGER FOR REVIEW PRIOR TO BEING SUBMITTED TO THE PROJECT ENGINEER
2. INSTALLATION SHALL CONFORM TO THE REQUIREMENTS OF THE 2022 CALIFORNIA MECHANICAL CODE, 2022 CALIFORNIA BUILDING CODE, AND OTHER APPLICABLE CODES AND REGULATIONS, INCLUDING 2022 CALIFORNIA ENERGY CONSERVATION STANDARDS DIVISION T-24.
3. THE DESIGN DRAWINGS AND PLANS ARE DIAGRAMMATIC IN NATURE. PROVIDE LABOR, MATERIALS, AND INCIDENTALS NECESSARY OR REQUIRED FOR THE INSPECTION, TESTING, ADJUSTMENT AND COMPLETION IN ALL RESPECTS FOR PROPER AND SMOOTH OPERATION OF THE MECHANICAL SYSTEMS.
4. EQUIPMENT SHALL BE INSTALLED IN STRICT ACCORDANCE WITH THE EQUIPMENT MANUFACTURER'S INSTRUCTIONS AND RECOMMENDATIONS. PROVIDE FITTINGS, TRANSITIONS, DAMPERS, VALVES, DEVICES AND MATERIALS REQUIRED FOR A COMPLETE WORKING INSTALLATION.
5. COORDINATE WITH ALL OTHER TRADES THE LOCATIONS OF THERMOSTATS, SENSORS AND OTHER DEVICES PRIOR TO INSTALLATION.
6. MAINTENANCE LABELS SHALL BE AFFIXED TO MECHANICAL EQUIPMENT. PROVIDE OWNER WITH FIVE (5) COPIES OF THE MAINTENANCE AND OPERATING MANUAL AND MANUFACTURERS SUPPLIERS ONE YEAR PARTS AND LABOR WARRANTY FOR ALL INSTALLED EQUIPMENT.
7. PROVIDE CODE-COMPLIANT FIRE/SOUND STOPPING AT DUCT, PIPING, CONDUIT PENETRATIONS THROUGH ALL TYPES OF BUILDING CONSTRUCTION TO ACHIEVE FIRE, SMOKE, AND SOUND RATINGS.
8. EQUIPMENT, DUCTS, PIPING, INSULATION, FLEX CONNECTIONS, CONTROL ITEMS, AND OTHER DEVICES AND MATERIALS INSTALLED OUTSIDE OF THE BUILDING OR OTHERWISE EXPOSED TO THE WEATHER SHALL BE WEATHERPROOFED.
9. HVAC EQUIPMENT SHALL BE CERTIFIED BY THE CALIFORNIA ENERGY COMMISSION TO COMPLY WITH EFFICIENCY STANDARDS PER TITLE 24, PART 6, SECTIONS 111 AND 112.
10. POLLUTANT CONTROL: AT THE TIME OF ROUGH INSTALLATION AND DURING STORAGE ON THE CONSTRUCTION SITE UNTIL FINAL STARTUP OF THE HEATING, COOLING, AND VENTILATING EQUIPMENT, DUCT AND OTHER RELATED AIR DISTRIBUTION COMPONENT OPENINGS SHALL BE COVERED WITH TAPE, PLASTIC, SHEET METAL OR OTHER METHODS ACCEPTABLE TO THE ENFORCING AGENCY TO REDUCE THE AMOUNT OF DUST, WATER, AND DEBRIS WHICH MAY ENTER THE SYSTEM.
11. BALANCING AND ADJUSTING: SYSTEM START-UP, BALANCING, TESTING AND ADJUSTING OF THE AFFECTED PORTIONS OF THE MECHANICAL SYSTEM SHALL BE THE RESPONSIBILITY OF AN INDEPENDENT THIRD PARTY APPROVED TESTING AND BALANCING CONTRACTOR. TESTING AND BALANCING CONTRACTOR SHALL BE AN AABC OR NEBB MEMBER. TEST AND BALANCE CONTRACTOR SHALL OBTAIN, COMPLY, FILL OUT, AND SUBMIT TO THE COMMISSIONING AGENT COPIES OF THE CERTIFICATE OF COMPLIANCE AND REQUIRED ACCEPTANCE TEST FORMS AND ALL OTHER PROCESS COMPLIANCE FORMS AND WORKSHEETS REQUIRED BY THIS PROJECT. THE PUMPS SHALL BE BALANCED TO WITHIN 10% OF THE LISTED QUANTITIES, AND WATER SYSTEM EQUIPMENT SHALL BE BALANCED TO WITHIN 5% OF THE LISTED QUANTITIES. THE COST OF THE INDEPENDENT TESTING AND BALANCING CONTRACTOR SHALL BE INCLUDED IN THE MECHANICAL CONTRACTOR BID.
12. UPON COMPLETION OF TESTING, OPERATE EQUIPMENT TO VERIFY THAT SYSTEMS FUNCTION PROPERLY. AFTER VERIFYING THE PROPER OPERATION, DEMONSTRATE THE OPERATION OF SYSTEMS AND EQUIPMENT TO THE OWNER'S REPRESENTATIVES. PROVIDE ONE WEEK NOTICE AND SCHEDULE THE DEMONSTRATION WITH THE OWNER.
13. ALL WORK SHALL BE GUARANTEED TO BE FREE FROM DEFECTS IN MATERIAL AND WORKMANSHIP FOR A PERIOD OF ONE YEAR FROM DATE OF FINAL ACCEPTANCE OF THE WORK. REPLACE OR REPAIR DEFECTIVE MATERIALS OR REPAIR DEFECTIVE WORK AT NO ADDITIONAL COST.
14. PIPE LABELING:

• CHILLED WATER (CHW): GREEN BACKGROUND COLOR WITH WHITE LETTERS.

• CONDENSER WATER (CW): GREEN BACKGROUND COLOR WITH WHITE LETTERS.
16. VALVE TAGS: VALVE TAGS SHALL BE OF BRASS MATERIAL AND TYPE. SERVICE AND TAG LETTERING AS FOLLOWS:

• CHILLED WATER: CHW

• CONDENSER WATER: CW

• REFRIGERANT: REF
17. EQUIPMENT LABELING: EQUIPMENT LABEL SHALL BE BRASS OR ANODIZED ALUMINUM, 0.032-INCH MINIMUM THICKNESS. LENGTH AND WIDTH VARY FOR REQUIRED LABEL CONTENT, BUT NOT LESS THAN 2-1/2 BY 3/4 INCH. LETTER SIZE SHALL BE MINIMUM 1/4 INCH IF VIEWING DISTANCE IS LESS THAN 24 INCHES, 1/2 INCH IF VIEWING DISTANCE IS UP TO 72 INCHES AND PROPORTIONALLY LARGER LETTERING FOR GREATER VIEWING DISTANCE.

LEGEND & ABBREVIATIONS

SYMBOL	ABBR.	DESCRIPTION	SYMBOL	ABBR.	DESCRIPTION
		EQUIPMENT DESIGNATION & NUMBER		B.O.P	BOTTOM OF PIPE
		ROOM THERMOSTAT		S.S	STAINLESS STEEL
		SMOKE DETECTOR		AC	AIR CONDITIONING UNIT
	P.O.C.	POINT OF CONNECTION		AP	ACCESS PANEL
	P.O.D.	POINT OF DISCONNECT		B.D.D.	BACK DRAFT DAMPER
		UNDERCUT DOOR		CB	CIRCUIT BREAKER
		DOOR LOUVER		CP	CONTROL PANEL
		NOTE DESIGNATION		CFM	CUBIC FEET PER MINUTE
		MOTORIZED DAMPER OR VALVE ACTUATOR		CONC.	CONCRETE
	BDD	BACKDRAFT DAMPER		COND.	CONDENSATE
		PIPE UNION		D	DRAIN
	HWS	HOT WATER SUPPLY		D.B	DRY BULB
	HWR	HOT WATER RETURN		DN.	DOWN
		REDUCER		ENT.	ENTERING
		CONDENSATE DRAIN, DRAIN		EF	EXHAUST FAN
		FLOW INDICATOR, FLOW METER		E.S.P.	EXTERNAL STATIC PRESSURE (INCHES OF WATER)
		FLEXIBLE PIPE CONNECTOR		TYP.	TYPICAL
	GV	GATE VALVE		A.F.F	ABOVE FINISHED FLOOR
		BALANCING VALVE		FLA	FULL LOAD AMPS
		PLUG VALVE		FT.	FEET
		CHECK VALVE		GC	GENERAL CONTRACTOR
	PRV, T&PRV	PRESSURE RELIEF VALVE, TEMPERATURE & PRESSURE RELIEF VALVE		HP	HORSEPOWER
	AAV	AUTOMATIC AIR VENT		BHP	BRAKE HORSEPOWER
	BV	BALL VALVE		IN.	INCHES
	BFV	BUTTERFLY VALVE		KW	KILOWATTS
	IV	ACTUATED BUTTERFLY VALVE		L.R.A.	LOCKED ROTOR AMPS
	P.G. OR P.I.	PRESSURE GAGE, PRESSURE INDICATOR		M.C.A.	MINIMUM CIRCUIT AMPS
	T.G. OR T.I.	THERMOMETER, TEMPERATURE INDICATOR		R.L.A.	RATED LOAD AMPS
	CV	2-WAY CONTROL VALVE		M.O.C.P.	MAX. OVER CURRENT PROTEC. AMPS
		3-WAY CONTROL VALVE		PH	PHASE
		PRESSURE REDUCING VALVE		FD	FUSED DISCONNECT
	BF	BLIND FLANGE		NFD	NON FUSED DISCONNECT
	T/P	TEMPERATURE/PRESSURE TEST PORT		PRESS.	PRESSURE
		STRAINER		RPM	REVOLUTIONS PER MINUTE
		STRAINER WITH BLOW DOWN VALVE		MIN.	MINIMUM
		VALVE IN VERTICAL PIPE		B.O.D.	BOTTOM OF SHEET METAL DUCT
	CWS	CONDENSER WATER SUPPLY		A.F.F.	ABOVE FINISHED FLOOR
	CWR	CONDENSER WATER RETURN		UTR	UP THRU ROOF
	CHWS	CHILLED WATER SUPPLY		DTR	DOWN THRU ROOF
	CHWR	CHILLED WATER RETURN		U.N.O.	UNLESS NOTED OTHERWISE
		EXISTING DUCT/PIPING		O.C.	ON CENTER
		EXISTING DUCT/PIPING TO BE REMOVED		TEMP	TEMPORARY
		EXISTING EQUIPMENT TO BE REMOVED		SCV	SILENT CHECK VALVE
	FM	FLOW METER			

MECHANICAL SHEET INDEX

S.NO.	SHEET #	SHEET TITLE	SCALE
1	M-001	MECHANICAL NOTES LEGEND AND ABBREVIATIONS	NO SCALE
2	M-002	MECHANICAL SPECIFICATIONS	NO SCALE
3	M-101	MECHANICAL FLOOR PLAN TEMPORARY WORK	1/4"=1'-0"
4	M-102	MECHANICAL FLOOR PLAN DEMOLITION	1/4"=1'-0"
5	M-201	MECHANICAL FLOOR PLAN	1/4"=1'-0"
6	M-501	MECHANICAL DETAILS	NO SCALE

SEISMIC BRACING NOTES

- A. PROVIDE SEISMIC BRACING OF MECHANICAL, PLUMBING AND FIRE PROTECTION SYSTEMS IN ACCORDANCE WITH REQUIREMENTS OF THE CURRENT CALIFORNIA BUILDING CODE IMPORTANCE FACTOR OF 1.5.
- B. DUCTWORK AND PIPING SHALL BE SUPPORTED AND BRACED WITH ONE OF THE FOLLOWING HCAI PRE-APPROVED SYSTEMS:

1. MASON SEISMIC RESTRAINT COMPONENTS FOR SUSPENDED UTILITIES. HCAI PRE-APPROVAL OPM-0043-13.

2. B-LINE / TOLCO OPM-0052.
- C. CALCULATIONS AND DRAWINGS SHALL BE SUBMITTED FOR DUCTWORK, PIPING AND SUPPORTS AND BRACING SHOWING:

1. LOCATION OF SEISMIC BRACING.

2. REACTION FORCES TO THE SUPPORTING STRUCTURE.

3. MANUFACTURER'S DESIGNATION OF SUPPORT DEVICES.
- CALCULATION SHALL INCLUDE REFERENCES TO THE MANUFACTURER'S LITERATURE FOR ALLOWABLE LOADS ON THE DEVICES. CALCULATIONS AND DRAWINGS SHALL BE APPROVED, STAMPED, AND SIGNED BY A LICENSED CALIFORNIA ENGINEER PRIOR TO SUBMITTING THEM FOR REVIEW TO THE MECHANICAL, STRUCTURAL ENGINEER OF RECORD AND TO HCAI.
- D. SEISMIC BRACING POINTS SHALL BE SUBMITTED ON CONTRACTOR'S COORDINATED SHOP DRAWINGS.
- E. ANCHORAGE OF ALL EQUIPMENT SHALL BE DETAILED EXCEPT FOR:

IF THERE ARE THE EQUIPMENTS FOR THIS PROJECT THAT WEIGH EQUAL OR LESS THAN 400 LBS AND HAS A CENTER OF MASS LOCATED LESS THAN 4FT, THEN PROVIDE SUPPORT AND ATTACHMENT DETAILS ON THE DRAWINGS. CALCULATIONS NEED NOT BE PROVIDED FOR HCAI REVIEW. FURNITURE OR TEMPORARY OR MOVABLE EQUIPMENT AND EQUIPMENT WEIGHING LESS THAN 20 LBS THAT IS SUPPORTED AND ANCHORED TO RESIST THE FORCES PRESCRIBED IN CHAPTER 13 OF ASCE 7-16, 2022 CBC AND THE ANCHORAGE SHALL BE APPROVED BY THE STRUCTURAL ENGINEER OF RECORD AND OSHPD AS PART OF FIELD REVIEWS/ INSPECTIONS. THE INSPECTOR OF RECORD SHALL BE ASSURE THAT THE ABOVE REQUIREMENTS ARE ENFORCED.
- F. SPACING, SUPPORT AND BRACING OF MECHANICAL & FIRE SPRINKLER PIPING SHALL COMPLY WITH THE 2019 EDITION OF NFPA 13 AND CHAPTER 13 OF ASCE 7, 2022 CBC.
- G. A COPY OF CHOSEN BRACING SYSTEM(S) INSTALLATION GUIDE/ MANUAL SHALL BE ON THE JOBSITE PRIOR TO STARTING THE INSTALLATION OF THE COMPONENT, EQUIPMENT HANGERS AND/ OR BRACES.
- H. MECHANICAL CONTRACTOR TO PROVIDE DUCT, PIPING SUPPORT SHOP DRAWINGS FOR STRUCTURAL ENGINEER TO REVIEW.
- I. ALL DUCTS SHALL HAVE A MINIMUM TWO TRANSVERSE AND ONE LONGITUDINAL BRACING IN EACH RUN.

APPLICABLE CODES & STANDARDS

2022 CALIFORNIA ADMINISTRATIVE CODE, PART 1, TITLE 24 C.C.R. *
2022 CALIFORNIA BUILDING CODE (CBC), PART 2, TITLE 24 C.C.R.
2022 CALIFORNIA ELECTRICAL CODE (CEC), PART 3, TITLE 24 C.C.R.
2022 CALIFORNIA MECHANICAL CODE (CMC) PART 4, TITLE 24 C.C.R.
2022 CALIFORNIA PLUMBING CODE (CPC), PART 5, TITLE 24 C.C.R.
2022 CALIFORNIA ENERGY CODE (CEC), PART 6, TITLE 24 C.C.R.
2022 CALIFORNIA FIRE CODE, PART 9, TITLE 24 C.C.R.
2022 CALIFORNIA GREEN BUILDING STANDARDS CODE, PART 11, TITLE 24 C.C.R.
2022 CALIFORNIA REFERENCED STANDARDS, PART 12, TITLE 24 C.C.R.
NFPA NATIONAL FIRE PROTECTION ASSOCIATION, SECTION 96
UL UNDERWRITERS LABORATORIES, INC.
ASTM AMERICAN SOCIETY FOR TESTING AND MATERIALS
ANSI AMERICAN NATIONAL STANDARDS INSTITUTE
NEMA NATIONAL ELECTRICAL MANUFACTURER'S ASSOCIATION
ADA AMERICANS WITH DISABILITIES ACT
OSHA OCCUPATIONAL SAFETY AND HEALTH ADMINISTRATION
EPA ENVIRONMENTAL PROTECTION AGENCY

*CALIFORNIA ADMINISTRATIVE CODE, PART 1, CHAPTER 10, ADMINISTRATIVE REGULATIONS FOR THE CALIFORNIA ENERGY COMMISSION (CEC).

INSULATION NOTES

PIPING INSULATION SHALL BE AS PER CALIFORNIA ENERGY CODE TABLE 120.3-A

TABLE 120.3-A PIPE INSULATION THICKNESS									
FLUID TEMPERATURE RANGE (°F)	CONDUCTIVITY RANGE (IN BTU-INCH PER HOUR PER SQUARE FOOT PER °F)	INSULATION MEAN RATING TEMPERATURE (°F)	NOMINAL PIPE DIAMETER (IN INCHES)					INSULATION THICKNESS REQUIRED (IN INCHES)	
			<1	1	1.5	4	8		
			TO	TO	TO	TO	AND		
			1	<1.5	<4	<8	LARGER		
INSULATION THICKNESS REQUIRED (IN INCHES)									
SPACE HEATING, HOT WATER (STEAM, STEAM CONDENSATE & HOT WATER) & SERVICE WATER HEATING SYSTEM									
ABOVE 350	0.32 - 0.34	250	4.5	5.0	5.0	5.0	5.0		
251 - 350	0.29 - 0.31	200	3.0	4.0	4.5	4.5	4.5		
201 - 250	0.27 - 0.30	150	2.5	2.5	2.5	3.0	3.0		
141 - 200	0.25 - 0.29	125	1.5	1.5	2.0	2.0	2.0		
105 - 140	0.22 - 0.28	100	1.0	1.5	1.5	1.5	1.5		
SPACE COOLING SYSTEMS (CHILLED WATER, HVAC CONDENSATE, REFRIGERANT AND BRINE)									
40 - 60	0.21 - 0.27	75	0.5	0.75	1.0	1.0	1.0		
BELOW 40	0.20 - 0.26	50	1.0	1.5	1.5	1.5	1.5		

PIPE MATERIAL SCHEDULE

SERVICES	APPLICATION	MATERIAL	REMARKS
STEAM CONDENSATE RETURN/ BOILER FEEDWATER	ALL SIZES	SCHEDULE 80 CARBON STEEL PIPE	JOINING METHOD OPTIONS INCLUDE WELDING, OR FLANGED, 3" THICK PRE-FORMED RIGID FIBERGLASS INSULATION COVER INSULATION WITH CORRUGATED ALUMINUM JACKET
HIGH PRESSURE STEAM	ALL SIZES	SCHEDULE 40 CARBON STEEL PIPE	JOINING METHOD OPTIONS INCLUDE WELDING, OR FLANGED, 3" THICK PRE-FORMED RIGID FIBERGLASS INSULATION COVER INSULATION WITH CORRUGATED ALUMINUM JACKET
MAKE UP WATER	ALL SIZES	STANDARD CARBON STEEL PIPE	JOINING METHOD OPTIONS INCLUDE WELDING, FLANGED OR MECHANICAL COUPLINGS.
TEMPORARY PIPING	ALL SIZES	SAME AS ABOVE OR APPROVED FLEXIBLE TEMPORARY HOSE	.

- NOTES:
1. INSULATION CONDUCTIVITY PER CEC 2022 SHALL BE DETERMINED IN ACCORDANCE WITH ASTM C335 AT THE MEAN TEMPERATURE LISTED IN TABLE 120.3-A, AND SHALL BE ROUNDED TO THE NEAREST 1/100 BTU-INCH PER HOUR PER SQUARE FOOT PER °F. FLUID DISTRIBUTION SYSTEMS INCLUDE ALL ELEMENTS THAT ARE IN SERIES WITH THE FLUID FLOW, SUCH AS PIPES, PUMPS, VALVES, STRAINERS, COIL U-BENDS, AND AIR SEPARATORS, BUT NOT INCLUDING ELEMENTS THAT ARE NOT IN SERIES WITH THE FLUID FLOW, SUCH AS EXPANSION TANKS, FILL LINES, CHEMICAL FEEDERS, AND DRAINS.
2. PIPE INSULATION SHALL BE PROTECTED FROM DAMAGE, DUE TO SUNLIGHT, MOISTURE, EQUIPMENT MAINTENANCE, AND WIND. PROTECTION SHALL, AT MINIMUM, INCLUDE THE FOLLOWING:

A. PIPE INSULATION EXPOSED TO WEATHER SHALL BE PROTECTED BY A COVER SUITABLE FOR OUTDOOR SERVICE. THE COVER SHALL BE WATER RETARDANT AND PROVIDE SHIELDING FROM SOLAR RADIATION THAT CAN CAUSE DEGRADATION OF THE MATERIAL. ADHESIVE TAPE SHALL NOT BE USED TO PROVIDE THIS PROTECTION.

B. PIPE INSULATION COVERING CHILLED WATER PIPING AND REFRIGERANT SUCTION PIPING LOCATED OUTSIDE THE CONDITIONED SPACE SHALL INCLUDE, OR BE PROTECTED BY, A CLASS I OR CLASS II VAPOR RETARDER. ALL PENETRATIONS AND JOINTS SHALL BE SEALED.

C. PIPE INSULATION BURIED BELOW GRADE MUST BE INSTALLED IN A WATER PROOF AND NON-CRUSHABLE CASING OR SLEEVE.
3. HYDRONIC PIPING INSTALLATION SHALL COMPLY WITH CHAPTER 12 PART 1 OF THE CMC 2022.

DEAERATOR/SURGE TANK AND PUMP SCHEDULE

TAG	STATUS	MAKE	MODEL	TYPE	LOCATION	SERVICE	CAPACITY		PUMPS										ELECTRICAL		PHYSICAL					ANCHORAGE DETAIL	COMMENTS
							SURGE TANK (GAL.)	DEAERATOR TANK (GAL.)	SURGE					BOILER FEED					V	PH	L	W	H	WEIGHT			
									QTY.	GPM	FT	RPM	HP	QTY.	GPM	FT	RPM	HP									
DA/ST 1	NEW	CLEAVER BROOKS	SD 70-1400-1800	COMBINATION DEAERATOR & SURGE TANK	CENTRAL PLANT	STEAM BOILERS	1800	1400	2	182	90	3500	20	4	79	438	3500	20	460	3	239"	99"	205"	32,900	3/S-500		
TEMP 1	TEMPORARY	CLEAVER BROOKS	SMP-45-900	DEAERATOR TANK	CENTRAL PLANT	STEAM BOILERS	-	900	-	-	-	-	-	2	63 81	438 438	3450 3450	15 15	460	3	133"	71"	177"	10,800	15/S-500		

APPROVAL



CLIENT



PROJECT NAME

**ARMC
DEAERATOR #1
REPLACEMENT**


PROJECT NO.
WBSE # 10.10.0847
CIP # 20-011
HCAI # S20X062-36-00

FACILITY NO.
17282

BUILDING NO.
BLD-00075 CENTRAL PLANT

400 N. PEPPER AVENUE
COLTON, CA 92324-1801

ENGINEER/ARCHITECT

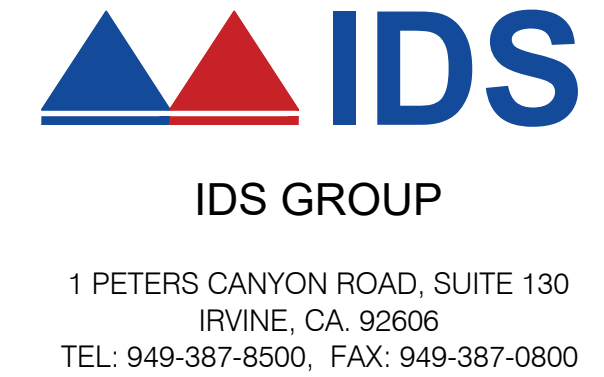

STAMP



STAMP

ISSUE

REV.	DESCRIPTION	DATE
	HCAI SUBMITTAL	04/28/23
A	BACK CHECK #1	06/16/23
B	BACK CHECK #2	07/28/23

PROJECT IDENTIFICATION

THIS DRAWING WAS CREATED IN AUTODESK AUTOCAD V. 2021 UNLESS OTHERWISE NOTED.

THE ORIGINAL SIZE OF THIS SHEET IS 30" X 42"

THESE DRAWINGS AND SPECIFICATIONS ARE THE PROPERTY AND COPYRIGHT OF IDS GROUP AND SHALL NOT BE USED ON ANY OTHER PROJECT OR LOCATIONS EXCEPT AS DESCRIBED ON THE DRAWINGS, WITHOUT THE WRITTEN AGREEMENT WITH IDS GROUP.

IDS PROJECT NO. 22X066.02

DRAWN BY AZ

CHECKED BY AZ

APPROVED BY DS

SHEET TITLE

**MECHANICAL NOTES
LEGEND AND
ABBREVIATIONS**

SHEET NUMBER

M-001

SHEET NO. 001 OF 005

GENERAL

- PLANS ARE DIAGRAMMATIC. DO NOT SCALE FOR MATERIAL QUANTITIES. ALL SCALING SHOULD BE REFERENCED TO ARCHITECTURAL PLANS ONLY.
- CONTRACTOR SHALL OBTAIN AND PAY FOR ALL REQUIRED FEES, PERMITS AND INSPECTIONS. OBTAIN ALL FIELD APPROVALS ON WORK FROM REGULATING AGENCIES WHERE REQUIRED.
- COORDINATE ALL WORK WITH VARIOUS TRADES IN INSTALLING ALL WORK TO CLEAR ARCHITECTURAL AND STRUCTURAL MEMBERS. NO WORK SUCH AS PIPE, DUCT, ETC., TO BE IN CONTACT WITH ANY EQUIPMENT.
- COORDINATE ALL CUTTING AND PATCHING WITH GENERAL CONTRACTOR AND OTHER DISCIPLINES. CONTRACTOR SHALL BE RESPONSIBLE FOR ALL CUTTING AND PATCHING RELATED TO HIS WORK.
- RESTORE ALL DAMAGE RESULTING FORM YOUR WORK AND LEAVE PREMISES IN CLEAN CONDITION WHEN FINISHED WITH WORK.
- FURNISH AND INSTALL ALL MATERIALS, EQUIPMENT AND LABOR AS SHOWN AND AS NECESSARY FOR COMPLETE WORKABLE SYSTEMS.
- GARANTEE ALL WORK AND MATERIALS FOR ONE YEAR (MINIMUM) FROM DATE OF FILING NOTICE OF COMPLETION.
- PROVIDE FIVE BOUND COPIES OF EQUIPMENT SUBMITTALS PRIOR TO CONSTRUCTION FOR REVIEW AND APPROVAL. PROVIDE DIMENSIONALLY INSTALLATION DRAWINGS PLANS AND SECTIONS SHOWING ALL ARCHITECTURAL AND STRUCTURAL ELEMENTS, ALL EQUIPMENT, PIPING, ACCESSORIES, AND CLEARANCE FOR ACCESS, OPERATION AND SERVICING FOR ANY WORK THAT DEVATES FROM DESIGN.
- AT COMPLETION OF CONSTRUCTION PROVIDE AS-BUILT MARK-UPS AND THREE COPES OF BOUND OPERATIONS AND MAINTENANCE MANUALS.

DEMOLITION

- SUMMARY
 - REMOVING ABOVE-GRADE SITE IMPROVEMENTS WITHIN LIMITS INDICATED AS REQUIRED TO PERFORM TESTING BY OTHERS AND TO REPAIR DAMAGE LEFT BY TESTING OPERATIONS TO RESTORE BUILDING TO CONDITION SPECIFIED.
 - DISCONNECTING, CAPPING, OR SEALING, AND ABANDONING SITE UTILITIES IN PLACE.
 - DISCONNECTING, CAPPING, OR SEALING, AND REMOVING SITE UTILITIES.
 - DISPOSING OF OBJECTIONABLE MATERIAL.
- DEFINITIONS
 - ANSI: AMERICAN NATIONAL STANDARDS INSTITUTE.
 - CAL-OSHA: CALIFORNIA OCCUPATIONAL SAFETY AND HEALTH ADMINISTRATION.
- PROJECT CONDITIONS
 - EXCEPT FOR MATERIALS INDICATED TO BE STOCKPILED OR TO REMAIN THE OWNER'S PROPERTY, CLEARED MATERIALS ARE THE CONTRACTOR'S PROPERTY. REMOVE CLEARED MATERIALS FROM SITE AND DISPOSE OF IN LAWFUL MANNER.
 - SALVABLE IMPROVEMENTS: CAREFULLY REMOVE ITEMS INDICATED TO BE SALVAGED AND STORE WHERE INDICATED ON PLANS OR WHERE DESIGNATED BY THE OWNER. AVOID DAMAGING MATERIALS DESIGNATED FOR SALVAGE.
 - UNIDENTIFIED MATERIALS: IF UNIDENTIFIED MATERIALS ARE DISCOVERED, INCLUDING HAZARDOUS MATERIALS THAT WILL REQUIRE ADDITIONAL REMOVAL OTHER THAN IS REQUIRED BY THE CONTRACT DOCUMENTS, IMMEDIATELY REPORT THE DISCOVERY TO THE OWNER. IF NECESSARY, THE OWNER WILL ARRANGE FOR ANY TESTING OR ANALYSIS OF THE DISCOVERED MATERIALS AND WILL PROVIDE INSTRUCTIONS REGARDING THE REMOVAL AND DISPOSAL OF THE UNIDENTIFIED MATERIALS.
 - FOR ANY UTILITY LINES WHICH ARE TO BE PARTIALLY DEMOLISHED, THE CONTRACTOR SHALL PROVIDE NEW OPERABLE SERVICE RE-CONNECTION ALL THE WAY TO THE EXTENT OF THE UTILITY SOURCE IF NEEDED TO MAINTAIN SERVICE. THIS INCLUDES THE LOWERED OF ANY UTILITIES LINES TO ACHIEVE MINIMUM COVER REQUIREMENTS.

EXECUTION

- INSTALLATION
 - ALL EQUIPMENT, UNLESS OTHERWISE SHOWN OR NOTED ON THE DRAWINGS, IS TO BE INSTALLED IN ACCORDANCE WITH INDUSTRY STANDARDS AND MANUFACTURER'S RECOMMENDED INSTALLATION INSTRUCTIONS.
 - FLUSH AND CLEAN EQUIPMENT: IN ACCORDANCE WITH MANUFACTURER'S START-UP INSTRUCTIONS, AND IN PRESENCE OF MANUFACTURER'S REPRESENTATIVE. TEST CONTROLS AND DEMONSTRATE COMPLIANCE WITH REQUIREMENTS. REPLACE DAMAGE OR MALFUNCTIONING CONTROLS.
- FLUSH AND CLEAN WATER PIPING SYSTEMS
 - THE WATER TREATMENT CONTRACTOR SHALL BE RESPONSIBLE FOR FURNISHING THE CLEANING MATERIAL, AND SUPERVISING THE CHEMICAL CLEANING OF THE CHILLED WATER PIPING AND CONDENSER WATER PIPING.
 - THE SYSTEM TO BE CLEANED SHALL BE FILLED WITH A SOLUTION OF 10% BY WEIGHT OF A HEAVY DUTY ALKALINE LIQUID CLEANER. THE CLEANER SHALL BE CAPABLE OF WETTING AND PENETRATING HEAVY SOIL DEPOSITS OF OIL OR GREASE, AND KEEPING THESE PRODUCTS IN SUSPENSION, FOR REMOVAL THROUGH FLUSHING THE SYSTEM TO DRAIN.
 - THE CLEANING SOLUTION SHALL BE CIRCULATED FOR A MINIMUM OF 8 HOURS. AT THE END OF THE 8 HOURS, THE SYSTEM SHALL BE FLUSHED TO DRAIN, AND THEN REFILLED WITH FRESH WATER, TAKING CARE TO REMOVE ANY ENTRAPPED AIR FROM THE SYSTEM.
 - AT THE END OF THE CLEANING PERIOD, THE SYSTEM SHALL BE CHEMICALLY TREATED AS SPECIFIED. IN NO CASE SHALL THE SYSTEM BEING CLEANED BE LEFT IN AN UNTREATED CONDITION FOR MORE THAN 8 HOURS.
 - AT THE CONCLUSION OF THE CLEANING OPERATION, THE WATER TREATMENT CONTRACTOR SHALL CERTIFY IN WRITING THAT THE SYSTEM WAS CLEANED AS SPECIFIED.
- MANUFACTURER'S START-UP SERVICES: THE MANUFACTURER SHALL PROVIDE START-UP SERVICE IN THE FORM OF A FACTORY TRAINED SERVICE TECHNICIAN. THE SERVICE TECHNICIAN SHALL VERIFY CORRECT INSTALLATION, VERIFY EQUIPMENT MOUNTING AND INSTALLATION, VERIFY PIPING INSTALLATION, VERIFY CONTROL WIRING, VERIFY POWER WIRING, AND CHECK FOR PROPER OPERATION. THE SERVICE TECHNICIAN SHALL PROVIDE FINAL ADJUSTMENTS TO MEET THE SPECIFIED PERFORMANCE REQUIREMENTS. FULLY STAFFED PARTS AND SERVICE PERSONNEL SHALL BE WITHIN 4 HOURS TRAVEL FROM THE JOB SITE.

- RESTORATION
 - RESTORE DAMAGED IMPROVEMENTS TO THEIR ORIGINAL CONDITION, AS ACCEPTABLE TO THE OWNER.
- UTILITIES
 - LOCATE, IDENTIFY, DISCONNECT, AND SEAL OR CAP OFF UTILITIES INDICATED TO BE REMOVED OR ABANDONED. ANY PIPES TO BE ABANDONED SHALL BE FILLED WITH A CEMENT SLURRY.
 - ARRANGE TO SHUT OFF INDICATED UTILITIES WITH UTILITY COMPANIES OR VERIFY THAT UTILITIES HAVE BEEN SHUT OFF.
 - EXISTING UTILITIES: DO NOT INTERRUPT UTILITIES SERVING FACILITIES OCCUPIED BY OWNER OR OTHERS UNLESS AUTHORIZED IN WRITING BY THE OWNER, AND THEN ONLY AFTER ARRANGING TO PROVIDE TEMPORARY UTILITY SERVICES ACCORDING TO REQUIREMENTS INDICATED.
 - COORDINATE UTILITY INTERRUPTIONS WITH UTILITY COMPANY AFFECTED.
 - DO NOT PROCEED WITH UTILITY INTERRUPTIONS WITHOUT THE PERMISSION OF THE OWNER AND UTILITY COMPANY AFFECTED. NOTIFY OWNER AND UTILITY COMPANY AFFECTED TWO WORKING DAYS PRIOR TO UTILITY INTERRUPTIONS.
- DISPOSAL
 - REMOVE SURPLUS OBSTRUCTIONS, DEMOLISHED MATERIALS, AND WASTE MATERIALS, INCLUDING TRASH AND DEBRIS, AND LEGALLY DISPOSE OF THEM OFF THE OWNER'S PROPERTY. REFER TO SECTION 01 74 19 CONSTRUCTION WASTE MANAGEMENT AND DISPOSAL.

STEAM/CONDENSATE SPECIALTIES

- STRAINERS
 - PATTERN STRAINERS, STAINLESS STEEL:
 - BODY: ASTM A351 STAINLESS STEEL, WITH BOLTED COVER AND BOTTOM DRAIN CONNECTION.
 - END CONNECTIONS: THREADED FOR STRAINERS NPS 2 AND SMALLER; FLANGED ENDS FOR STRAINERS NPS 2-1/2 AND LARGER.
 - STRAINER SCREEN: 1/32 INCH PERFORATIONS IN MESH STAINLESS STEEL STRAINER SCREEN.
 - TAPPED BLOWOFF PLUG.
 - RATING: CLASS 600 FOR THREADED; CLASS 150 FOR FLANGED.
 - STOP-CHECK VALVES
 - STOP-CHECK VALVES:
 - BODY AND BONNET: CAST IRON.
 - END CONNECTIONS: FLANGED.
 - DISC: CYLINDRICAL WITH REMOVABLE LINER AND MACHINED SEAT.
 - STEM: BRASS ALLOY.
 - OPERATOR: OUTSIDE SCREW AND YOKE WITH CAST-IRON HANDWHEEL.
 - PACKING: PTFE-IMPREGNATED PACKING WITH TWO-PIECE PACKING GLAND ASSEMBLY.
 - PRESSURE CLASS: 250.
 - STEAM SAFETY VALVES
 - BRONZE STEAM SAFETY VALVES: ASME LABELED.
 - DISC MATERIAL: FORGED COPPER ALLOY.
 - END CONNECTIONS: THREADED INLET AND OUTLET.
 - SPRING: FULLY ENCLOSED STEEL SPRING WITH ADJUSTABLE PRESSURE RANGE AND POSITIVE SHUTOFF; FACTORY SET AND SEALED.
 - PRESSURE CLASS: 250.
 - DRIP-PAN ELBOW: CAST IRON AND HAVING THREADED INLET AND OUTLET, WITH THREADS COMPLYING WITH ASME B1.20.1.
 - SIZE AND CAPACITY: AS REQUIRED FOR EQUIPMENT ACCORDING TO ASME BOILER AND PRESSURE VESSEL CODE.
 - CAST-IRON STEAM SAFETY VALVES: ASME LABELED.
 - DISC MATERIAL: FORGED COPPER ALLOY WITH NOZZLE.
 - END CONNECTIONS: RAISED-FACE FLANGED INLET AND THREADED OR FLANGED OUTLET CONNECTIONS.
 - SPRING: FULLY ENCLOSED CADMIUM-PLATED STEEL SPRING WITH ADJUSTABLE PRESSURE RANGE AND POSITIVE SHUTOFF; FACTORY SET AND SEALED.
 - PRESSURE CLASS: 250.
 - DRIP-PAN ELBOW: CAST IRON AND HAVING THREADED INLET, OUTLET, AND DRAIN, WITH THREADS COMPLYING WITH ASME B1.20.1.
 - EXHAUST HEAD: CAST IRON AND HAVING THREADED INLET AND DRAIN, WITH THREADS COMPLYING WITH ASME B1.20.1.
 - SIZE AND CAPACITY: AS REQUIRED FOR EQUIPMENT ACCORDING TO ASME BOILER AND PRESSURE VESSEL CODE.
 - STEAM TRAPS
 - FLOAT AND THERMOSTATIC STEAM TRAPS, CAST IRON:
 - BODY AND BOLTED CAP: ASTM A128 CAST IRON.
 - END CONNECTIONS: THREADED.
 - FLOAT MECHANISM: REPLACEABLE, STAINLESS STEEL.
 - SEAT: HARDENED STAINLESS STEEL.
 - TRAP TYPE: BALANCED PRESSURE.
 - THERMOSTATIC BELLOW: STAINLESS STEEL OR MONEL.
 - THERMOSTATIC AIR VENT CAPABLE OF WITHSTANDING 45 DEG F OF SUPERHEAT AND RESISTING WATER HAMMER WITHOUT SUSTAINING DAMAGE.
 - VACUUM BREAKER: THERMOSTATIC WITH PHOSPHOR BRONZE BELLOWS, AND STAINLESS STEEL CAGE, VALVE, AND SEAT.
 - MAXIMUM OPERATING PRESSURE: 125 PSIG.
 - INVERTED BUCKET STEAM TRAPS, CAST IRON:
 - BODY AND CAP: CAST IRON.
 - END CONNECTIONS: THREADED.
 - HEAD AND SEAT: STAINLESS STEEL.
 - VALVE RETAINER, LEVER, AND GUIDE PIN ASSEMBLY: STAINLESS STEEL.
 - BUCKET: BRASS OR STAINLESS STEEL.
 - STRAINER: INTEGRAL STAINLESS STEEL INLET STRAINER WITHIN THE TRAP BODY.
 - AIR VENT: STAINLESS STEEL THERMOSTATIC VENT.
 - PRESSURE RATING: 250 PSIG.
 - THERMOSTATIC AIR VENTS AND VACUUM BREAKERS
 - VACUUM BREAKERS:
 - BODY: STAINLESS STEEL.
 - END CONNECTIONS: THREADED.
 - SEALING BALL, RETAINER, SPRING, AND SCREEN: STAINLESS STEEL.
 - ORING SEAL: ETHYLENE PROPYLENE RUBBER.
 - PRESSURE RATING: 125 PSIG.
 - MAXIMUM OPERATING TEMPERATURE: 350 DEG F.
 - FLEXIBLE CONNECTORS
 - STAINLESS STEEL BELLOWS, FLEXIBLE CONNECTORS:
 - BODY: STAINLESS STEEL BELLOWS WITH WOVEN, FLEXIBLE, BRONZE, WIRE-REINFORCED, PROTECTIVE JACKET.
 - END CONNECTIONS: THREADED OR FLANGED TO MATCH EQUIPMENT CONNECTED.
 - PERFORMANCE: CAPABLE OF 3/4-INCH MISALIGNMENT.
 - CWP RATING: 150 PSIG.
 - MAXIMUM OPERATING TEMPERATURE: 250 DEG F.

SLEEVES:

- THE CONTRACTOR SHALL PROVIDE SLEEVES TO PROTECT EQUIPMENT OR FACILITIES IN THE INSTALLATION. EACH SLEEVE SHALL EXTEND THROUGH ITS RESPECTIVE FLOOR, WALL OR PARTITION AND SHALL BE CUT FLUSH WITH EACH SURFACE EXCEPT SLEEVES THAT PENETRATE THE FLOOR, WHICH SHALL EXTEND 2" ABOVE THE FLOOR.
- ALL SLEEVES AND OPENINGS THROUGH FIRE RATED WALLS AND/OR FLOORS SHALL BE FIRE SEALED WITH CALCIUM SILICATE, SILICONE "RTV" FOAM, 3M FIRE RATED SEALANTS OR EQUAL, SO AS TO RETAIN THE FIRE RATING OF THE FLOOR OR WALL. CONFORM TO U.L. ASSEMBLY RATINGS OF FLOOR OR WALL.
- SLEEVES IN BEARING AND MASONRY WALLS, FLOORS, AND PARTITIONS SHALL BE STANDARD WEIGHT STEEL PIPE FINISHED WITH SMOOTH EDGES. FOR OTHER THAN MASONRY PARTITIONS, THROUGH SUSPENDED CEILINGS, OR FOR CONCEALED VERTICAL PIPING, SLEEVES SHALL BE NO. 22 U.S.G. GALVANIZED STEEL MINIMUM.
- DUCT SLEEVES TO BE MINIMUM 14 GAUGE STEEL.

HANGERS:

- HANGERS SHALL INCLUDE ALL MISCELLANEOUS STEEL SUCH AS ANGLE IRON, BANDS, C-CLAMPS WITH RETAINING CLIPS, CHANNELS, HANGER RODS, ETC., NECESSARY FOR THE INSTALLATION OF WORK.
- HANGERS SHALL BE FASTENED TO BUILDING STEEL, CONCRETE, OR MASONRY, BUT NOT TO PIPING OR DUCTWORK. HANGING FROM METAL DECK IS NOT PERMITTED. HANGERS MUST BE ATTACHED TO UPPER CHORD OF BAR JOIST. WHERE INTERFERENCES OCCUR, IN ORDER TO SUPPORT DUCTWORK OR PIPING, THE CONTRACTOR MUST INSTALL TRAPEZE TYPE HANGERS OR SUPPORTS WHICH SHALL BE LOCATED WHERE THEY DO NOT INTERFERE WITH ACCESS TO FIRE DAMPERS, VALVES, ACCESS DOORS AND OTHER EQUIPMENT SERVICE REQUIREMENTS AND/OR OTHER TRADES. HANGER TYPES AND INSTALLATION METHODS ARE SUBJECT TO LANDLORD CRITERIA.
- HANGERS FOR ALL INSULATED PIPING SHALL BE SIZED AND INSTALLED FOR THE OUTER DIAMETER OF INSULATION. INSTALL 6" LONG SPLIT CIRCLE GALVANIZED SADDLE BETWEEN THE HANGER AND THE PIPE INSULATION.
- HANGERS AND PIPING OF DISSIMILAR METALS SHALL BE DI-ELECTRICALLY SEPARATED FROM ONE ANOTHER.

SEISMIC RESTRAINT REQUIREMENTS

- BRACE MECHANICAL SYSTEMS AND ITEMS OF EQUIPMENT TO WITHSTAND LATERAL AND VERTICAL FORCES THAT RESULT FROM EARTHQUAKES.
- PROVIDE COMPLETE SEISMIC ANCHORAGE AND BRACING FOR ALL SUSPENDED MECHANICAL EQUIPMENT TO RESIST A HORIZONTAL FORCE ACTING IN ANY DIRECTION.
- PROVIDE RESTRAINTS WITH BRACING FOR PIPES. THE DESIGN AND INSTALLATION OF PIPING RESTRAINING DEVICES FOR LATERAL AND VERTICAL FORCES SHALL BE IN ACCORDANCE WITH OPM-0043

SYSTEM TESTING, ADJUSTING, AND BALANCING

- PRIOR TO REMOVING EXISTING CHILLER PERFORM A PRE-FUNCTIONAL TEST, COMMISSIONING AND TREND LOG ANALYSIS.
- COMMISSIONING SPEC TO BE PROVIDED BY THE COMMISSIONING AGENT.
- TESTING, ADJUSTING AND BALANCING OF ALL WORK SHALL BE MADE BY AN INDEPENDENT CONTRACTOR WHO IS CURRENTLY LICENSED ASSOCIATED AIR BALANCING CONSULTANT (AABC) OR NATIONAL ENVIRONMENTAL BALANCING BUREAU (NEBB) BALANCING CONTRACTOR. NO OTHER BALANCE REPORTS WILL BE REVIEWED OR ACCEPTED. ALL BALANCING WORK MUST BE COMPLETE AND DONE IN ACCORDANCE WITH THE MOST RECENT STANDARDS OF THEIR SOCIETY. PAYMENT OF ALL COSTS FOR TESTING SHALL BE MADE BY THE HVAC CONTRACTOR.
- BALANCE WATER QUANTITIES TO WITHIN + 5% OF THAT INDICATED ON THE DRAWINGS.
- THE BALANCE REPORT SHALL INCLUDE AS A MINIMUM THE FOLLOWING INFORMATION:
 - AABC OR NEBB CERTIFICATION NUMBER AND SIGNATURE OF BALANCING CONTRACTOR.
 - INSTRUMENTATION LIST WITH LAST CALIBRATION DATES.
 - MAKE AND MODEL NUMBERS OF ALL HVAC EQUIPMENT TESTED.
 - MOTOR NAMEPLATE DATA WITH ACTUAL FIELD VOLTAGE AND AMPERAGE READINGS FOR EACH LEG.
 - MOTOR RPM'S.
 - WATER BALANCE DATA INCLUDING GPM WITH INLET AND OUTLET TEMPERATURE AND PRESSURE READINGS (WHERE APPLICABLE).
- ALL CONTROL SEQUENCES SHALL BE TESTED, INTERLOCKED EQUIPMENT, AND OPERATING STATUS RECORDED IN THE REPORT.
- THREE COPIES OF THE BALANCE REPORT SHALL BE SUBMITTED THROUGH THE GENERAL CONTRACTOR TO THE TENANT'S CONSTRUCTION MANAGER FOR APPROVAL.
- THE BALANCING CONTRACTOR SHALL PERFORM ALL APPLICABLE TESTING AND BALANCING FUNCTIONS REQUIRED FOR THE SYSTEM DESIGNED IN THESE DRAWINGS. THE BALANCING CONTRACTOR SHALL RECHECK ANY ITEMS THAT THE TENANT DEEMS NECESSARY AT NO ADDITIONAL COST TO THE TENANT.
- FINAL BALANCE REPORT SHALL BE INCLUDED IN THE OPERATION & MAINTENANCE MANUALS.

FINAL HVAC INSPECTIONS

- ASIDE FROM NORMAL INTERIM INSPECTIONS OF WORK IN PLACE, THE TENANT SHALL HAVE THE RIGHT TO AN INDEPENDENT HVAC CONTRACTOR INSPECT THE FINISHED HVAC INSTALLATION UPON COMPLETION FOR COMPLIANCE WITH THE PLANS, SPECIFICATIONS, AND CODES. THE INSTALLING CONTRACTOR WILL BE RESPONSIBLE TO BRING ALL ITEMS REPORTED BY THE INDEPENDENT HVAC CONTRACTOR UP TO PLANS AND SPECIFICATION REQUIREMENTS AT NO COST TO TENANT.

APPROVAL



CLIENT



385 NORTH ARROWHEAD AVENUE, 3RD FLOOR
SAN BERNARDINO, CA 92415-0184


PROJECT NAME

ARMC
DEAEERATOR #1
REPLACEMENT

PROJECT NO.
WBSE # 10.10.0847
CIP # 20-011
HCAI # S230562-36-00
FACILITY NO.
17282
BUILDING NO.
BLD-00075 CENTRAL PLANT

400 N. PEPPER AVENUE
COLTON, CA 92324-1801

ENGINEER/ARCHITECT

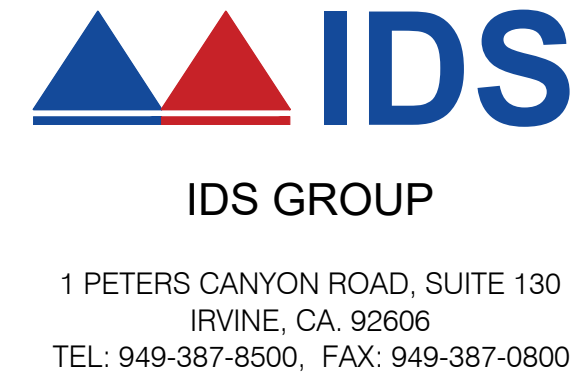

STAMP



STAMP


ISSUE		
REV.	DESCRIPTION	DATE
	HCAI SUBMITTAL	04/28/23
A	BACK CHECK #1	06/16/23
B	BACK CHECK #2	07/28/23

PROJECT IDENTIFICATION	
THIS DRAWING WAS CREATED IN AUTODESK AUTOCAD V. 2021 UNLESS OTHERWISE NOTED.	
THE ORIGINAL SIZE OF THIS SHEET IS 30" X 42"	
THESE DRAWINGS AND SPECIFICATIONS ARE THE PROPERTY AND COPYRIGHT OF IDS GROUP AND SHALL NOT BE USED ON ANY OTHER PROJECT OR LOCATIONS EXCEPT AS DESCRIBED ON THE DRAWINGS, WITHOUT THE WRITTEN AGREEMENT WITH IDS GROUP.	
IDS PROJECT NO.	22X066.02
DRAWN BY	ABZ
CHECKED BY	ADS
APPROVED BY	DBS

SHEET TITLE	
MECHANICAL SPECIFICATIONS	
SHEET NUMBER	
M-002	
SHEET NO. 002	OF 006

PLAN CHECK - NOT FOR CONSTRUCTION

IDS GROUP - FILE LOCATION: S:\PROJECTS\2022\SHARED\22X066.02 ARMC - REPLACEMENT DEAERATOR 105 CAD\04 MECH\22X06602_M102_TEMP_PLOT DATE: 6/16/2023 3:24:48 PM USER: ANTHONY.ZANOTTI

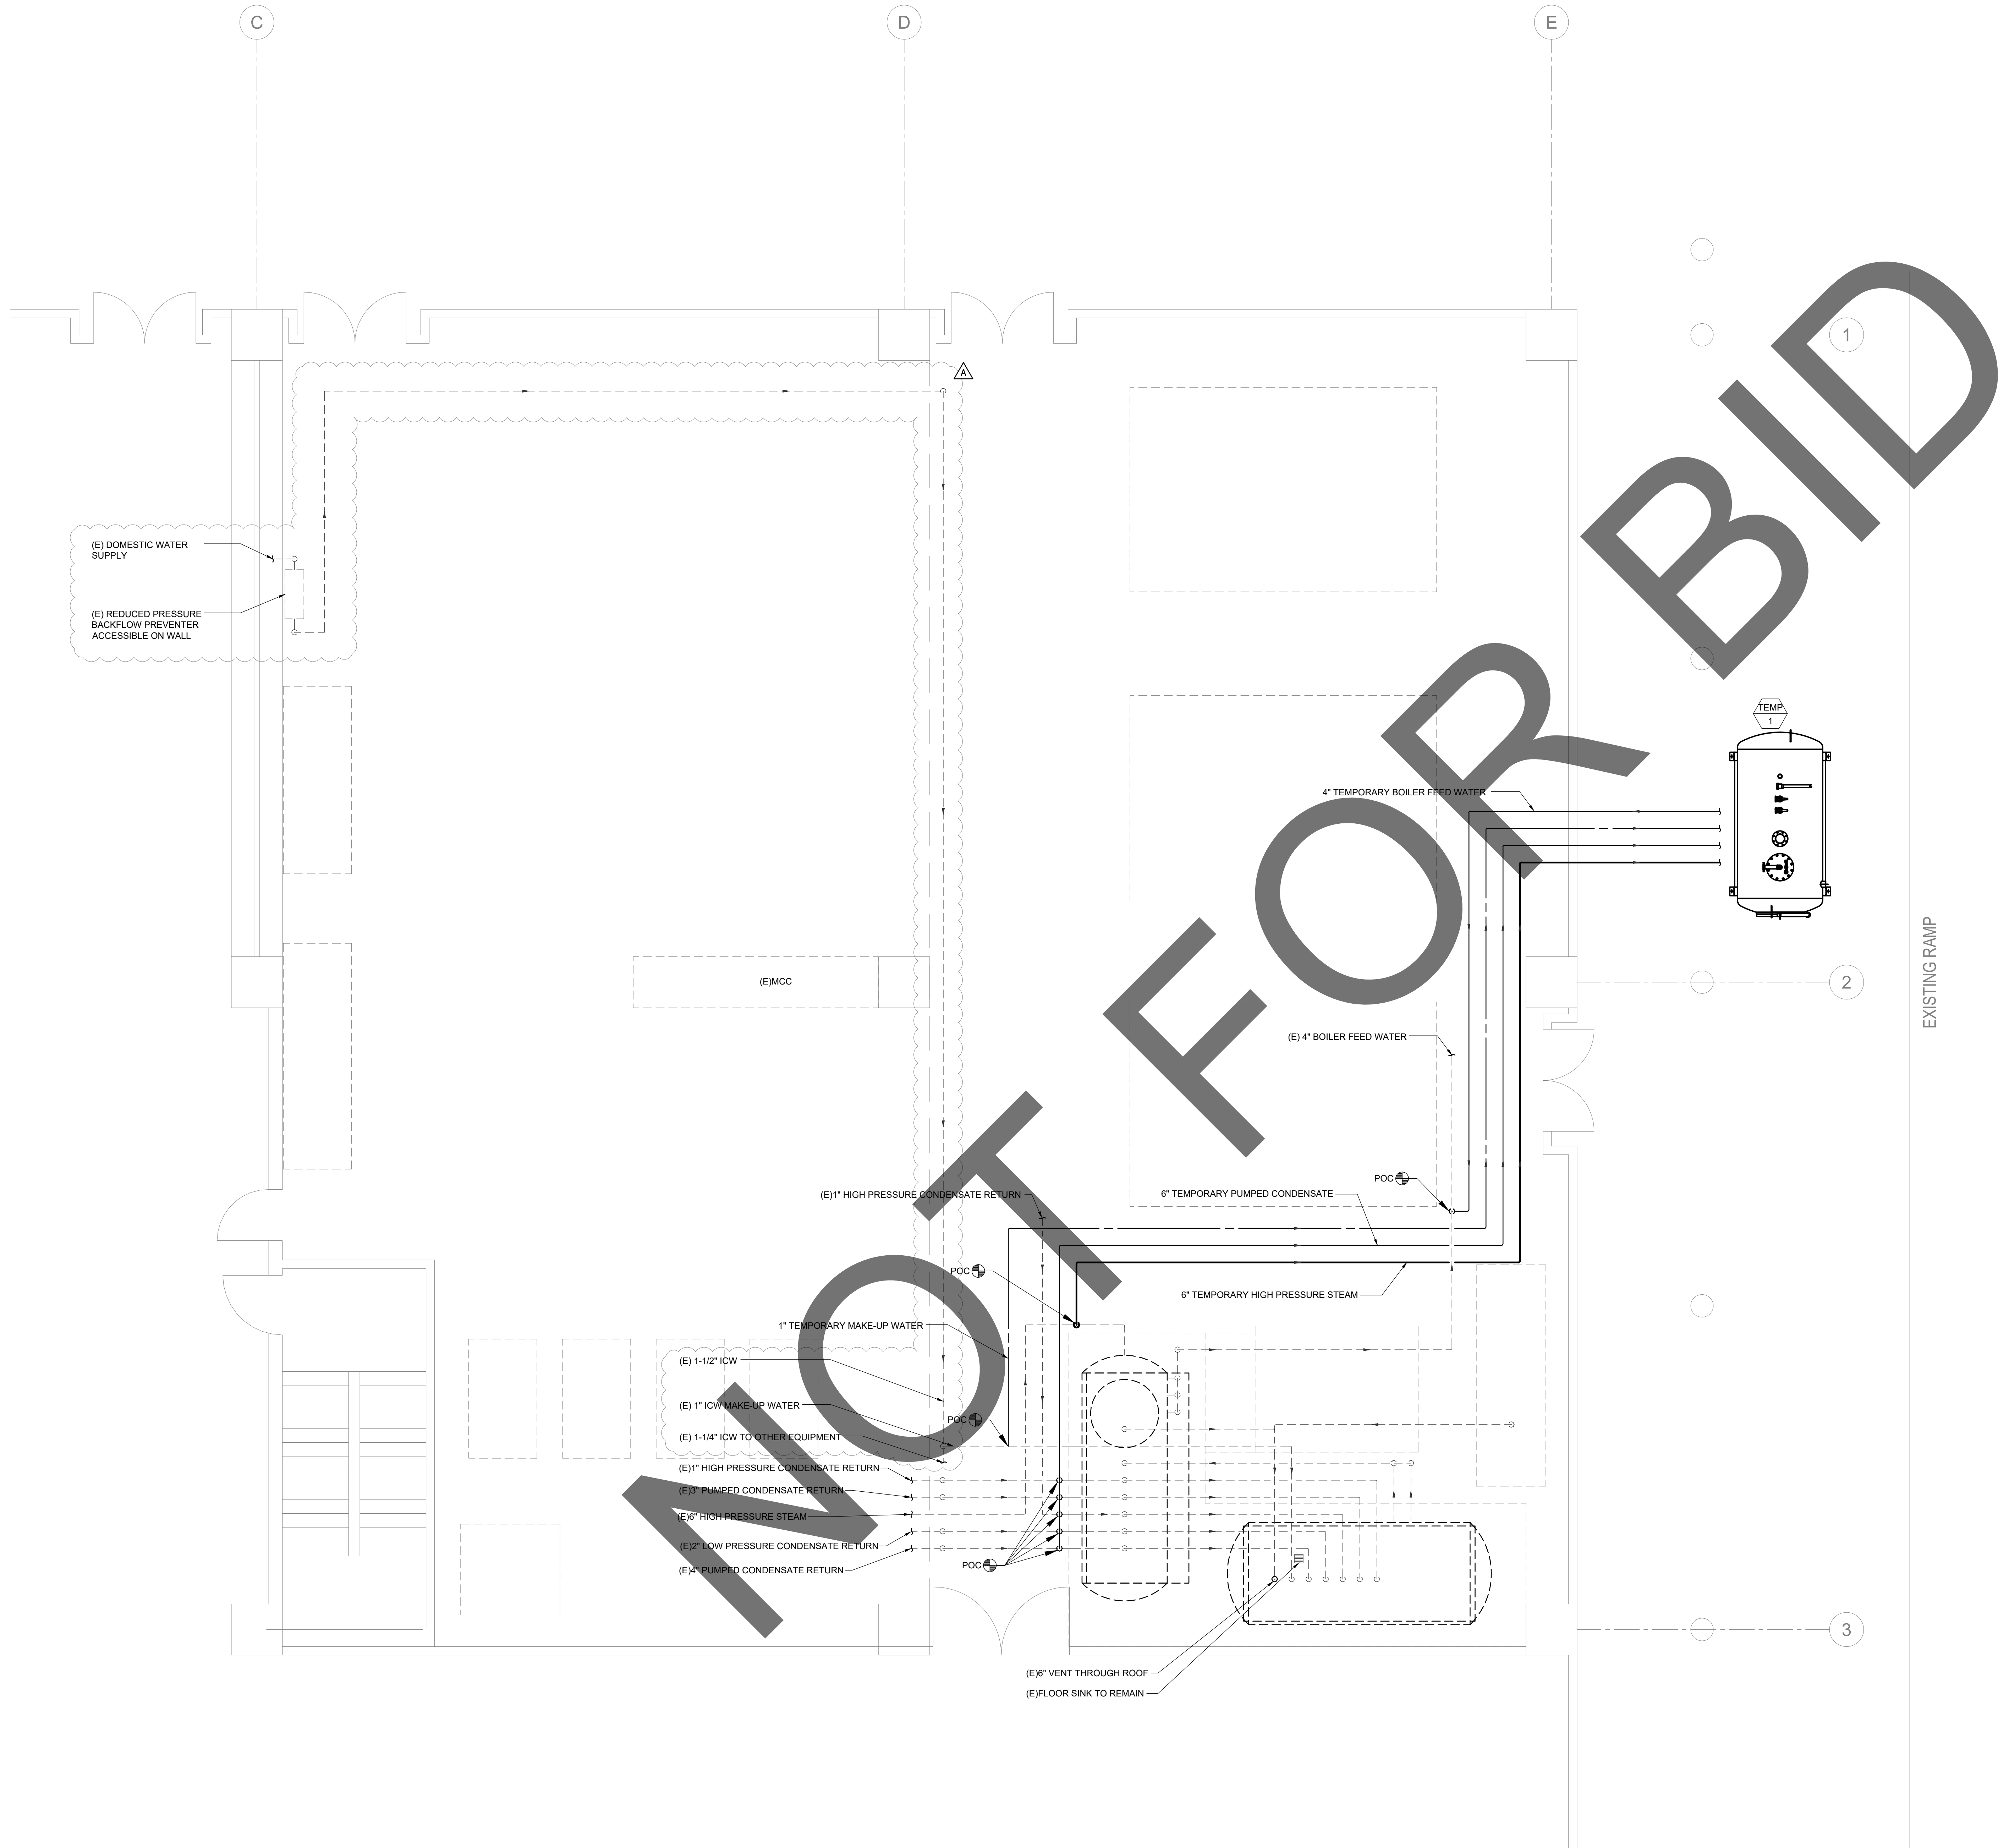

GENERAL NOTES

1. THE TEMPORARY EQUIPMENT WILL ONLY BE IN OPERATION DURING REPLACEMENT OF EQUIPMENT, AND SHALL NOT EXCEED 180 DAYS.

APPROVAL



CLIENT



PROJECT NAME

ARMC
DEAERATOR #1
REPLACEMENT


PROJECT NO.
WBSE # 10.10.0847
CIP # 20-011
HCAI # S230562-36-00
FACILITY NO.
17282
BUILDING NO.
BLD-00075 CENTRAL PLANT

400 N. PEPPER AVENUE
COLTON, CA 92324-1801

ENGINEER/ARCHITECT



STAMP

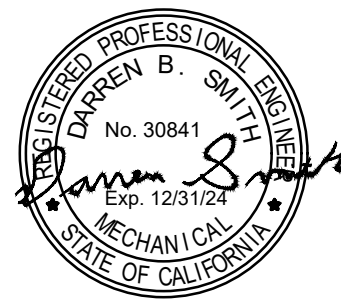

STAMP

ISSUE

REV.	DESCRIPTION	DATE
	HCAI SUBMITTAL	04/28/23
A	BACK CHECK #1	06/16/23
B	BACK CHECK #2	07/28/23

PROJECT IDENTIFICATION

THIS DRAWING WAS CREATED IN AUTODESK AUTOCAD V. 2021 UNLESS OTHERWISE NOTED.
THE ORIGINAL SIZE OF THIS SHEET IS 30" X 42"
THESE DRAWINGS AND SPECIFICATIONS ARE THE PROPERTY AND COPYRIGHT OF IDS GROUP AND SHALL NOT BE USED ON ANY OTHER PROJECT OR LOCATIONS EXCEPT AS DESCRIBED ON THE DRAWINGS, WITHOUT THE WRITTEN AGREEMENT WITH IDS GROUP.

IDS PROJECT NO.	22X066.02
DRAWN BY	
CHECKED BY	
APPROVED BY	

SHEET TITLE

MECHANICAL
FLOOR PLAN
TEMPORARY
WORK


SHEET NUMBER

M-101

SHEET NO. 003 OF 006

PLAN CHECK - NOT FOR CONSTRUCTION

IDS GROUP - FILE LOCATION: S:\PROJECTS\2022\SHARED\22X066.02 ARMC - REPLACEMENT DEAERATOR 105 CAD04 MECH\22X06602_M101_DEMO_PLOT DATE: 6/16/2023 3:24:57 PM USER: SUHAL SHAHZAD

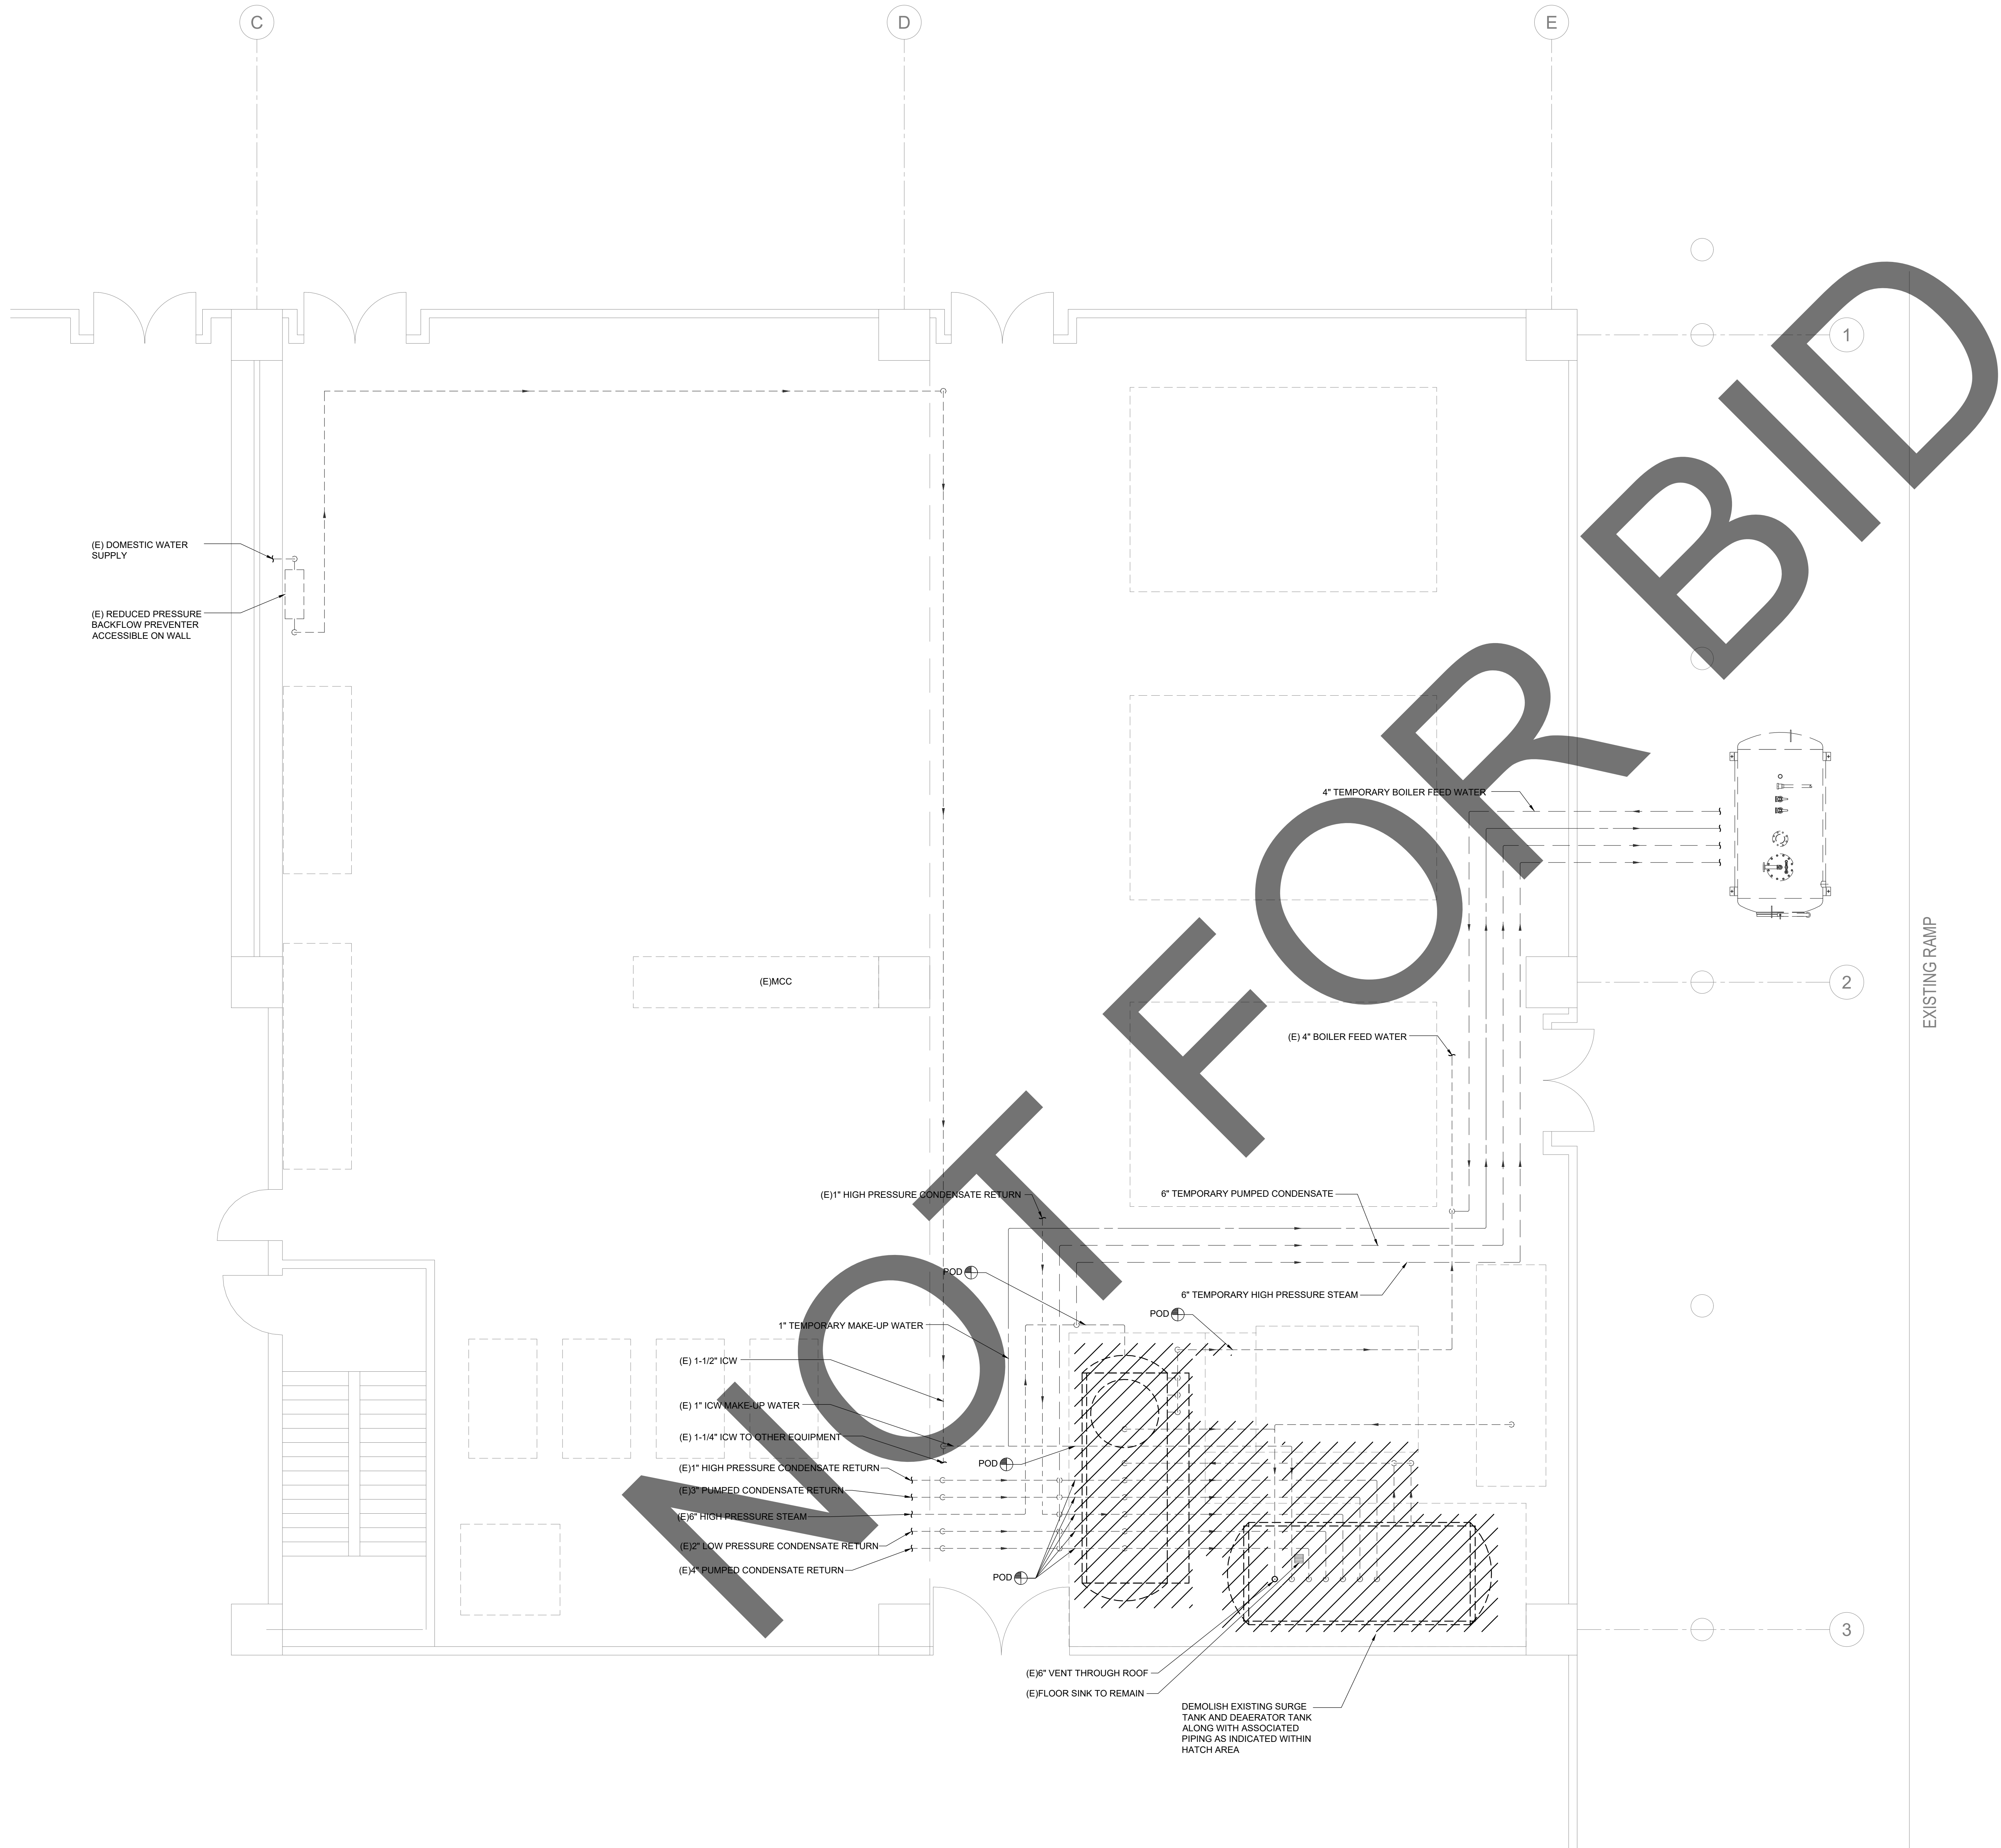

DEMOLITION KEYNOTES

APPROVAL

REVIEWED IN ACCORDANCE WITH THE REQUIREMENTS OF T24, COR

APPROVED

Department of Health Care Access & Information
Office of Statewide Hospital Planning & Development
6/9/2023, 7:23:46 AM
S230562-36-00
Allen Cheng

CLIENT

SAN BERNARDINO COUNTY

SAN BERNARDINO COUNTY
PROJECT AND FACILITIES
MANAGEMENT DEPARTMENT

385 NORTH ARROWHEAD AVENUE, 3RD FLOOR
SAN BERNARDINO, CA 92415-0184

PROJECT NAME

**ARMC
DEAERATOR #1
REPLACEMENT**

PROJECT NO.
WBSE # 10.10.0847
CIP # 20-011
HCAI # S230562-36-00

FACILITY NO.
17282

BUILDING NO.
BLD-00075 CENTRAL PLANT

400 N. PEPPER AVENUE
COLTON, CA 92324-1801

ENGINEER/ARCHITECT

IDS

IDS GROUP

1 PETERS CANYON ROAD, SUITE 130
IRVINE, CA, 92606
TEL: 949-387-6500, FAX: 949-387-0800

STAMP

REGISTERED PROFESSIONAL MECHANICAL ENGINEER
No. 30841
Exp. 12/31/24
S. H. CHENG
MECHANICAL
STATE OF CALIFORNIA

STAMP

ISSUE		
REV.	DESCRIPTION	DATE
	HCAI SUBMITTAL	04/28/23
A	BACK CHECK #1	06/16/23
B	BACK CHECK #2	07/28/23

PROJECT IDENTIFICATION

THIS DRAWING WAS CREATED IN AUTODESK AUTOCAD V. 2021
UNLESS OTHERWISE NOTED.

THE ORIGINAL SIZE OF THIS SHEET IS 30" X 42"

THESE DRAWINGS AND SPECIFICATIONS ARE THE PROPERTY AND
COPYRIGHT OF IDS GROUP AND SHALL NOT BE USED ON ANY
OTHER PROJECT OR LOCATIONS EXCEPT AS DESCRIBED ON THE
DRAWINGS, WITHOUT THE WRITTEN AGREEMENT WITH IDS GROUP.

IDS PROJECT NO.	22X066.02
DRAWN BY	AZ
CHECKED BY	AZ
APPROVED BY	DS

SHEET TITLE


**MECHANICAL FLOOR
PLAN DEMOLITION**

SHEET NUMBER

M-102

SHEET NO. 004 OF 006

PLAN CHECK - NOT FOR CONSTRUCTION

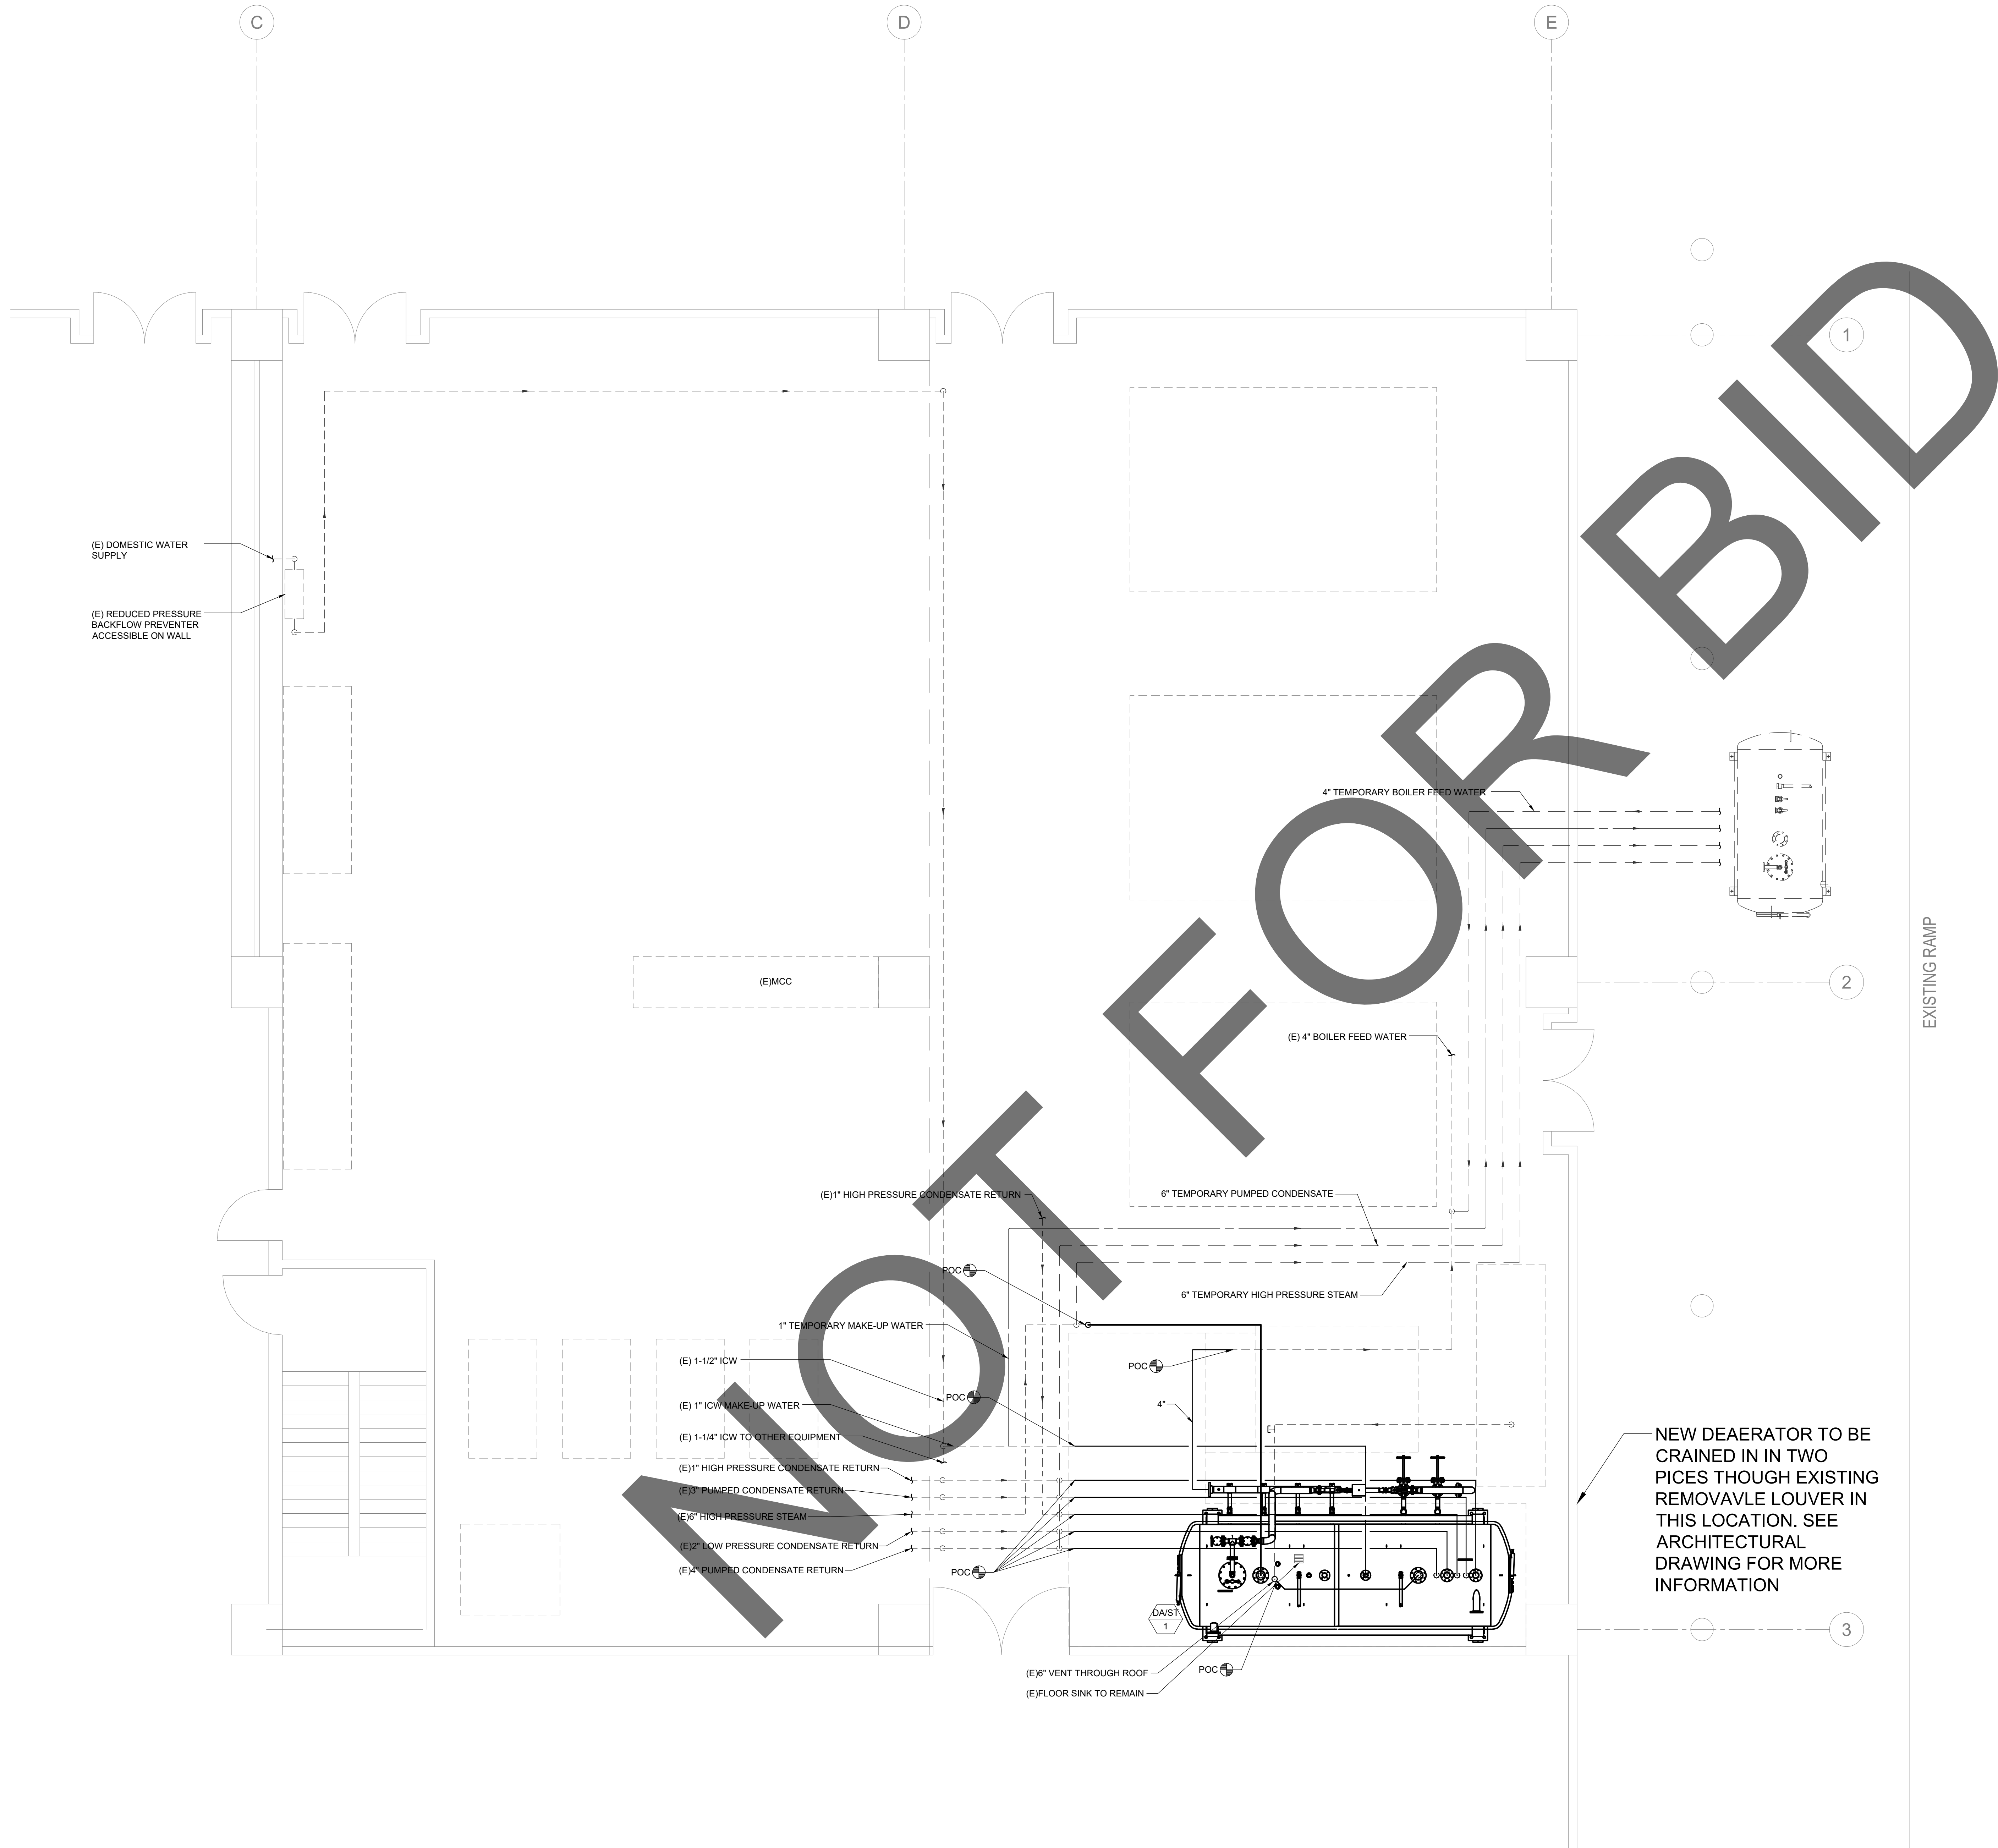

GENERAL NOTES

1. All TEMPORARY EQUIPMENT, PIPING, AND SUPPORTS ARE TO BE REMOVED ONCE THE NEW DEAEERATOR SYSTEM IS OPERATING.

APPROVAL



CLIENT



PROJECT NAME

ARMC
DEAEERATOR #1
REPLACEMENT

PROJECT NO.

WBSE # 10.10.0847
CIP # 20-011
HCAI # S230562-36-00

FACILITY NO.

17282

BUILDING NO.

BLD-00075 CENTRAL PLANT

400 N. PEPPER AVENUE
COLTON, CA 92324-1801

ENGINEER/ARCHITECT



STAMP



STAMP

ISSUE

REV.	DESCRIPTION	DATE
	HCAI SUBMITTAL	04/28/23
A	BACK CHECK #1	06/16/23
B	BACK CHECK #2	07/28/23

PROJECT IDENTIFICATION

THIS DRAWING WAS CREATED IN AUTODESK AUTOCAD V. 2021 UNLESS OTHERWISE NOTED.
THE ORIGINAL SIZE OF THIS SHEET IS 30" X 42"
THESE DRAWINGS AND SPECIFICATIONS ARE THE PROPERTY AND COPYRIGHT OF IDS GROUP AND SHALL NOT BE USED ON ANY OTHER PROJECT OR LOCATIONS EXCEPT AS DESCRIBED ON THE DRAWINGS, WITHOUT THE WRITTEN AGREEMENT WITH IDS GROUP.

IDS PROJECT NO.	22X066.02
DRAWN BY	AZ
CHECKED BY	AZ
APPROVED BY	DS

SHEET TITLE

MECHANICAL
FLOOR PLAN

SHEET NUMBER

M-201

SHEET NO. 005 OF 006

PLAN CHECK - NOT FOR CONSTRUCTION

ELECTRICAL SPECIFICATIONS

A. MATERIALS

1. MATERIALS SHALL BE NEW AND OF QUALITY AS SPECIFIED ON THE PLANS OR SPECIFICATIONS AND MUST CARRY THE UNDERWRITER'S LABORATORIES APPROVAL COVERING THE PURPOSE FOR WHICH THEY ARE USED, IN ADDITION TO MEETING REQUIREMENTS OF THE CURRENT APPLICABLE CODES AND REGULATIONS.

B. CONDUIT

1. ALL WIRING SHALL BE INSTALLED IN LISTED METALLIC CONDUIT EXCEPT AS PERMITTED BELOW. RGS, WITH A 20 MIL PVC COATING WILL BE USED WHEN IN CONTACT WITH EARTH. IMC MAY BE USED IN INDOOR LOCATIONS NOT IN CONTACT WITH THE EARTH. EMT MAY BE USED IN INDOOR LOCATIONS NOT IN CONTACT WITH EARTH, NOT IN CONCRETE SLABS OR WALLS AND NOT SUBJECT TO DAMAGE. PVC MAY BE USED IN OR BELOW CONCRETE AND DIRECT BURIED IN EARTH. FLEXIBLE STEEL CONDUIT SHALL BE USED FOR INDOOR FINAL CONNECTIONS TO EQUIPMENT IN LENGTHS NOT TO EXCEED 72". LIQUID-TIGHT FLEXIBLE STEEL CONDUIT SHALL BE FOR OUTDOOR FINAL CONNECTIONS TO EQUIPMENT NOT TO EXCEED 36".
2. WHERE CONDUIT ENTERS OUTLET BOXES, FIXTURES OR CABINETS, FIRMLY FASTEN WITH STEEL SET SCREW, COMPRESSION CONNECTORS, OR DOUBLE LOCKNUTS FOR GRC CONNECTIONS SHALL HAVE BUSHINGS OR INSULATED THROAT CONNECTORS. FIRMLY FASTEN CONDUIT TO THE BUILDING CONSTRUCTION. RUN EXPOSED CONDUIT PARALLEL TO THE BUILDING LINES, SUPPORTED BY APPROPRIATE HANGERS (UNISTRUT, T & B OR APPLERON, OR EQUAL).
3. COVER METALLIC CONDUIT IN CONTACT WITH EARTH WITH POLYETHYLENE TAPED SPIRAL WRAPPED, 1/2 LAPPED TO PROVIDE 20 MIL THICKNESS. TAPE SHALL BE SCOTCH NO. 50 TAPE. CONDUIT AND DUCTS NOT UNDER BUILDINGS AND FEEDER DUCTS SHALL BE INSTALLED PER N.E.C. 300-5. MAKE JOINTS WITH COMPOUND TO BE WATERTIGHT.
4. FITTINGS AND CONDUIT BODIES SHALL BE STEEL, NO DIECAST FITTINGS.
5. CONDUIT SIZES SHALL BE AS REQUIRED BY CODE AND AS INDICATED OR SPECIFIED.
6. EMPTY CONDUIT SYSTEMS SHALL HAVE A NYLON PULL STRING TO FACILITATE INSTALLATION OF FUTURE WIRE.
7. SCHEDULE 40 PVC CONDUIT SHALL BE PERMITTED UNDERGROUND WITH PROPER FITTINGS. UL APPROVED AND CEMENTED JOINTS. CONNECTIONS THROUGH FLOOR SLABS AND BENDS GREATER THAN 22" SHALL BE WRAPPED RIGID GALVANIZED STEEL ELBOWS.
8. CONDUITS AND OUTLETS SHALL BE CONCEALED WITH THE BUILDING STRUCTURE, EXCEPT THAT CERTAIN MOTOR AND LIGHTING FEEDER CONDUITS MAY BE RUN EXPOSED IN CERTAIN AREAS AS INDICATED ON THE DRAWINGS. CONDUIT SHOWN TO BE INSTALLED IN CABINETS, COUNTERTOPS, AND CASEWORK SHALL BE RUN AS DIRECTED BY THE ARCHITECT.
9. CONDUIT SYSTEMS SHALL HAVE A CODE SIZED COPPER GROUND CONDUCTOR INCREASE CONDUIT SIZE AS REQUIRED.
10. CONDUIT PENETRATION THROUGH ROOF SHALL HAVE ROOF FLASHING WITH CAULK TYPE COUNTER FLASHING SLEEVE. INSTALLATION SHALL BE WATERTIGHT.
11. CONDUITS SHALL BE ROUTED SURFACE ON THE STRUCTURE, PARALLEL AND PERPENDICULAR TO THE STRUCTURE.

C. OUTLET, PULL, AND JUNCTION BOXES

1. EACH SWITCH, LIGHT, RECEPTACLE OR OTHER OUTLET SHALL BE PROVIDED WITH A CODE GAUGE, GALVANIZED STEEL OUTLET BOX. JUNCTION AND PULL BOXES SHALL BE CODE GAUGE, GALVANIZED STEEL. OUTLET BOXES SHALL BE OF THE ONE PIECE, KNOCKOUT TYPE, IN GENERAL 4" SQUARE WITH PLASTER RING. PLASTER RINGS SHALL BE SET TO PROVIDE NOT MORE THAN 1/8" FROM WALL SURFACE TO RING. IN NO CASE SHALL PLASTER RING PROJECT BEYOND SURFACE OF WALL. SINGLE GANG RINGS SIMILAR TO STEEL CITY 52050 SHALL BE USED FOR 4" BOXES IN UNFINISHED BRICK NUMBER 180 BOXES MAY BE USED FOR UNFINISHED MASONRY FLUSH WALL OUTLETS. CENTER OUTLET BOXES IN BLOCK COURSE.
2. BOXES INSTALLED IN POURED CEMENT FLOORS SHALL BE FLUSH TYPE CAST IRON OR STEEL WITH WATERTIGHT GASKETED COVERS. WHERE BOXES ARE INSTALLED IN FLOORS WITH TILE OR CARPET FLOOR COVERING, COVERS SHALL BE OF THE RECESSED TYPE TO ACCOMMODATE THE FLOOR COVERING.
3. BOXES INSTALLED FOR THE ALARM, COMPUTER, AND SECURITY SYSTEM SHALL BE PROVIDED WITH APPROPRIATE COVER PLATES.
4. BOXES FOR TELEPHONE, COMPUTER, T.V., FIRE ALARM, SECURITY, AND SIMILAR SYSTEMS SHALL BE MINIMUM 4" SQUARE AND 2-1/8" DEEP.

D. SWITCHBOARDS

1. SWITCHBOARDS SHALL BE PROVIDED WITH FULLY RATED COPPER OR ALUMINUM BUS. HORIZONTAL TAPERED BUSSING SHALL NOT BE ALLOWED.
2. ACCEPTABLE MANUFACTURERS - CUTLER HAMMER, SIEMENS, SQUARE D OR APPROVED EQUAL.
3. FACTORY ASSEMBLED DEAD FRONT, METAL ENCLOSED, AND SELF-SUPPORTING SWITCHBOARD ASSEMBLY CONFORMING TO NEMA PB 2, AND UL 891, AND COMPLETE FROM INCOMING LINE TERMINALS TO LOAD SIDE TERMINATIONS.
4. LINE AND LOAD TERMINATIONS: ACCESSIBLE FROM THE FRONT ONLY OF THE SWITCHBOARD, SUITABLE FOR THE CONDUCTOR MATERIALS AND NUMBER OF CONDUCTORS USED.
5. BUS CONNECTIONS: BOLTED, ACCESSIBLE FROM FRONT FOR MAINTENANCE; PROVIDE BELLEVILLE WASHERS FOR AND PROPERLY TORQUE CONNECTIONS.
6. PROVIDE FULLY-RATED NEUTRAL BUS AND FULLY RATED GROUND BUS MATCHING MATERIAL USED FOR MAIN BUS.
7. FUTURE PROVISIONS: FULLY EQUIP SPACES FOR FUTURE DEVICES WITH BUSSING AND BUS CONNECTIONS, SUITABLY INSULATED AND BRACED FOR SHORT CIRCUIT CURRENTS, CONTINUOUS CURRENT RATING AS INDICATED ON DRAWINGS.

E. PANEL BOARDS

1. CIRCUIT BREAKER TYPE AS INDICATED ON DRAWINGS. UNLESS INDICATED OTHERWISE, PANELS SHALL HAVE PANEL BOARD TYPE CONSTRUCTION WITH BOLT-ON CIRCUIT BREAKERS FOR 30 PANELS. MANUFACTURERS SHALL BE GENERAL ELECTRIC, SQUARE D, SIEMENS, CUTLER-HAMMER OR EQUAL WITH VOLTAGE, SIZES, AND RATINGS AS INDICATED ON DRAWINGS.
2. THE CIRCUIT BREAKERS SHALL BE OPERABLE IN ANY POSITION AND BE REMOVABLE FROM THE FRONT OF THE PANEL BOARD WITHOUT DISTURBING THE ADJACENT UNITS. BRANCH BREAKERS SHALL BE OF SUCH DESIGN THAT COMBINATION OF SINGLE-POLE, DOUBLE-POLE, AND THREE-POLE BREAKERS CAN BE ASSEMBLED ON THE SAME PANEL. EACH BRANCH CIRCUIT SHALL BE CLEARLY NUMBERED. BRANCH AND MAIN TERMINALS SHALL BE OF THE SOLDERLESS TYPE. HANDLE TIES TO FORM MULTI-POLE BREAKERS NOT ACCEPTABLE.
3. WIRE TERMINATION FOR PANEL BOARDS AND CIRCUIT BREAKERS SHALL BE LISTED AS SUITABLE FOR 75 DEGREES C.
4. PROVIDE A TYPEWRITTEN CIRCUIT INDEX BEHIND CLEAR PLASTIC COVER ON INSIDE OF DOOR. INFORMATION SHALL INCLUDE ROOM AND TYPE LOAD SERVED. CIRCUIT BREAKERS SHALL BE IDENTIFIED, INCLUDING SPARES. INDEX CARD FRAME SHALL BE METAL, SECURED TO DOOR.
5. WHERE PANEL BOARDS ARE INSTALLED FLUSH WITH THE WALLS, EXTEND EMPTY CONDUITS FORM THE PANEL BOARD TO AN ACCESSIBLE SPACE ABOVE OR BELOW. PROVIDE 3/4" (MINIMUM SIZE) CONDUIT FOR EVERY THREE SINGLE SPARE CIRCUIT BREAKERS OR SPACE OR EQUIVALENT MULTI-POLE ARRANGEMENT, OR FRACTION THEREOF, BUT NOT LESS THAN TWO CONDUITS FOR EACH PANEL.
6. PANEL BOARDS TO BE PROVIDED WITH COPPER BUSSING ONLY.
7. LOAD CENTERS SHALL NOT BE ALLOWED UNLESS NOTED OTHERWISE.
8. NEW PANELBOARDS SHALL COMPLY WITH NEC ARTICLE 110.16. EQUIPMENT MANUFACTURERS SHALL PROVIDE PRELIMINARY PANELBOARDS, GENERATORS, AUTOMATIC TRANSFER SWITCHES TO WARN QUALIFIED PERSONS OF POTENTIAL ELECTRIC ARC FLASH HAZARDS. THE MARKING SHALL BE LOCATED SO AS TO BE CLEARLY VISIBLE TO QUALIFIED PERSONS BEFORE EXAMINATION, ADJUSTMENT, SERVICE, OR MAINTENANCE OF THE EQUIPMENT.

F. WIRE

1. CONDUCTOR SIZES SHOWN ON THE DRAWINGS ARE BASED ON COPPER WIRE. UNLESS OTHERWISE SPECIFIED, WIRE SHALL BE TYPE XHHW FOR FEEDERS OR BRANCH CIRCUITS LARGER THAN 4 AWG, TYPE THHN/THW INSULATION FOR FEEDERS AND BRANCH CIRCUITS 4 AWG AND SMALLER. BRANCH CIRCUIT WIRING SHALL BE COPPER. SERVICE AND PANEL FEEDERS #10 AND LARGER MAY BE ALUMINUM, PROVIDED THE CONDUCTOR SIZES ARE INCREASED FOR EQUAL OR GREATER AMPLACITY AND EQUAL OR LESS EQUIVALENT VOLTAGE DROP. INCREASE CONDUIT SIZE AS REQUIRED. THE WIRES SHALL BE MARKED WITH COLOR TO SIMPLIFY CIRCUIT IDENTIFICATION. UNLESS OTHERWISE REQUIRED BY LOCAL ORDINANCES GROUND WIRES SHALL BE GREEN, NEUTRAL WIRES SHALL BE 120V, WHITE 277V, GRAY, AND LIVE WIRES 208Y/120V AND 120/240 SHALL BE BLACK (PHASE A), RED (PHASE B), AND BLUE (PHASE C). FOR 480Y/277V CIRCUITS, THE COLOR CODE SHALL BE BROWN (PHASE A), ORANGE (PHASE B), AND YELLOW (PHASE C). THE WIRE SHALL BE 12 AWG UNLESS OTHERWISE INDICATED. CIRCUIT SHALL BE LABELED IN EACH J-BOX.
2. WHERE ALUMINUM WIRE IS USED, ALUMINUM CONDUCTOR MATERIAL SHALL COMPLY WITH N.E.C. 310-14 AND CONNECTIONS AND TERMINATIONS SHALL BE MACHINE COMPRESSION TYPE EQUAL TO BURNDY "HI PLUG" OR "MACADAPT", NO EXCEPTIONS.
3. NO WIRE SHALL BE INSTALLED IN THE CONDUIT SYSTEM UNTIL THE CONDUIT SYSTEM IS COMPLETE. USE MINERALAC NO. 100 OR EQUIVALENT AS A LUBRICANT TO FACILITATE THE INSTALLATION OF THE CONDUCTORS IN THE CONDUIT SYSTEM.
4. SPLICES IN EXTERIOR PULL BOXES AND MANHOLES SHALL BE WEATHERPROOF USING "SCOTCHCAST" SPLICE KIT OR APPROVED EQUAL. SEAL ENDS OF CONDUITS AND DUCTS WITH "DUCTSEAL" OR APPROVED EQUAL.

5. PROVIDE SOLID CONDUCTOR FOR 12 AWG AND SMALLER.

G. WIRING DEVICES

1. WALL SWITCHES SHALL BE SPECIFICATION GRADE AC SILENT TYPE SWITCHES, 20A, 120/277 VOLT.
2. RECEPTACLES SHALL BE SPECIFICATION GRADE, DUPLEX TYPE, NEMA 5-20R, 20 AMPERE, 120 VOLT GROUND TYPE. SPECIAL APPLICATION RECEPTACLES SHALL BE INDICATED ON PLANS. MOUNT WITH THE GROUND DOWN.
3. DEVICE PLATES SHALL BE EQUAL TO SIERRA SMOOTH-LINE PLASTIC WALL PLATES. COLOR SHALL BE WHITE, UNLESS OTHERWISE NOTED.
4. RECEPTACLES IN OUTDOOR AND WET LOCATIONS SHALL BE INSTALLED WITH A HINGED OUTLET COVER/ENCLOSURE CLEARLY MARKED AND U.L. LISTED SUITABLE FOR WET LOCATIONS WHILE IN USE. EQUAL TO TAYMAC SPECIFICATION GRADE.
- H. LIGHTING FIXTURES
1. PROVIDE ALL LIGHTING FIXTURES, WIRED AND CONNECTED. THE DRAWINGS INDICATE THE FIXTURES FOR EACH LOCATION. PROVIDE LAMPS FOR FIXTURES. THE LAMPS SHALL BE BY THE SAME MANUFACTURER. VERIFY CEILING CONSTRUCTION BEFORE ORDERING RECESSED UNITS. PROVIDE PLASTER FRAMES AND HANGERS AS REQUIRED. CEILING CONSTRUCTION, ARCHITECTURAL ACCESSORIES, VOLTAGE, AND BALLASTS TO MEET THE EXISTING CONDITION.

J. SERVICE ENTRANCE SECTION

1. THE SERVICE ENTRANCE EQUIPMENT SHALL BE AS INDICATED ON THE DRAWINGS. EQUIPMENT SHALL CARRY THE U.L. LABEL AND SHALL CONFORM TO THE POWER COMPANY REGULATIONS.
2. SERVICE ENTRANCE EQUIPMENT SHALL BE PROVIDED WITH A FULLY RATED COPPER OR ALUMINUM BUS. HORIZONTALLY TAPERED BUSSING SHALL NOT BE ALLOWED.

K. SYSTEM GROUNDING

1. GROUNDING SHALL COMPLY WITH REQUIREMENTS OF ARTICLE 250. EXPOSED NONCURRENT CARRYING METALLIC PARTS OF ELECTRICAL EQUIPMENT, METALLIC RACEWAY SYSTEMS, METALLIC CABLE ARMOR, GROUNDING CONDUCTOR OF NONMETALLIC SHEATHED CABLES, GROUNDING CONDUCTOR IN NONMETALLIC RACEWAYS, AND GROUNDED CONDUCTORS OF THE WIRING SYSTEM SHALL BE GROUNDED.
2. GROUNDING CONDUCTOR (NEUTRAL) OF THE WIRING SYSTEM SHALL BE CONNECTED TO THE SYSTEM GROUNDING CONDUCTOR AT A SINGLE PLACE IN EACH SYSTEM BY REMOVABLE BONDING JUMPERS, SIZED ACCORDING TO THE APPLICABLE PROVISIONS OF THE NATIONAL ELECTRICAL CODE. THE GROUNDED CONDUCTOR (NEUTRAL) TO THE GROUNDING CONDUCTOR CONNECTION SHALL BE LOCATED IN THE ENCLOSURE FOR THE SYSTEMS OVERCURRENT PROTECTION OR WHERE OTHERWISE INDICATED ON THE PLANS OR SPECIFICATIONS.
3. A GROUND BUS SEPARATE FROM THE NEUTRAL BUS SHALL BE PROVIDED IN ALL SWITCHBOARDS AND PANELBOARDS. GROUND BUS SHALL BE RETORQUED (CHECKED) PRIOR TO ENERGIZING EQUIPMENT PER MANUFACTURER'S RECOMMENDATIONS.
4. GROUND BUSES AND NEUTRAL BUSES IN DISTRIBUTION PANELS, SWITCHBOARDS, PANELBOARDS, AND THOSE PROVIDED IN ANY EQUIPMENT SHALL BE ISOLATED EXCEPT WHERE REQUIRED TO BE CONNECTED AS SPECIFIED ABOVE FOR THE SERVICE ENTRANCE AND IN TRANSFORMER TERMINAL COMPARTMENTS.
5. WHEN INDICATED ON THE DRAWINGS, EQUIPMENT GROUNDING CONDUCTORS SHALL BE EXTENDED FROM THE GROUND BUS IN THE DISTRIBUTION EQUIPMENT TO THE RECEPTACLE FIXTURE OR DEVICE LUGS WHERE THEY ARE PROVIDED. WHERE LUGS ARE NOT PROVIDED, EQUIPMENT GROUNDING CONDUCTORS SHALL BE CONNECTED TO EQUIPMENT ENCLOSURES. THE CONNECTIONS SHALL BE ARRANGED SUCH THAT REMOVAL OF THE RECEPTACLE, EQUIPMENT GROUND CONDUCTORS, OR GROUND JUMPERS FROM GROUND BUSSING SHALL NOT AFFECT THE GROUND SYSTEM.
6. RACEWAYS MAY NOT BE USED AS A GROUNDING CONDUCTOR FOR POWER AND LIGHTING CIRCUITS. CONDUIT SHALL HAVE SEPARATE CODE SIZED GREEN GROUND WIRE INSTALLED IN THE CONDUIT TO INSURE A CONTINUOUS GROUNDING PATH.
7. IN INACCESSIBLE LOCATIONS, MAKE CONNECTIONS BY EXOTHERMIC WELD PROCESS.
8. IN ACCESSIBLE LOCATIONS, CONNECTIONS SHALL BE MADE WITH BOLTED THROUGH, APPROVED SOLDERLESS BRONZE GROUNDING DEVICES.
9. BOND TOGETHER METAL SIDING NOT ATTACHED TO GROUNDED STRUCTURE BOND TO GROUND.
- L. TELEPHONE SYSTEM
1. TELEPHONE WALL OUTLETS SHALL CONSIST OF STANDARD BOXES MOUNTED 18" ABOVE THE FLOOR UNLESS OTHERWISE INDICATED. CONNECT OUTLETS TO TELEPHONE TERMINAL WITH SEPARATE 3/4" CONDUIT UNLESS OTHERWISE SHOWN ON DRAWINGS. PROVIDE A TERMINAL MOUNTING BOARD FOR THE INCOMING SERVICE CABLE.

M. LIGHTING CONTROL

1. FURNISH AND INSTALL TIME SWITCHES, PHOTOCELLS, CONTACTORS AND FULL LIGHTING CONTROL SYSTEMS AS REQUIRED FOR LIGHTING CONTROLS INDICATED ON THE DRAWINGS.
2. TIME SWITCHES SHALL BE EQUAL TO PARAGON, GENERAL ELECTRIC, TORK, OR INTERMATIC AND SHALL HAVE SIZE AND NUMBER OF POLES AS REQUIRED.
3. PHOTOCELLS SHALL BE EQUAL TO TORK OR INTERMATIC WITH VOLTAGE AS INDICATED.

N. DRY TYPE TRANSFORMERS

1. MANUFACTURERS: SUBJECT TO COMPLIANCE WITH REQUIREMENTS, PROVIDE PRODUCTS BY ONE OF THE FOLLOWING:
- a. ACME ELECTRIC CORPORATION: POWER DISTRIBUTION PRODUCTS DIVISION.
GE ELECTRICAL DISTRIBUTION & CONTROL.
c. CUTLER-HAMMER.
d. SQUARE D/GROUPE SCHNEIDER NA.
2. CONTINUOUS WINDINGS WITHOUT SPLICES, EXCEPT FOR TAPS.
- a. INTERNAL COIL CONNECTIONS - BRAZED OR PRESSURE TYPE.
b. COIL MATERIAL - COPPER
3. ENCLOSURE - VENTILATED, NEMA 250, TYPE 2 (NEMA 3R FOR OUTDOOR INSTALLATIONS).
4. INSULATION CLASS - 220 DEG C, UL-COMPONENT-RECOGNIZED INSULATION SYSTEM WITH A MAXIMUM OF 150 DEG C RISE ABOVE 40 DEG C AMBIENT TEMPERATURE.
5. TAPS FOR TRANSFORMERS 25 KVA AND LARGER - TWO 2.5 PERCENT TAPS ABOVE AND FOUR 2.5 PERCENT TAPS BELOW NORMAL FULL CAPACITY.
6. WALL BRACKETS - MANUFACTURER'S STANDARD BRACKETS.
7. LOW-SOUND-LEVEL-REQUIREMENTS - MINIMUM OF 3 DBA LESS THAN NEMA ST 20 STANDARD SOUND LEVELS WHEN FACTORY TESTED ACCORDING TO IEEE C57.12.91.

O. GUARANTEE

1. GUARANTEE MATERIAL FURNISHED AND WORKMANSHIP PERFORMED FOR A PERIOD OF ONE YEAR FROM DATE OF FINAL ACCEPTANCE OF WORK. ANY DEFECTS DEVELOPING WITHIN THIS PERIOD, TRACEABLE TO MATERIAL FURNISHED AS A PART OF THIS SECTION OR WORKMANSHIP PERFORMED HEREUNDER, SHALL BE MADE GOOD AT NO EXPENSE TO THE OWNER.

P. SHOP DRAWINGS AND APPROVALS

1. THE ITEMS SPECIFIED HEREIN AND ON DRAWINGS ARE USED AS A STANDARD OF QUALITY. ANY MATERIALS OF EQUAL QUALITY AND AESTHETIC VALUE WILL BE GIVEN CONSIDERATION AS A SUBSTITUTE FOR THE MATERIALS SPECIFIED. NO APPROVAL WILL BE GIVEN TO A SPECIFIC CATALOG NUMBER, MODEL, OR TYPE OF EQUIPMENT, PRIOR TO BIDDING. AFTER BIDDING, THE DECISION OF THE ARCHITECT AND/OR ENGINEER DETERMINING EQUAL MATERIALS WILL BE FINAL.
2. THE CONTRACTOR SHALL SUBMIT SEVEN (7) IDENTICAL BOUND SETS OF SHOP DRAWINGS ON THE FOLLOWING ITEMS:
- a. LIGHTING FIXTURE CUTS AND PERFORMANCE DATA.
b. OUTLINE DRAWINGS AND DATA SHEETS OF EACH PANELBOARD AND SWITCHBOARD.
c. OUTLINE DRAWINGS OF ALL SWITCHGEAR.
3. SUBMIT ITEMS AT ONE TIME IN A NEAT AND ORDERLY MANNER WITHIN 15 DAYS OF AWARD OF CONTRACT. PARTIAL SUBMITTALS WILL NOT BE ACCEPTABLE.


Q. RECORD AND AS-BUILT DRAWINGS

1. THE ELECTRICAL CONTRACTOR SHALL MAINTAIN A SET OF DRAWINGS AT THE JOB SITE FOR THE EXCLUSIVE PURPOSE OF MAINTAINING A RECORD OF WORK INSTALLED AND TO SHOW ANY DEVIATIONS FROM THE WORK INDICATED ON THE DRAWINGS.
2. AT THE COMPLETION OF THE PROJECT, ONE SET OF REPRODUCIBLE DRAWINGS, SHOWING AS-BUILT CONDITIONS, SHALL BE DELIVERED TO THE OWNER FOR ACCEPTANCE PRIOR TO FINAL PAYMENT.


R. COORDINATION STUDY & ARC FLASH REQUIREMENTS

1. THE ELECTRICAL CONTRACTOR MUST HIRE AN INDEPENDENT THIRD PARTY TO PERFORM A COORDINATION STUDY FOR THIS SCOPE OF WORK TO MEET HCAI PIN 70 REQUIREMENTS. THE COORDINATION STUDY SHALL BE PERFORMED BEFORE THE ENGINEER HAS APPROVED THE SHOP DRAWINGS AND A MANUFACTURE HAS BEEN SELECTED. THE STUDY MUST BE PRESENTED TO THE ENGINEER AND OWNER FOR REVIEW TO ENSURE THE ENTIRE ELECTRICAL SYSTEM IS PROPERLY COORDINATED.
2. ARC FLASH REQUIREMENTS:
- a. PROVIDE AN ARC FLASH EVALUATION FOR THE NEW ELECTRICAL EQUIPMENT. PERFORM ALL CALCULATIONS AND WORK WITH COMMERCIALY AVAILABLE COMPUTER SOFTWARE IN ACCORDANCE WITH IEEE STD. 1584-2002 IEEE GUIDE FOR PERFORMING ARC-FLASH HAZARD CALCULATIONS, NFPA 70-2009 (NEC), AND NFPA 70E-2009 STANDARD FOR ELECTRICAL SAFETY IN THE WORKPLACE.
- b. WHERE THE CALCULATIONS DETERMINE THAT THE SETTINGS RESULT IN PROHIBITIVE INCIDENT ENERGY LEVELS (>40 CAL/CM2) THE CONTRACTOR SHALL PROVIDE RECOMMENDED SETTINGS OR OTHER MITIGATION RECOMMENDATIONS TO REDUCE THE INCIDENT ENERGY TO A LEVEL WHERE ENERGIZED WORK IS CAPABLE OF BEING PERFORMED. THE CONTRACTOR SHALL DOCUMENT THE RECOMMENDED CHANGES AND PROVIDED TIME CURRENT CURVES INDICATING THE COORDINATION THAT REFLECTS THE RECOMMENDED SETTINGS.
- c. PROVIDE LABELS FOR EACH ELECTRICAL ENCLOSURE OR EQUIPMENT WHERE WORKERS COULD BE EXPOSED TO ENERGIZED CONDUCTORS. THESE LABELS SHALL COMPLY WITH THE REQUIREMENTS OF NFPA 70E-2009 AND INCLUDE BUT NOT LIMITED TO:
1. VOLTAGE PHASE TO PHASE
2. FLASH PROTECTION BOUNDARY (INCHES)
3. INCIDENT ENERGY AT THE WORKING DISTANCE(CAL/CM2)
4. PPE CLASS AND DESCRIPTION (INCLUDING GLOVE RATING)
5. RESTRICTED APPROACH BOUNDARY (INCHES)
6. LIMITED SHOCK PPROACH BOUNDARY (INCHES)
7. PROHIBITED SHOCK APPROACH BOUNDARY (INCHES)
8. LOCATION IDENTIFICATION

APPROVAL

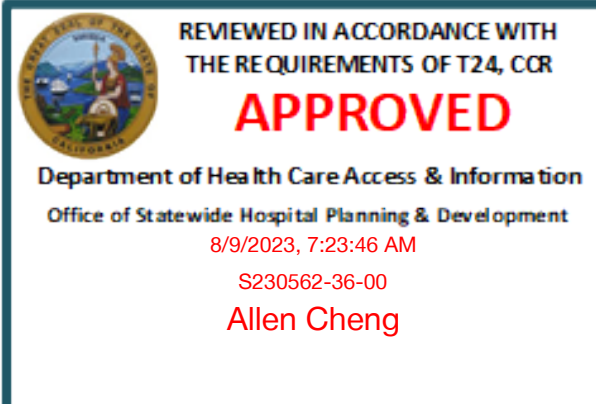

CLIENT

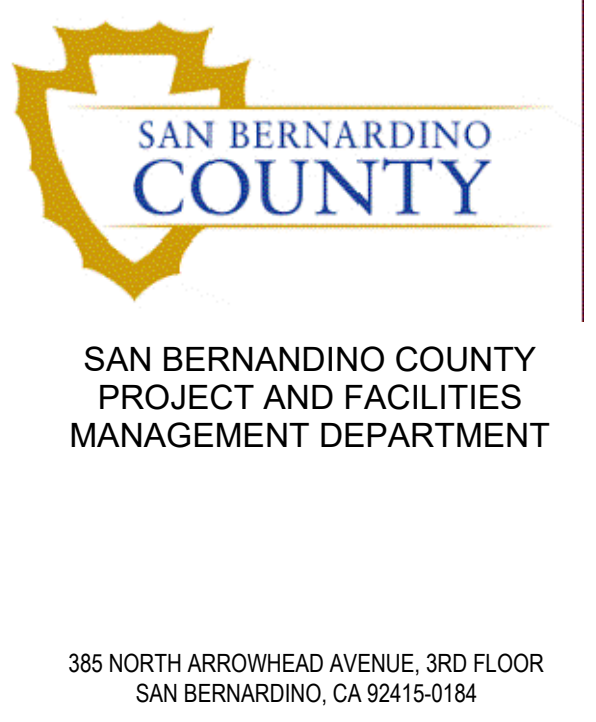

PROJECT NAME


ARMC DEAEERATOR #1 REPLACEMENT

PROJECT NO.
WBSE # 10.10.0847
CIP # 20-011
HCAI #
FACILITY NO.
17282
BUILDING NO.
BLD-00075 CENTRAL PLANT
400 N. PEPPER AVENUE
COLTON, CA 92324-1801

ENGINEER/ARCHITECT



STAMP

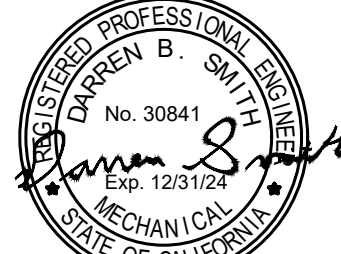

STAMP



DATE SIGNED 04/18/23

ISSUE

REV.	DESCRIPTION	DATE
	HCAI SUBMITTAL	04/28/23
A	BACK CHECK #1	06/16/23
B	BACK CHECK #2	07/28/23

PROJECT IDENTIFICATION

THIS DRAWING WAS CREATED IN AUTODESK AUTOCAD V. 2021 UNLESS OTHERWISE NOTED.
THE ORIGINAL SIZE OF THIS SHEET IS 30" X 42"
THESE DRAWINGS AND SPECIFICATIONS ARE THE PROPERTY AND COPYRIGHT OF IDS GROUP AND SHALL NOT BE USED ON ANY OTHER PROJECT OR LOCATIONS EXCEPT AS DESCRIBED ON THE DRAWINGS, WITHOUT THE WRITTEN AGREEMENT WITH IDS GROUP.

IDS PROJECT NO.	22X066.02
DRAWN BY	AL
CHECKED BY	RP
APPROVED BY	MO

SHEET TITLE

SPECIFICATIONS

SHEET NUMBER

E-002

SHEET NO. 2

OF

PLAN CHECK - NOT FOR CONSTRUCTION

EXISTING MOTOR CONTROL CENTER CP-EMCC2 - FEEDER SCHEDULE AND CALCULATIONS																					
NAME	PF	LOAD				FEEDERS						EST. DIST.	REMARKS	VOLTAGE DROP CALCULATIONS				AFC CALCULATIONS			
		VOLTS	Ø	CONNECTED		DEMAND KVA	AMPS	#	CONDUITS		WIRE PER CONDUIT			GND PER CONDUIT	FEEDER SEGMENT DROP ONLY		NET DROP AT DEVICE		AFC FROM SOURCE	MOTOR CONTR. BUTION	NET AFC AT DEVICE
				HP	KVA				#	SIZE					#	SIZE	VOLTS DROP	%			
(E) LOAD ANALYSIS																					
SECTION 1 - 1200AMP																					
(E) HHWP-7	1.00	480	3			184	221										40,000	648	40,648		
(E) CIR-5	1.00	480	3					F01													
(E) CIR-6	1.00	480	3					F02													
(E) CIR-7	1.00	480	3					F03													
(E) CIR-8	1.00	480	3					F04													
SECTION 2 - 600AMP																					
(E) CIR-9	1.00	480	3					F05													
(E) CIR-10	1.00	480	3					F06													
(E) SPARE								F07													
(E) DE-1	1.00	480	3					F08													
(E) DE-2	1.00	480	3					F09													
(D) MDFF-1	1.00	480	3			6	8	F10													
(E) HHWP-3	1.00	480	3					F011	1	3/4"	3	#12	#14	120	2.69	0.6%	2.69	0.6%	40,648	1,377	
SECTION 3 - 800AMP																					
(E) CRT-SA	1.00	480	3					F012													
(D) MBFP-1	1.00	480	3			43	52	F013	1	1 1/4"	3	#3	#8	130	2.81	0.6%	2.81	0.6%	40,648	8,120	
(D) MBFP-2	1.00	480	3			43	52	F014	1	1 1/4"	3	#3	#8	130	2.81	0.6%	2.81	0.6%	40,648	8,120	
(E) HHWP-2	1.00	480	3					F015	1	1 1/4"	3	#3	#8	130	2.81	0.6%	2.81	0.6%	40,648	8,120	
SECTION 4 - 600AMP																					
(E) CRT-SB	1.00	480	3					F016													
(D) MDFF-2	1.00	480	3			6	8	F017													
(E) B-1	1.00	480	3					F018	1	3/4"	3	#12	#14	120	2.69	0.6%	2.69	0.6%	40,648	1,377	
(E) B-2	1.00	480	3					F019													
(E) HHWP-1	1.00	480	3					F020													
SECTION 5 - 300AMP																					
(E) B-3	1.00	480	3					F021													
(E) SPARE	1.00	480	3					F022													
(D) MBFP-3 (STANDBY)	1.00	480	3			43	52	F023													
(E) SPARE	1.00	480	3					F024	1	1 1/4"	3	#3	#8	130	2.81	0.6%	2.81	0.6%	40,648	8,120	
(E) TEMP AIR COMPRESSOR	1.00	480	3			42	50	F025	1	1 1/2"	3	#2	#8	180	3.12	0.6%	3.12	0.6%	40,648	7,431	


NEW MOTOR CONTROL CENTER CP-EMCC2 - FEEDER SCHEDULE AND CALCULATIONS																							
NAME	PF	LOAD				FEEDERS						EST. DIST.	REMARKS	VOLTAGE DROP CALCULATIONS				AFC CALCULATIONS					
		VOLTS	Ø	CONNECTED		DEMAND KVA	AMPS	#	CONDUITS		WIRE PER CONDUIT #			SIZE	GND PER CONDUIT SIZE	FEEDER SEGMENT DROP ONLY		NET DROP AT DEVICE		AFC FROM SOURCE	MOTOR CONTR. BUTION	NET AFC AT DEVICE	
				HP	KVA				#	SIZE						%	VOLTS DROP	%	VOLTS DROP				%
(N) LOAD ANALYSIS																							
SECTION 1 - 1200AMP																							
(E) HHWP-7	1.00	480	3			184	221											40,000	648	40,648			
(E) CIR-5	1.00	480	3																				
(E) CIR-6	1.00	480	3																				
(E) CIR-7	1.00	480	3																				
(E) CIR-8	1.00	480	3																				
SECTION 2 - 600AMP																							
(E) CIR-9	1.00	480	3																				
(E) CIR-10	1.00	480	3																				
(E) SPARE																							
(E) DE-1	1.00	480	3																				
(E) DE-2	1.00	480	3																				
(E) SPARE	1.00	480	3																				
(E) HHWP-3	1.00	480	3																				
SECTION 3 - 800AMP																							
(E) CRT-SA	1.00	480	3																				
(N) DA/ST-1	1.00	480	3			142	171			1	2 1/2"	3	4/0	#6	130		3.08	0.6%	3.08	0.6%	40,648		17,952
(N) SPARE	1.00	480	3																				
(E) HHWP-2	1.00	480	3																				
SECTION 4 - 600AMP																							
(E) CRT-SB	1.00	480	3																				
(E) SPARE	1.00	480	3																				
(E) B-1	1.00	480	3																				
(E) B-2	1.00	480	3																				
(E) HHWP-1	1.00	480	3																				
SECTION 5 - 300AMP																							
(E) B-3	1.00	480	3																				
(E) SPARE	1.00	480	3																				
(E) SPARE	1.00	480	3																				
(E) SPARE	1.00	480	3																				
(N) TEMP-1	1.00	480	3			42	50			1	1 1/2"	3	#2	#8	180		3.12	0.6%	3.12	0.6%	40,648		7,431

THE ESSENTIAL ELECTRICAL SYSTEM HAS BEEN EVALUATED FOR COORDINATION AND THE ESSENTIAL ELECTRICAL SYSTEM WILL MEET THE COORDINATION REQUIREMENTS OF THE CEC ARTICLE 517.



SIGNATURE:

Steven M. Collins

STEVEN M. COLLINS - ELECTRICAL ENGINEER OF RECORD
P.E. #E22808; EXPIRATION 06-30-2023

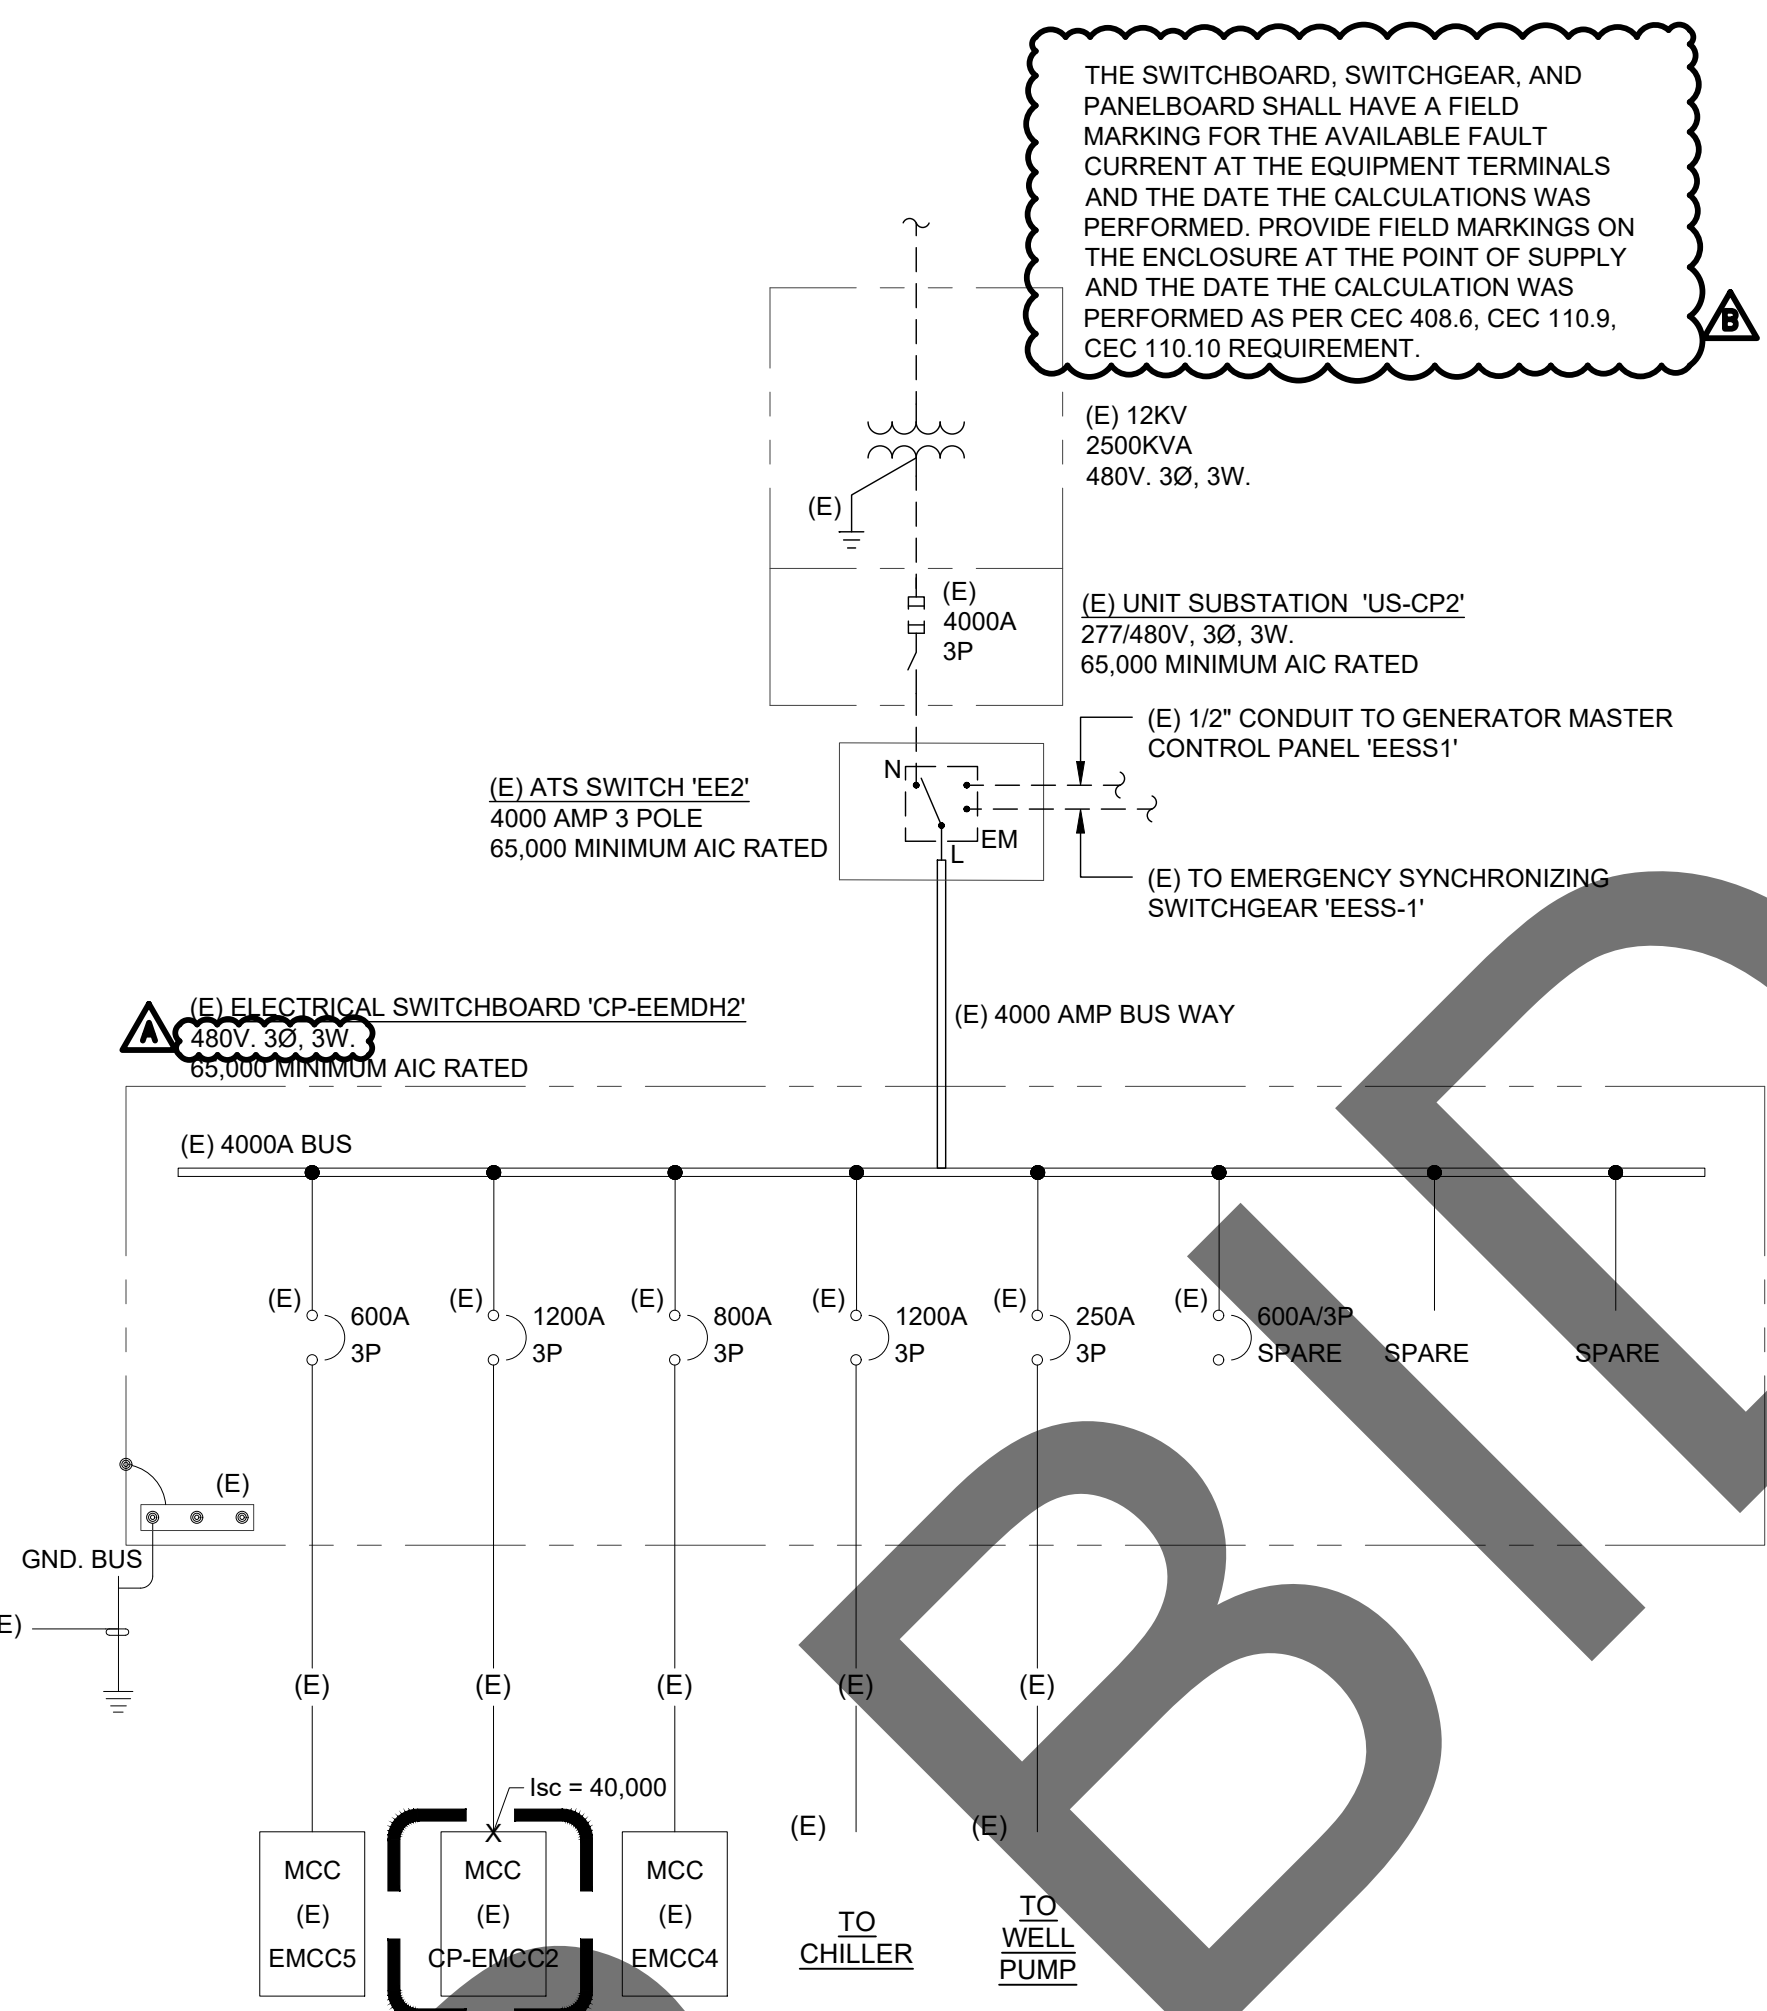

SCOPE OF WORK

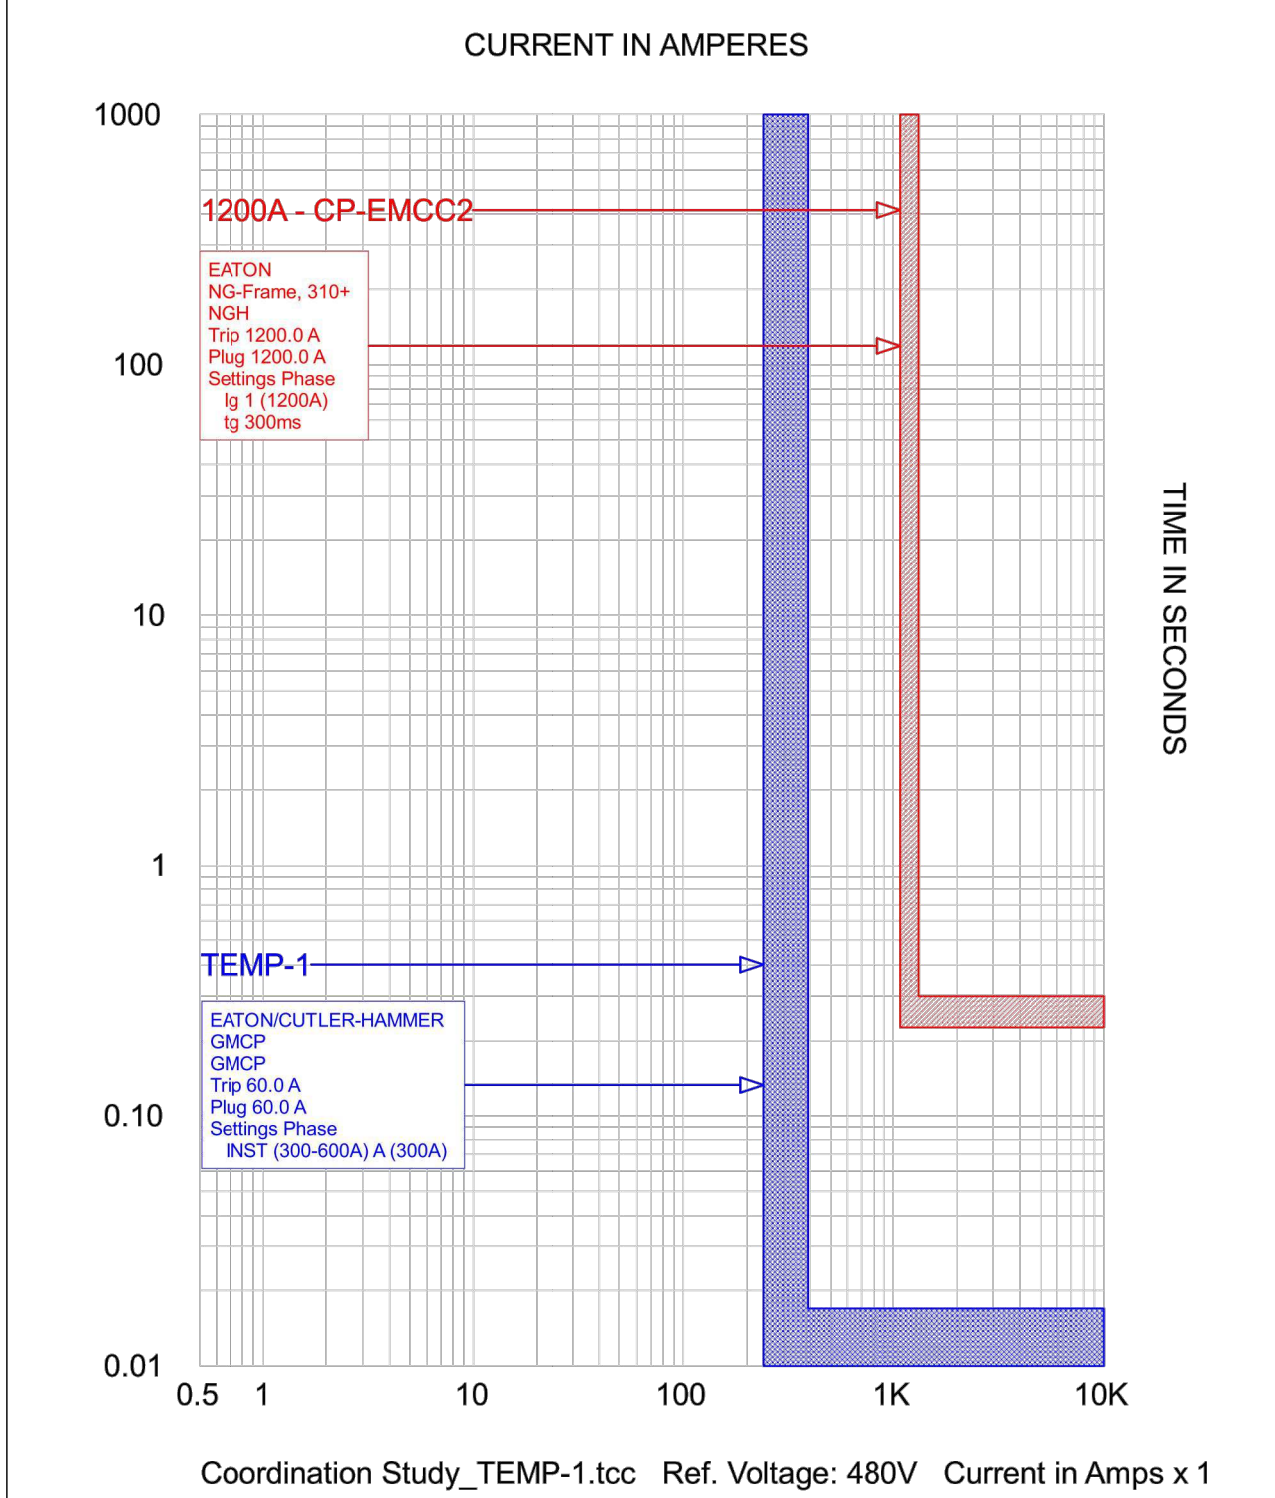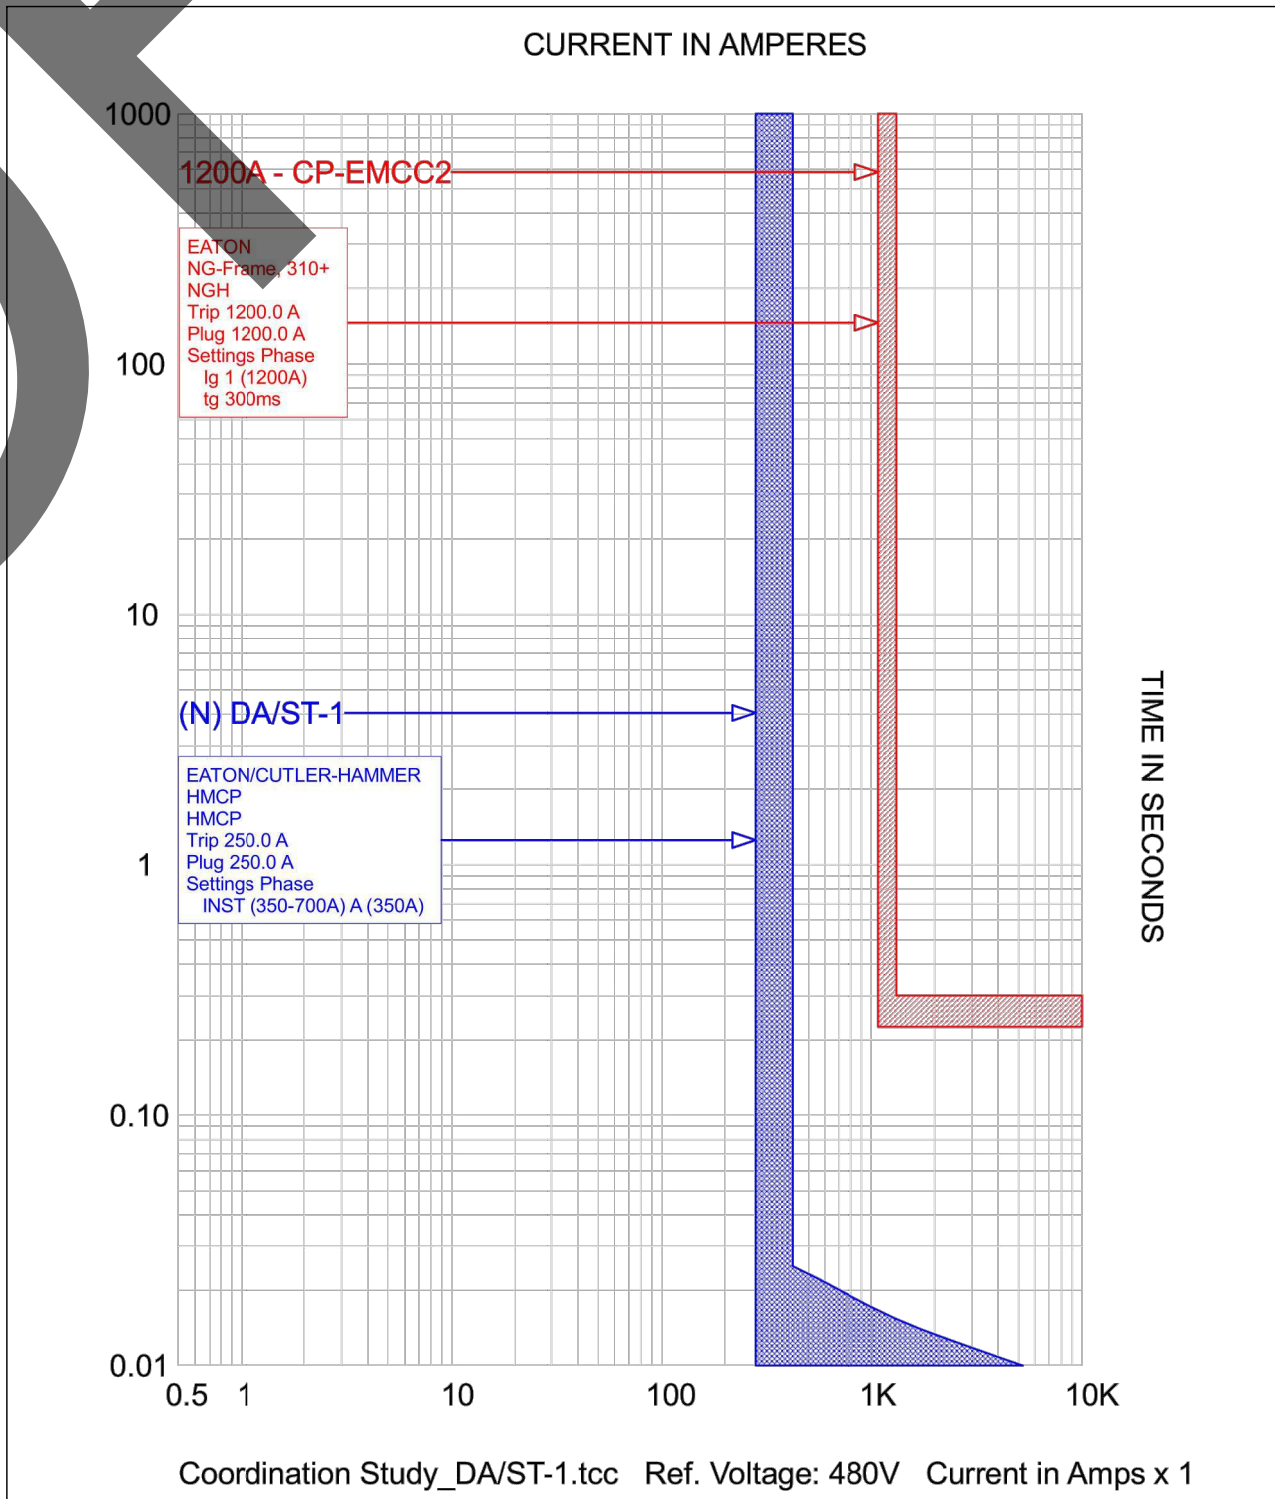

EXISTING SINGLE LINE DIAGRAM

NO SCALE

1

SINGLE LINE GENERAL NOTES

- THE DESIGN PROFESSIONAL HAS PERFORMED REQUIRED SHORT CIRCUIT CALCULATIONS AND THE AIC RATING INDICATED FOR EACH DEVICE IS ADEQUATE TO PROTECT THE EQUIPMENT AND THE ELECTRICAL SYSTEM.
- THE DESIGN PROFESSIONAL HAS PERFORMED ALL REQUIRED VOLTAGE DROP CALCULATIONS AND BRANCH CIRCUITS AND FEEDERS COMPLY WITH NEC 210-19(A) FPN NO. 4.
- FAULT CURRENT CALCULATIONS ASSUME UTILITY PROVIDED KVA UTILITY TRANSFORMER WITH A OF AVAILABLE FAULT CURRENT LOCATED FEET FROM MAIN SWITCHBOARD. REFER TO POWER UTILITY DRAWINGS FOR EXACT SIZE AND LOCATION. NOTIFY ENGINEER IN WRITING IF TRANSFORMER SIZE IS INCREASED OR DISTANCE IS DECREASED.
- EACH SERVICE DISCONNECTING MEANS, AND THE EXTERIOR DOOR PROVIDING ACCESS TO THE DISCONNECTING MEANS, LOCATED IN AN APPROVED ELECTRICAL ROOM, SHALL BE PERMANENTLY MARKED WITH A 1 FOOT SQUARE YELLOW SIGN WITH 1" HIGH X 1/4" STROKE BLACK LETTERING OR NUMBERS AS REQUIRED BY CODE AND THE AUTHORITY HAVING JURISDICTION.

GENERAL NOTES

- OVERCURRENT DEVICES IN AN INDIVIDUAL PIECE OF EQUIPMENT SHALL HAVE AN AIC RATING EQUAL TO THE OVERALL RATING OF THE EQUIPMENT - SERIES RATING OF DEVICES WITHIN A PIECE OF EQUIPMENT IS NOT ALLOWED.
- SERIES CONNECTED DEVICES SHALL HAVE BEEN INVESTIGATED BY UL IN COMBINATION WITH THE END USE EQUIPMENT, AND THE EQUIPMENT IN WHICH THESE DEVICES ARE USED SHALL BE MARKED WITH THE SERIES CONNECTED RATING. EQUIPMENT SHALL BE MARKED IN ACCORDANCE WITH NEC REQUIREMENTS.
- TERMINATIONS AND ENCLOSURES SHALL BE RATED FOR USE WITH 75 DEGREE CELSIUS CONDUCTORS.
- SERVICE ENTRANCE EQUIPMENT, SWITCHBOARDS, DISTRIBUTION BOARDS, AND PANELBOARDS RATED AT 400 AMPS OR GREATER, SHALL BE PROVIDED WITH A MAIN OVERCURRENT DEVICE AND BUSSING RATED AT 100% CONTINUOUS OPERATION.
- BRANCH OR FEEDER CIRCUIT OVER-CURRENT DEVICES RATED AT 400 AMPS OR HIGHER SHALL BE RATED FOR 100% CONTINUOUS OPERATION.
- CONTRACTOR SHALL SUBMIT SWITCHBOARD SHOP DRAWINGS TO THE SERVING UTILITY FOR APPROVAL PRIOR TO FABRICATION. CONTRACTOR SHALL SECURE CONFIRMATION THAT THE PROPOSED SWITCHBOARD COMPLIES WITH THE POWER COMPANY REGULATIONS.
- BUSSING:
 - BUSSING SHALL BE COPPER OR ALUMINUM IN CONSTRUCTION. MAIN HORIZONTAL AND VERTICAL BUSSING SHALL BE FULL CAPACITY IN SWITCHBOARD SECTIONS.
 - HORIZONTAL AND VERTICAL BUSSING SHALL BE FULL LENGTH. BUSSING SHALL HAVE A MINIMUM WITHSTAND RATING EQUAL TO THE AVAILABLE FAULT CURRENT INDICATED, BUT IN NO CASE SHALL THE RATING BE LESS THAN 65,000 AMPS, SYMMETRICAL.
- GROUND FAULT RELAY SETTINGS:
 - TO MINIMIZE NUISANCE TRIPPING OF THE MAIN AND FEEDER BREAKER, THE CONTRACTOR SHALL ADJUST THE GROUND FAULT RELAY SETTINGS FOR THE GFT DEVICES TO BE HIGHER THAN DOWNSTREAM GFT AND NON-GFT DEVICES. THE GROUND FAULT CURRENT PICK-UP AND TIME DELAY SETTINGS SHALL BE ADJUSTED, PER THE MANUFACTURERS RECOMMENDATIONS, RESULTING FROM A CONTRACTOR/MANUFACTURER PREPARED COORDINATION STUDY - WHICH SHALL BE DOCUMENTED IN THE SHOP DRAWING SUBMITTAL.
 - DURING THE CONSTRUCTION PHASE OF THE PROJECT, GROUND FAULT RELAYS SHALL BE SET AT THE SHORTEST AVAILABLE TIME DELAY.
- AFTER SETTINGS HAVE BEEN ADJUSTED, THE CONTRACTOR SHALL HAVE THE GROUND FAULT SYSTEM TESTED BY AN INDEPENDENT TESTING AGENCY PER NEC 230-95 (C). THIS TEST SHALL BE PERFORMED IN THE PRESENCE OF THE LOCAL AUTHORITY HAVING JURISDICTION AND THE TEST RESULTS SHALL BE DELIVERED TO THE ENGINEER OF RECORD.
- DRY TYPE TRANSFORMERS:
 - DRY TYPE TRANSFORMERS OVER 112-1/2KVA SHALL HAVE A MINIMUM CLASS 155 INSULATION RATING SYSTEM.
 - DRY TYPE TRANSFORMERS SHALL BE COMPLETELY ENCLOSED EXCEPT FOR VENTILATED OPENINGS.

KEY NOTES

- CONTRACTOR TO PROVIDE A 400 AMP RATED SWITCH PER EXISTING MANUFACTURE MCC REQUIREMENTS. CONTRACTOR TO VERIFY WITH MANUFACTURE PROPER SWITCH CONFIGURATION AND PART NUMBER TO EXISTING MCC TO PROVIDE PROPER INSTALLATION PER NEW DEARATOR REQUIREMENTS.
- TEMP-1 EQUIPMENT WILL BE DE-ENERGIZED ONCE NEW DA/ST-1 IS INSTALLED AND IS READY TO COME ONLINE. ALL TEMPORARY ELECTRICAL CONNECTION AND LOADING WILL BE COMPLETELY REMOVED.

APPROVAL



CLIENT



385 NORTH ARROWHEAD AVENUE, 3RD FLOOR
SAN BERNARDINO, CA 92415-0184

PROJECT NAME

**ARMC
DEARATOR #1
REPLACEMENT**

PROJECT NO.

WESE # 10.10.0847

CIP # 20-011

HCAI #

FACILITY NO.

17282

BUILDING NO.

BLD-00075 CENTRAL PLANT


400 N. PEPPER AVENUE
COLTON, CA 92324-1801

ENGINEER/ARCHITECT



1 PETERS CANYON ROAD, SUITE 130
IRVINE, CA 92606
TEL: 949-387-6500, FAX: 949-387-0800

STAMP

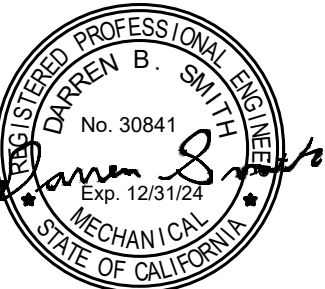


STAMP



DATE SIGNED 04/18/23

ISSUE

REV.	DESCRIPTION	DATE
	HCAI SUBMITTAL	04/28

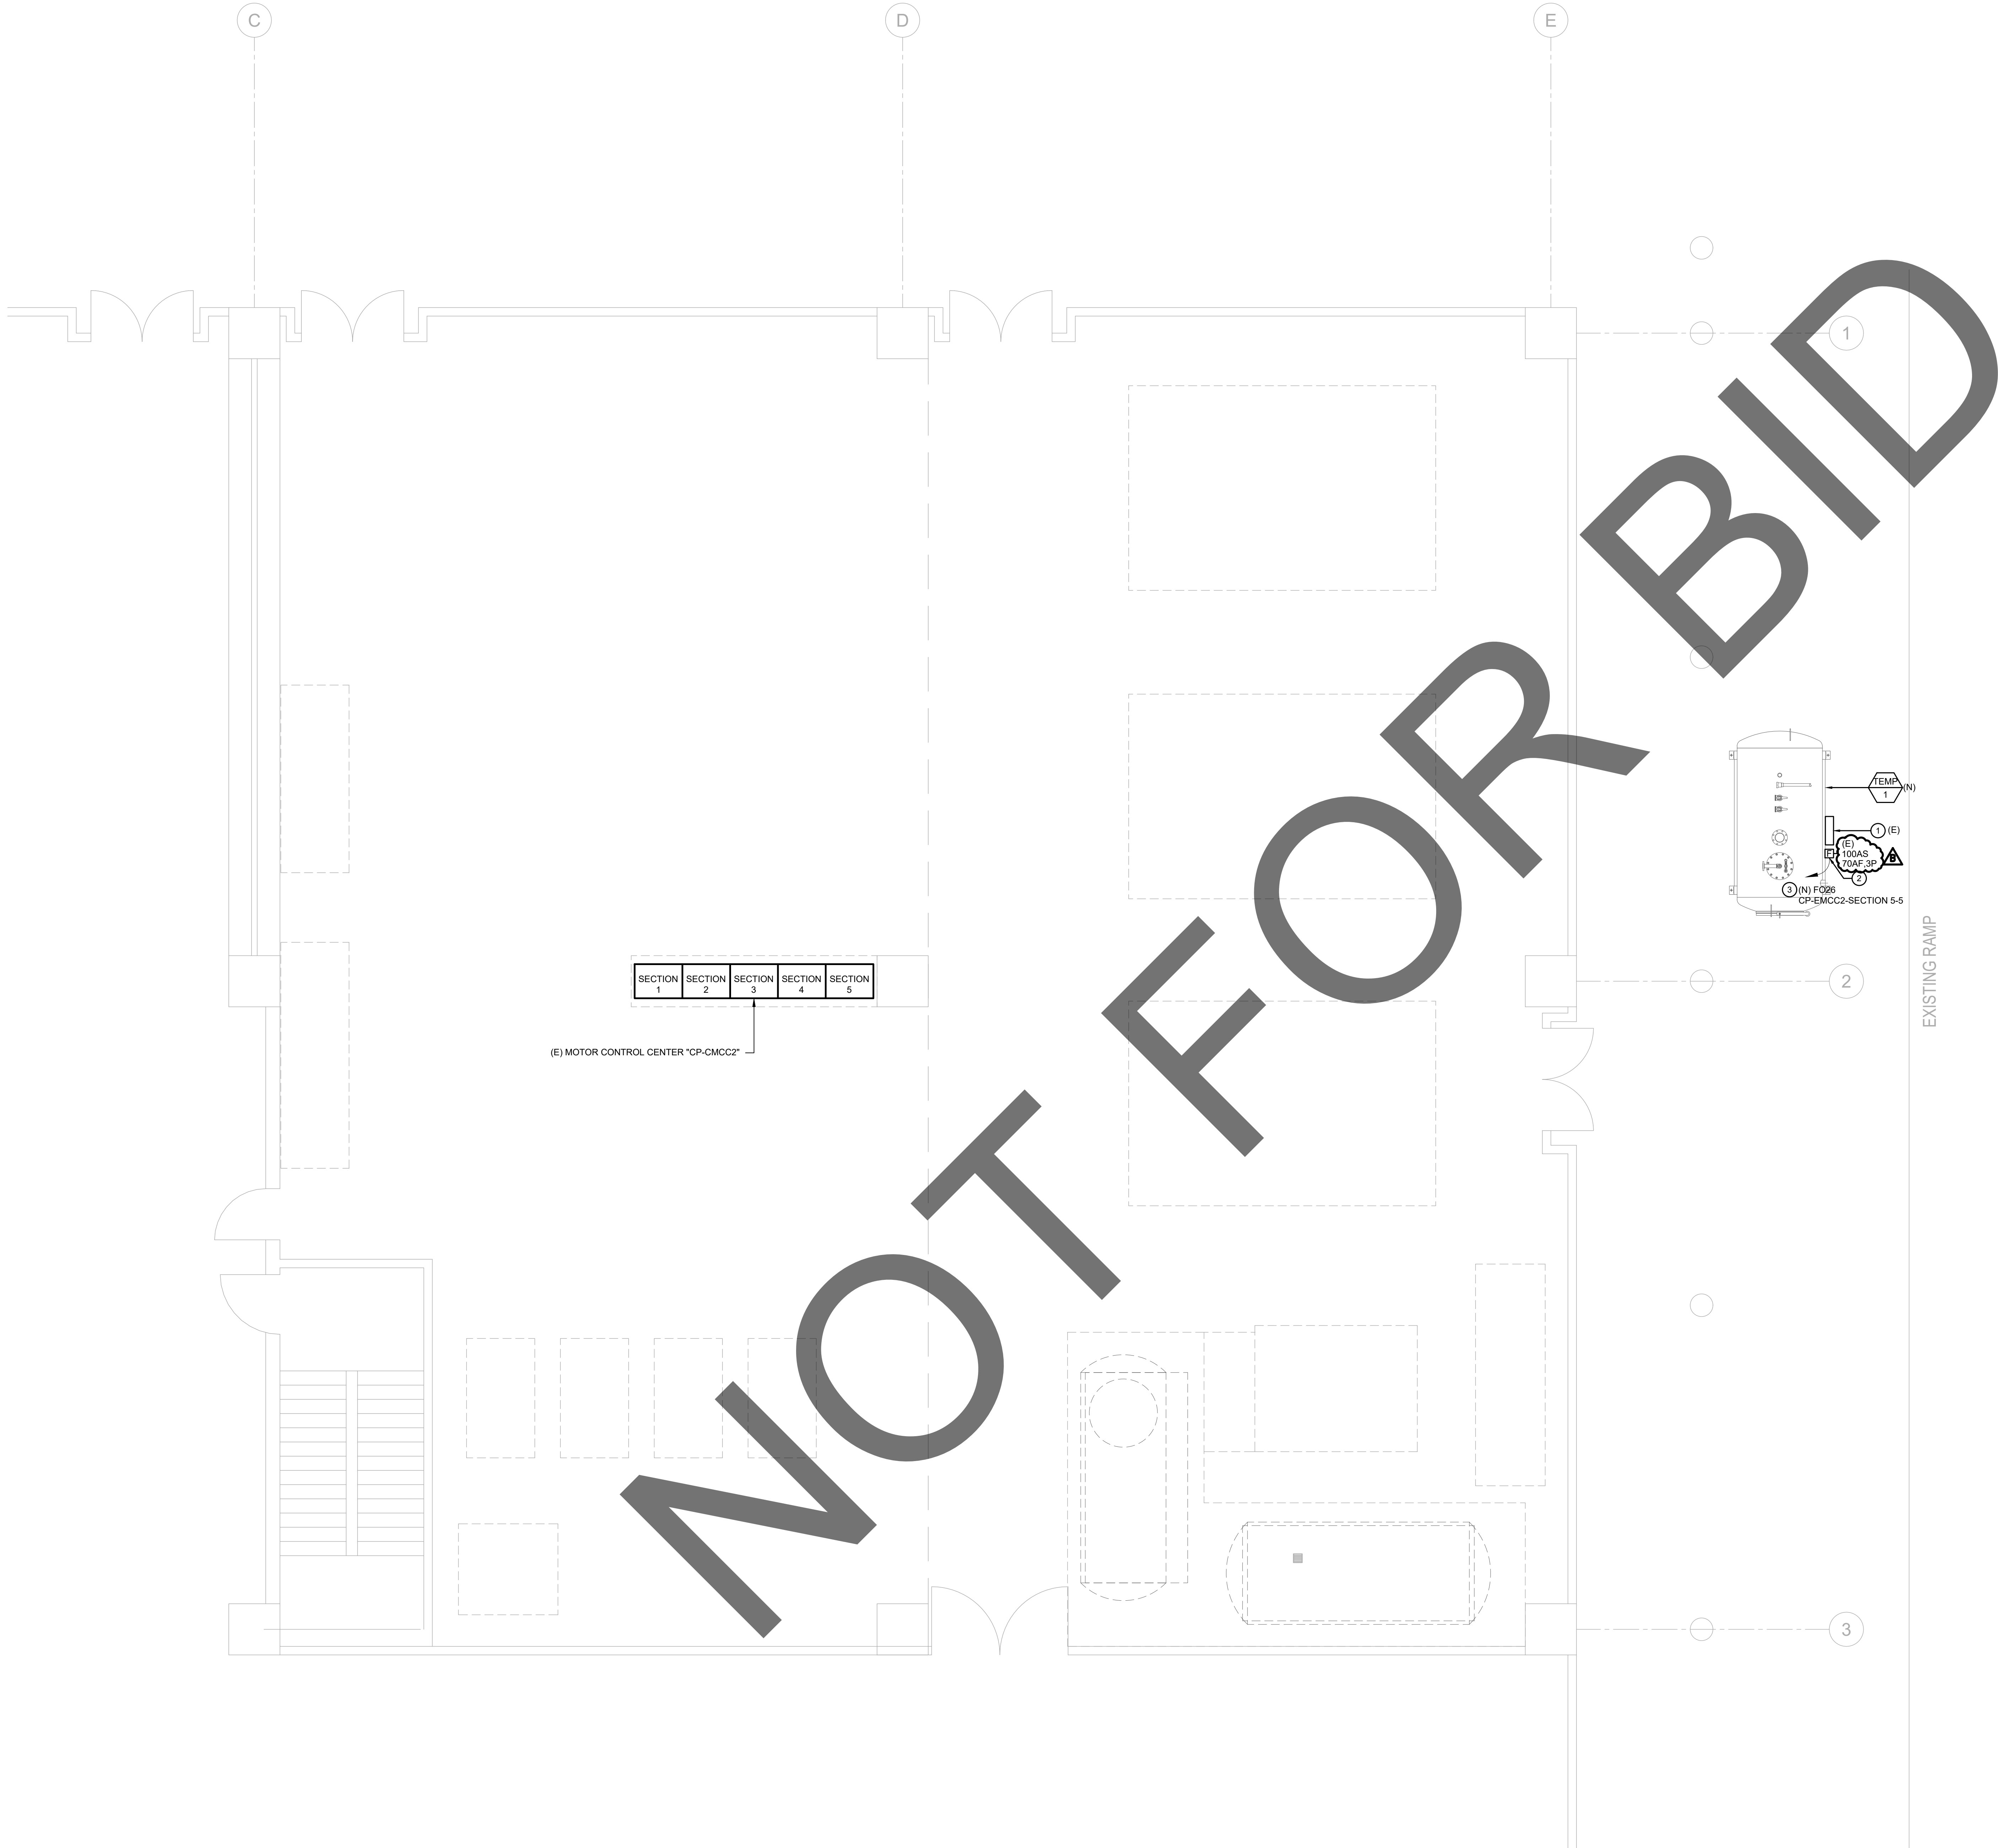

- KEYNOTES
- 1 EXISTING TEMPORARY STEAM BOILER CONTROL PANEL LOCATED ON EQUIPMENT.
 - 2 EXISTING PER MANUFACTURE EQUIPMENT DISCONNECT SWITCH. VERIFY EXACT LOCATION PRIOR TO ROUGH-IN.
 - 3 PROVIDE NEW TEMPORARY CONNECTION FROM MECHANICAL EQUIPMENT TEMP-1 TO EXISTING MCC "CP-CMCC2" SECTION 5. SPACE 5 AS REQUIRED FOR TEMP POWER. VERIFY EXACT LOCATION AND REQUIREMENTS OF EQUIPMENT PRIOR TO ROUGH-IN. REFER TO SINGLE LINE DIAGRAM SHEET 1 FOR FEEDER AND CONDUIT SIZING.



CLIENT

SAN BERNARDINO COUNTY
PROJECT AND FACILITIES
MANAGEMENT DEPARTMENT

385 NORTH ARROWHEAD AVENUE, 3RD FLOOR
SAN BERNARDINO, CA 92415-0184

PROJECT NAME

**ARMC
DEAERATOR #1
REPLACEMENT**

PROJECT NO.
WBSE # 10.10.0847
CIP # 20-011
HCAI #

FACILITY NO.
17282


BUILDING NO.
BLD-00075 CENTRAL PLANT

400 N. PEPPER AVENUE
COLTON, CA 92324-1801

ENGINEER/ARCHITECT

IDS GROUP

1 PETERS CANYON ROAD, SUITE 130
IRVINE, CA, 92606
TEL: 949-387-6500, FAX: 949-387-0800

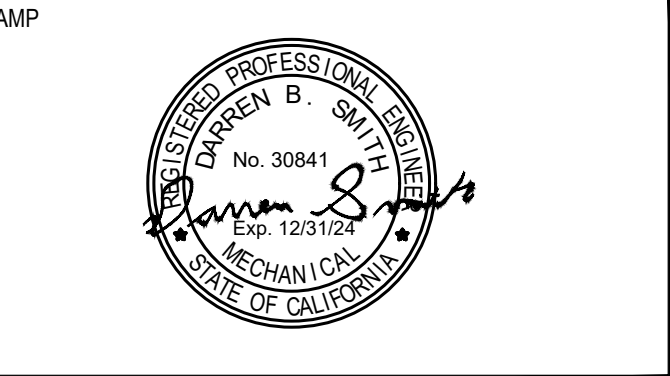

REV.	DESCRIPTION	DATE
	HCAI SUBMITTAL	04/28/23
A	BACK CHECK #1	06/16/23
B	BACK CHECK #2	07/28/23

PROJECT IDENTIFICATION
THIS DRAWING WAS CREATED IN AUTODESK AUTOCAD V. 2021 UNLESS OTHERWISE NOTED.
THE ORIGINAL SIZE OF THIS SHEET IS 30" X 42"
THESE DRAWINGS AND SPECIFICATIONS ARE THE PROPERTY AND COPYRIGHT OF IDS GROUP AND SHALL NOT BE USED ON ANY OTHER PROJECT OR LOCATIONS EXCEPT AS DESCRIBED ON THE DRAWINGS, WITHOUT THE WRITTEN AGREEMENT WITH IDS GROUP.

IDS PROJECT NO.	22X066.02
DRAWN BY	AL
CHECKED BY	RP
APPROVED BY	MO

SHEET TITLE


**ELECTRICAL
FLOOR PLAN
TEMPORARY
WORK**

SHEET NUMBER

E-101

SHEET NO. 4 OF

PLAN CHECK - NOT FOR CONSTRUCTION

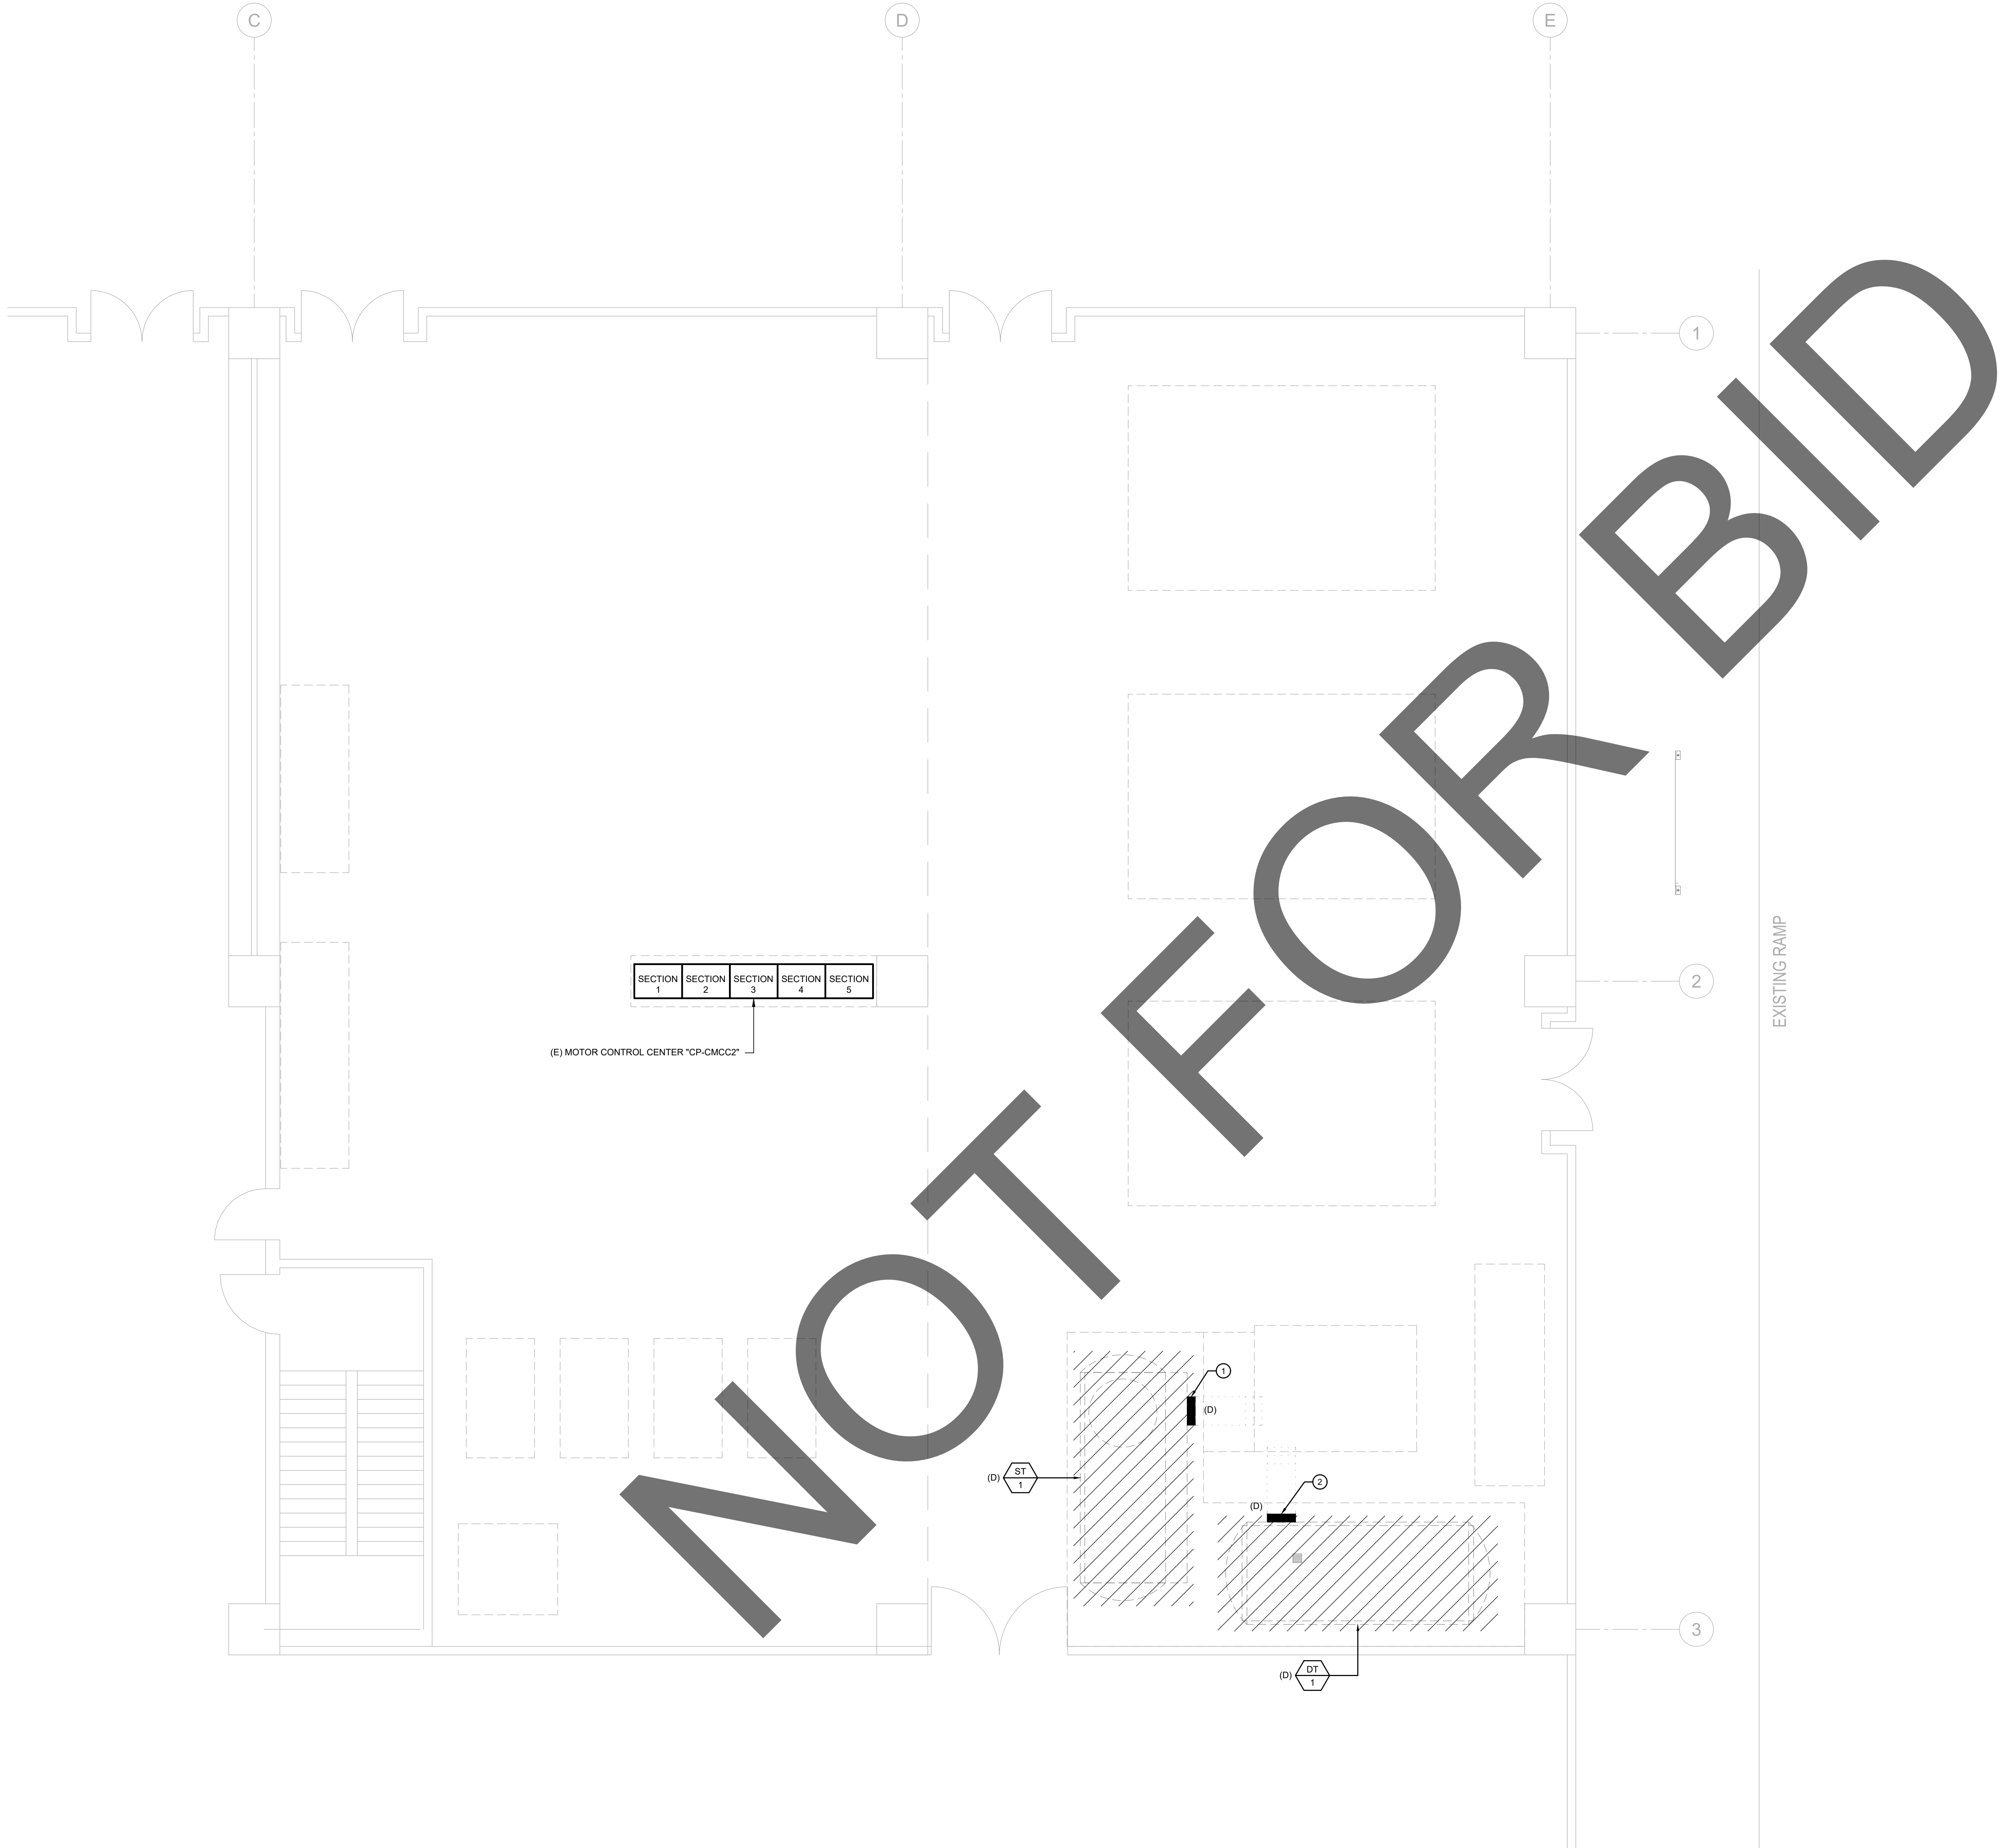

DEMOLITION KEYNOTES

- 1
- CONTRACTOR TO DEMO EXISTING SURGE STATION PUMP CONTROL PANEL "ST-1" AS REQUIRED. SHUTOFF CIRCUITS WITHIN EXISTING MCC "CP-CMCC2" "MDFP-1" AND "MDFP-2", AND LABEL AS SPARE AND POSITION SWITCH TO OFF.
- 2
- CONTRACTOR TO DEMO EXISTING BOILER STATION PUMP CONTROL PANEL "DT-1" AS REQUIRED. SHUTOFF CIRCUITS WITHIN EXISTING MCC "CP-CMCC2" "MBFP-1", "MBFP-2" AND "MBFP-3" AND LABEL AS SPARE AND POSITION SWITCH TO OFF.

APPROVAL



CLIENT



PROJECT NAME

ARMC
DEAERATOR #1
REPLACEMENT

PROJECT NO.

WBSE # 10.10.0847
CIP # 20-011
HCAI #

FACILITY NO.

17282

BUILDING NO.

BLD-00075 CENTRAL PLANT

400 N. PEPPER AVENUE
COLTON, CA 92324-1801

ENGINEER/ARCHITECT



STAMP



STAMP



DATE SIGNED 04/18/23

ISSUE

REV.	DESCRIPTION	DATE
	HCAI SUBMITTAL	04/28/23
A	BACK CHECK #1	06/16/23
B	BACK CHECK #2	07/28/23

PROJECT IDENTIFICATION

THIS DRAWING WAS CREATED IN AUTODESK AUTOCAD V. 2021
UNLESS OTHERWISE NOTED.

THE ORIGINAL SIZE OF THIS SHEET IS 30" X 42"

THESE DRAWINGS AND SPECIFICATIONS ARE THE PROPERTY AND
COPYRIGHT OF IDS GROUP AND SHALL NOT BE USED ON ANY
OTHER PROJECT OR LOCATIONS EXCEPT AS DESCRIBED ON THE
DRAWINGS, WITHOUT THE WRITTEN AGREEMENT WITH IDS GROUP.

IDS PROJECT NO.	22X066.02
DRAWN BY	AL
CHECKED BY	RP
APPROVED BY	MO

SHEET TITLE


ELECTRICAL FLOOR
PLAN DEMOLITION

SHEET NUMBER

E-102

SHEET NO. 5 OF

IDS GROUP - FILE LOCATION: S:\PROJECTS\2022\SHARED\22X066.02 ARMC - REPLACEMENT DEAERATOR 1\05 CAD\05 ELEC\22X06602_E201_NEW PLOT DATE: 7/24/2023 2:27:40 PM USER: MANNY OCAMPO

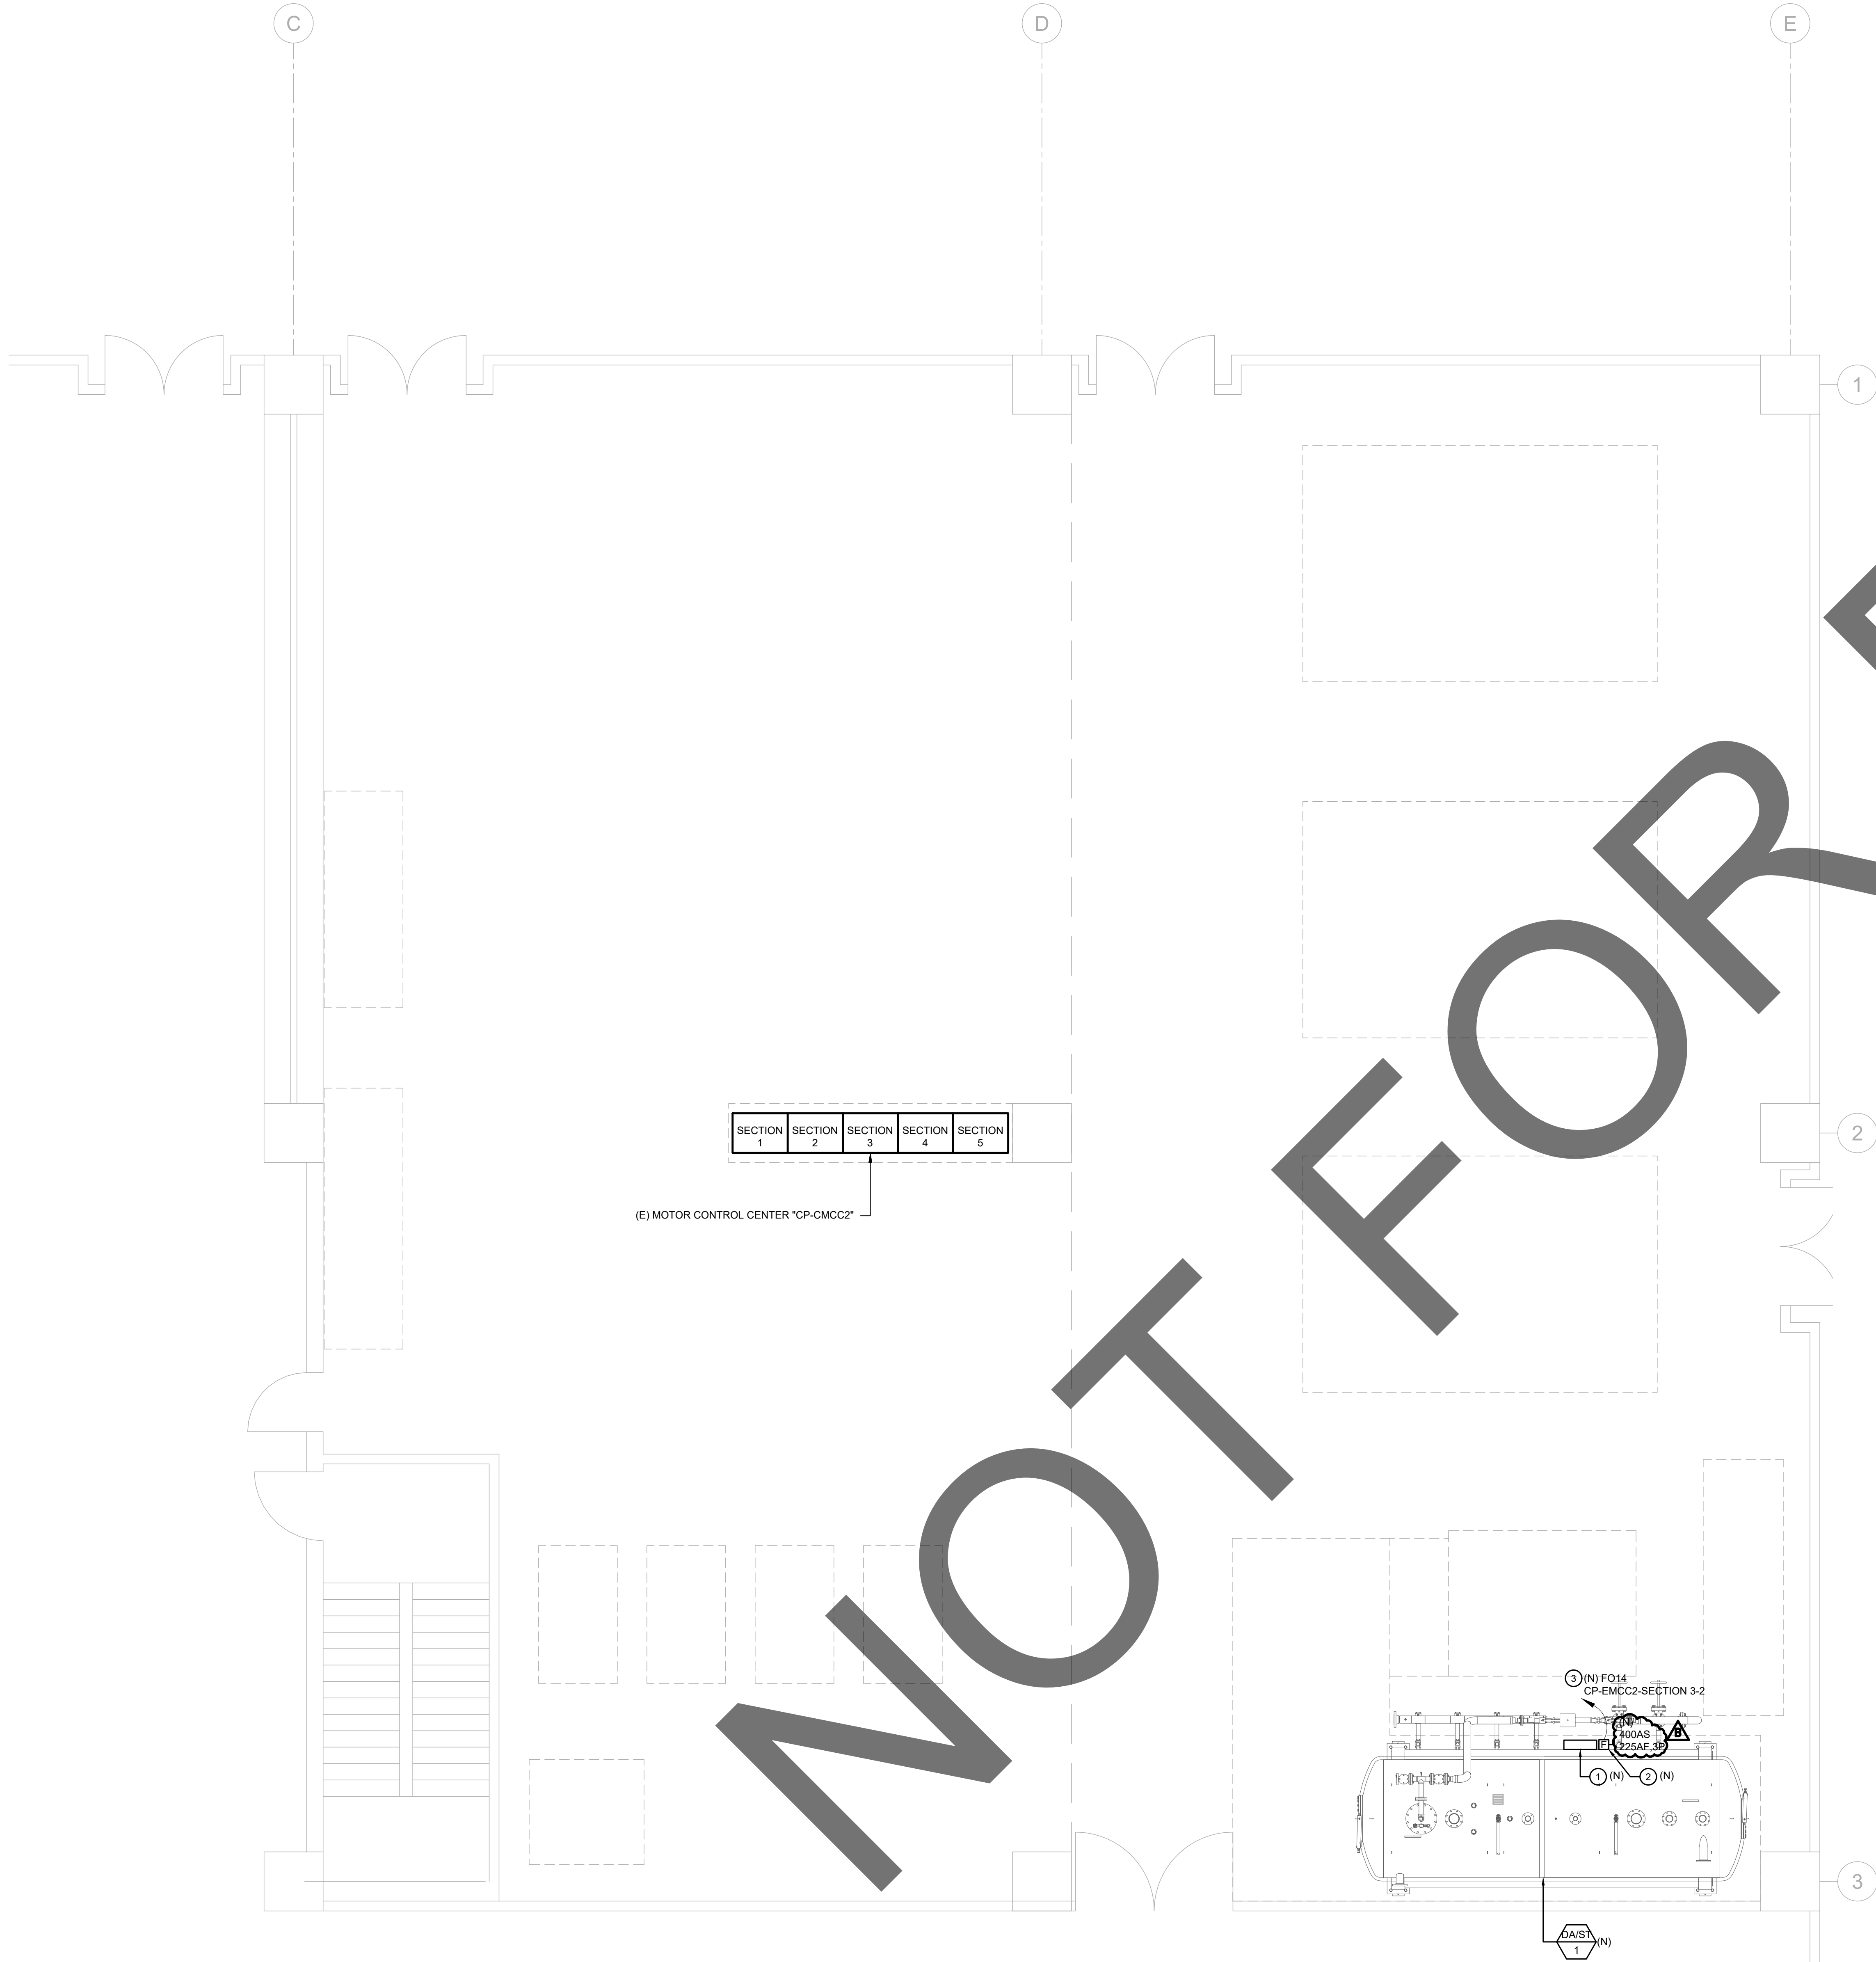

EXISTING RAMP

KEYNOTES

- 1 NEW STEAM BOILER CONTROL PANEL LOCATED ON EQUIPMENT. VERIFY EXACT LOCATION.
- 2 NEW EQUIPMENT DISCONNECT SWITCH. VERIFY EXACT LOCATION WITH NEXT TO EQUIPMENT CONTROL PANEL PRIOR TO ROUGH-IN.
- 3 PROVIDE ELECTRICAL CONNECTION FROM MECHANICAL EQUIPMENT DA/ST-1 TO EXISTING MCC "CP-CMCC2" SECTION 5. SPACE 5 AS REQUIRED FOR PERMANENT POWER. VERIFY EXACT LOCATION AND REQUIREMENTS OF EQUIPMENT PRIOR TO ROUGH-IN. REFER TO SINGLE LINE DIAGRAM SHEET FOR NEW FEEDER AND CONDUIT SIZING.

APPROVAL



CLIENT



PROJECT NAME

ARMC
DEAERATOR #1
REPLACEMENT

PROJECT NO.

WBSE # 10.10.0847
CIP # 20-011
HCAI #

FACILITY NO.


17282

BUILDING NO.

BLD-00075 CENTRAL PLANT

400 N. PEPPER AVENUE
COLTON, CA 92324-1801

ENGINEER/ARCHITECT

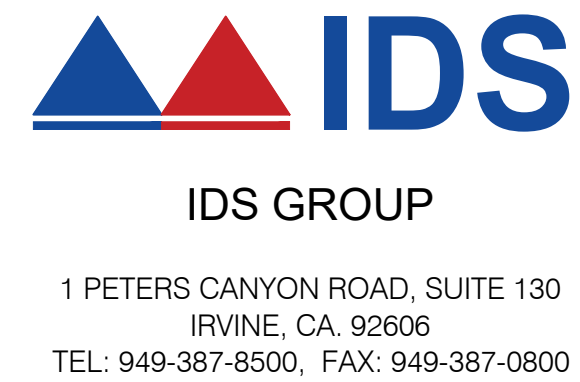

STAMP



STAMP



DATE SIGNED 04/18/23

ISSUE

REV.	DESCRIPTION	DATE
	HCAI SUBMITTAL	04/28/23
A	BACK CHECK #1	06/16/23
B	BACK CHECK #2	07/28/23

PROJECT IDENTIFICATION

THIS DRAWING WAS CREATED IN AUTODESK AUTOCAD V. 2021 UNLESS OTHERWISE NOTED.
THE ORIGINAL SIZE OF THIS SHEET IS 30" X 42"
THESE DRAWINGS AND SPECIFICATIONS ARE THE PROPERTY AND COPYRIGHT OF IDS GROUP AND SHALL NOT BE USED ON ANY OTHER PROJECT OR LOCATIONS EXCEPT AS DESCRIBED ON THE DRAWINGS, WITHOUT THE WRITTEN AGREEMENT WITH IDS GROUP.

IDS PROJECT NO.	22X066.02
DRAWN BY	AL
CHECKED BY	RP
APPROVED BY	MO

SHEET TITLE

ELECTRICAL
FLOOR PLAN

SHEET NUMBER

E-201

SHEET NO. 6


OF

ELECTRICAL FLOOR PLAN

1/4" = 1'-0"

1

PLAN CHECK - NOT FOR CONSTRUCTION

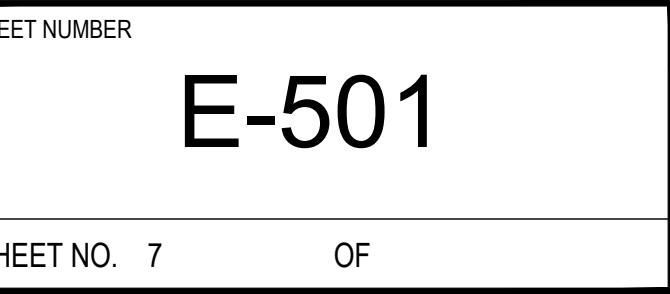

PLAN CHECK - NOT FOR CONSTRUCTION