


REQUIRED FIXTURES COUNT PER CPC TABLE 4.2 (B OCCUPANCY) THAN 500 OCCUPANTS	4: 201 - 400, ADD 1 FOR EA. 500	11: 201 - 400, ADD 1 FOR EA. 150	4: 401 - 600, ADD 1 FOR EA. 300	5: 301 - 400, ADD 1 FOR EA. 250	6: 301 - 400, ADD 1 FOR EA. 200	(ALL GENDER) SINGLE ACCOMMODATION TOILETS	DINING FOUNTAINS
WATER CLOSET (MALE)	4	12	4	5	7		1: 150
WATER CLOSET (FEMALE)	5	12	4	5	7		4
URINALS	1	3	2	3	3		2
LAVATORIES (MALE)	2	5	3	3	3		2
LAVATORIES (FEMALE)	2	5	3	3	3		2
(ALL GENDER) SINGLE ACCOMMODATION TOILETS	5	13	8	9	9	4	6
DINING FOUNTAINS							


NOTE: THE TOTAL EXISTING FIXTURE COUNT PROVIDED IN THE BUILDING FOR PUBLIC USE COMPLIES WITH THE REQUIRED COUNT IDENTIFIED IN CPC TABLE 4.2. THE ADDITIONAL SEVEN (7) SINGLE ACCOMMODATION TOILETS IN THE T.I. WILL BE USED PRIMARILY FOR PATIENTS / STAFF AND NOT ACCESSIBLE FOR PUBLIC, THEREFORE ARE NOT INCLUDED IN THE TOTAL COUNT

**PLUMBING FIXTURES COUNT (BASED ON TOTAL OCCUPANT LOAD OF THE BUILDING)**

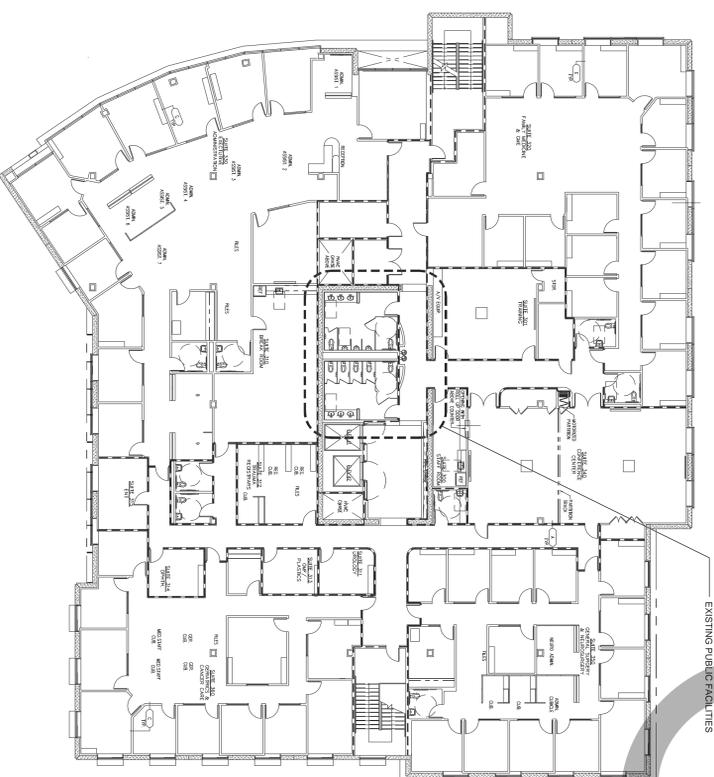


**A5** EXISTING THIRD FLOOR PLUMBING FIXTURE COUNT

SCALE: 1/16"=1'-0"

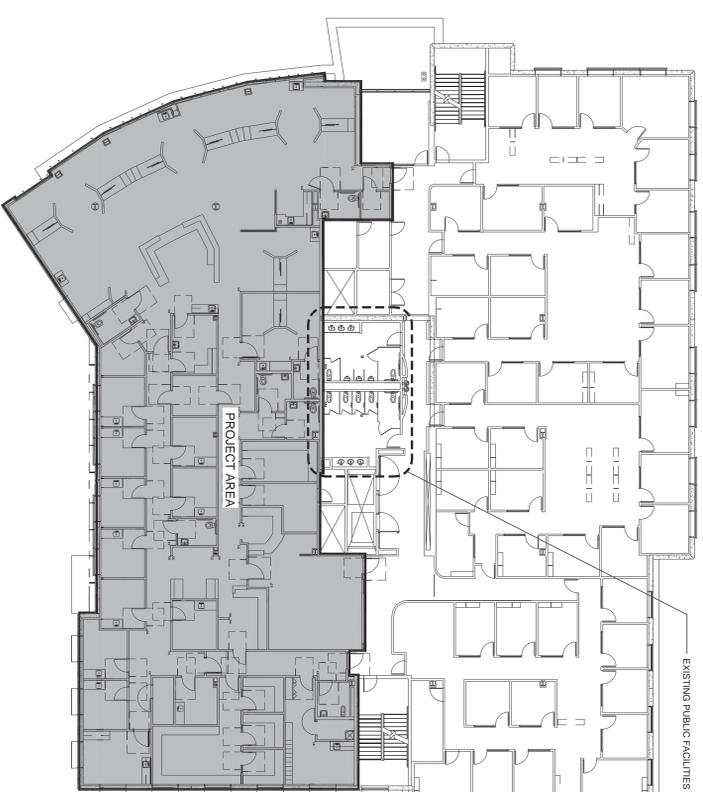

**K12** EXISTING SECOND FLOOR PLUMBING FIXTURE COUNT

SCALE: 1/16"=1'-0"

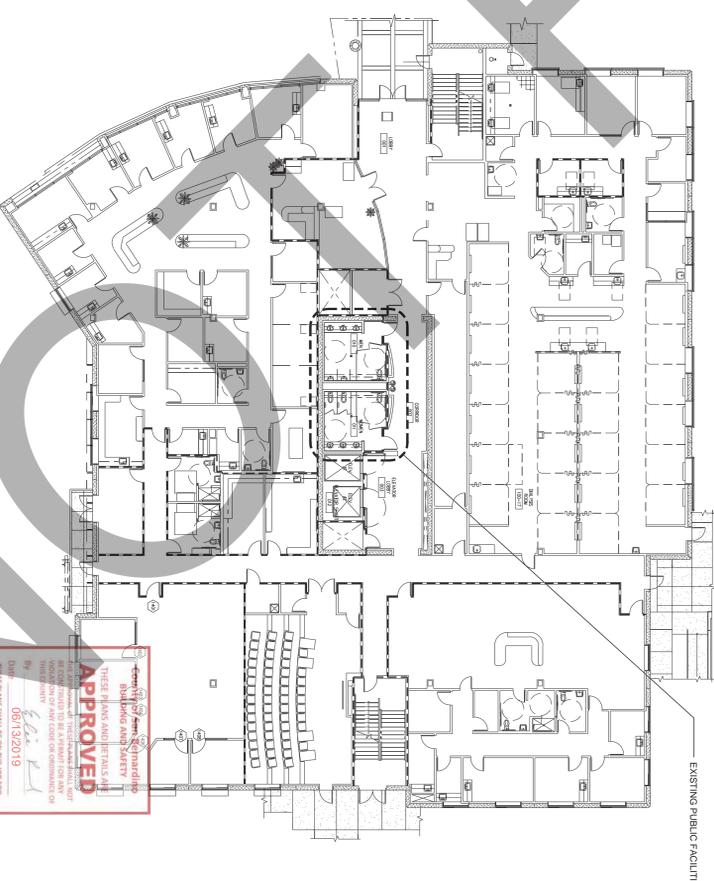

**A12** EXISTING FIRST FLOOR PLUMBING FIXTURE COUNT

SCALE: 1/16"=1'-0"



**S H A**

**SAVELY ARCHITECTS**

18008 Sky Park Circle, Suite 290  
Irvine, CA 92614  
(949) 431-0071

**PROJECT**  
ARROWHEAD  
REGIONAL MEDICAL CENTER  
MEDICAL OFFICE BUILDING  
400 N. PEPPER AVE.  
COLTON, CALIFORNIA 92324  
ONCOLOGY-AMBULATORY CLINIC

NO. DATE REVISIONS

PROFESSIONAL SEALS

AGENCY APPROVAL

Digitally signed by Eric Rodriguez, SE  
DN: cn=Eric Rodriguez, SE, o=NVS, Inc., ou=Energy, email=eric.rodriguez@nvs.com, c=US  
Reason: Reviewed for Code Compliance.  
Date: 2019.06.12 08:56:10 -0700'

DRAWN BY: EED  
CHECKED BY: GL  
DATE: 02.22.2019  
DATE: 05.23.2019

PROJECT NUMBER: 18242.700

 
**A102**

CODE ANALYSIS PLAN - PLUMBING FIXTURE COUNT



**KEYNOTES**

- FP01 CENTERLINE OF INFUSION BAYS
- FP02 FACE OF NURSE STATION CASEWORK
- FP03 START POINT OF RADIUS



ARCHITECT

**Savely**  
**Healthcare Architects**  
 ARCHITECTURE + PLANNING + DESIGN  
 18008 Sky Park Circle, Suite 290  
 Irvine, CA 92614  
 (949) 431-0071

PROJECT  
**ARROWHEAD**  
**REGIONAL MEDICAL CENTER**  
**MEDICAL OFFICE BUILDING**  
 400 N. PEPPER AVE.  
 COLTON, CALIFORNIA 92324  
**ONCOLOGY-AMBULATORY CLINIC**

NO. DATE REVISIONS

PROFESSIONAL SEALS



AGENCY APPROVAL

Digitally signed by Eric Rodriguez SE  
 DN: cn=Eric Rodriguez, SE, o=NVS, Inc., ou=Energy, email=eric.rodriquez@nvs.com, c=US  
 Reason: Reviewed for Code Compliance.  
 Date: 2019.06.12 08:56:47 -07'00'


DRAWN BY	GL	CHECKED BY	DATE
EED	GL	02.22.2019	05.23.2019
PROJECT NUMBER			
SHA # 18242.100			

SHEET TITLE  
**OVERALL FLOOR PLAN**  
 SHEET NUMBER  
**A121**


**LEGEND**

- EXISTING NON RATED WALL
- EXISTING CONCRETE WALL
- EXISTING 1-HOUR RATED WALL
- NON RATED WALL
- 1-HOUR RATED WALL

**KEY PLAN**

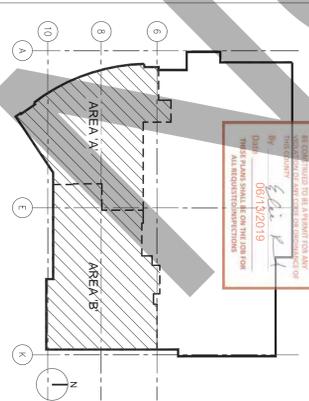

**A3 OVERALL SECOND FLOOR PLAN**

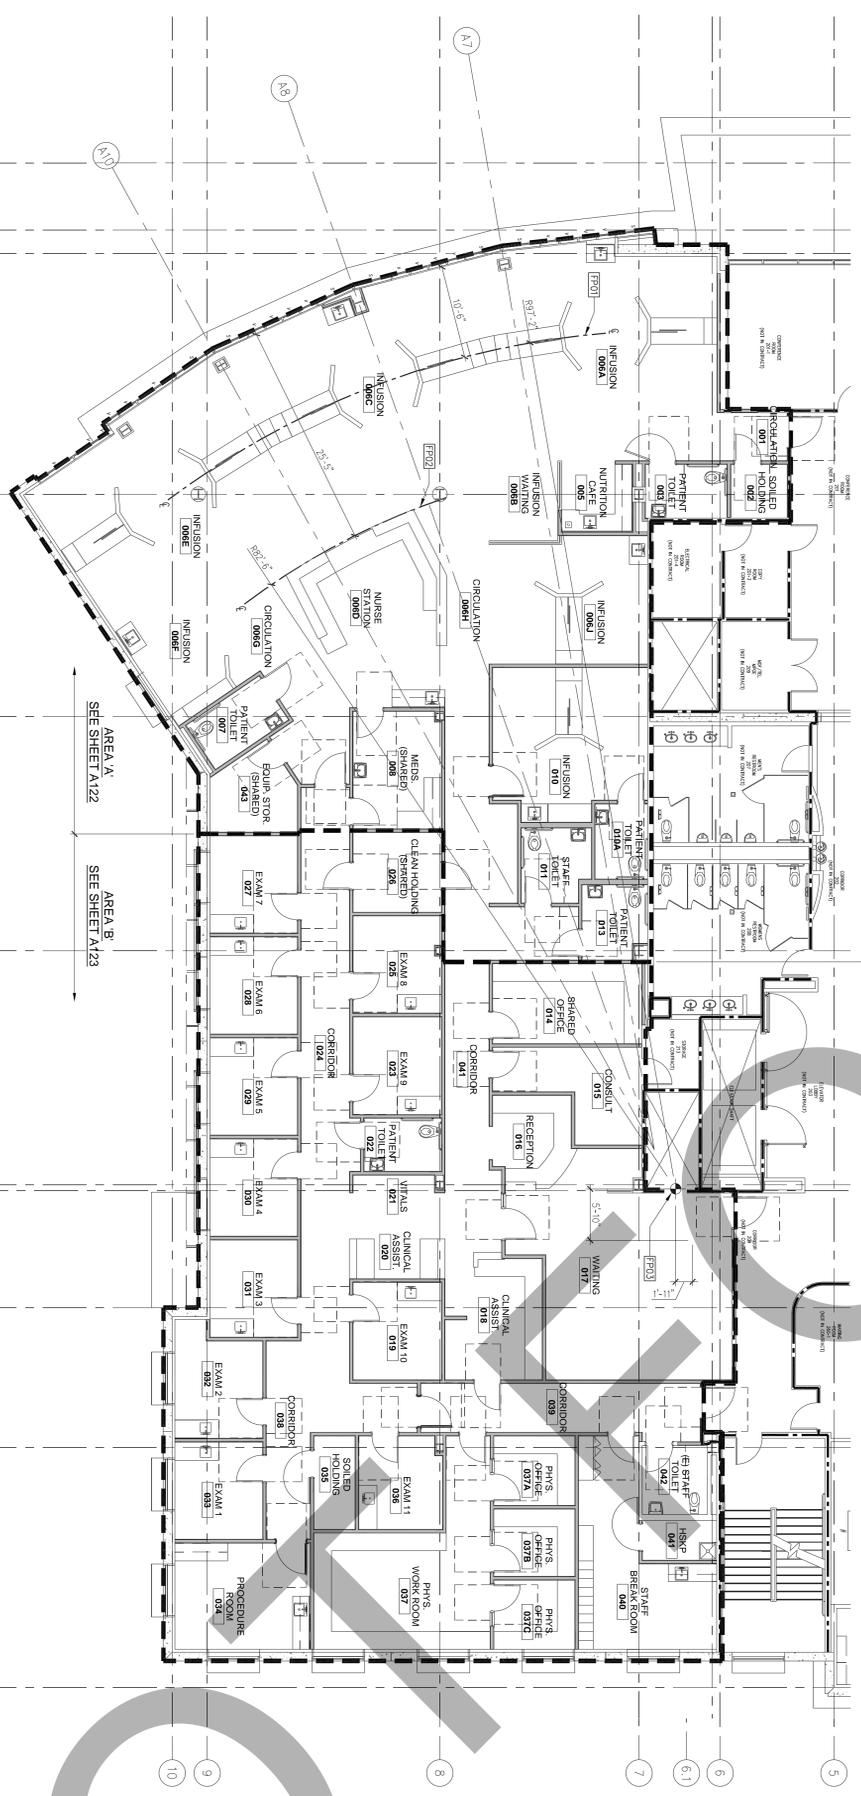

SCALE: 1/8"=1'-0"

OVER BLD